







PROPOSED INTERIOR FOR BPCL TERRITORY OFFICE @
VIJAYAWADA

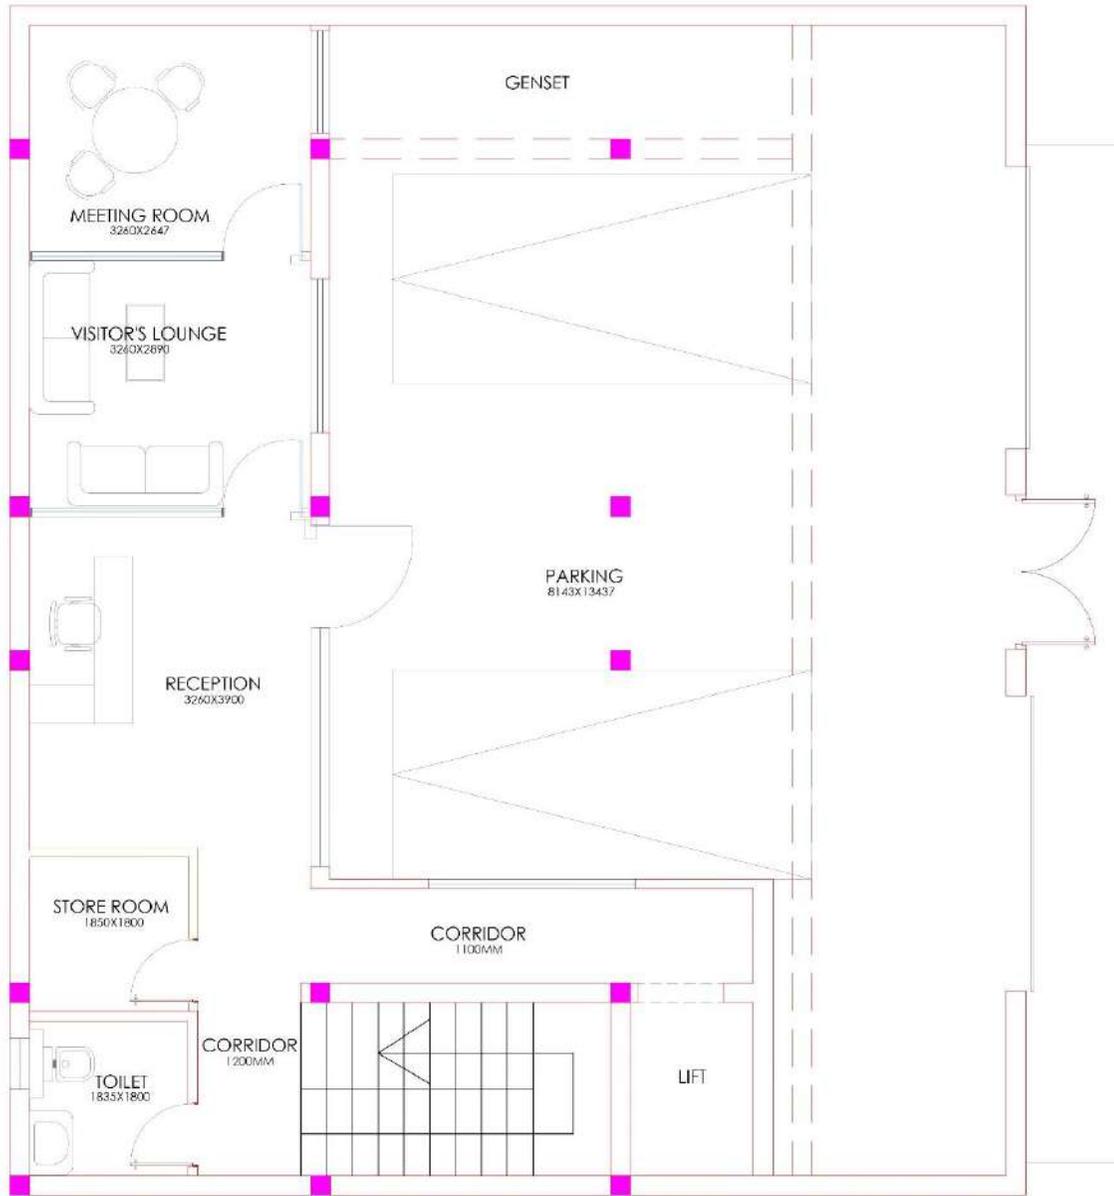

GROUND FLOOR PLAN

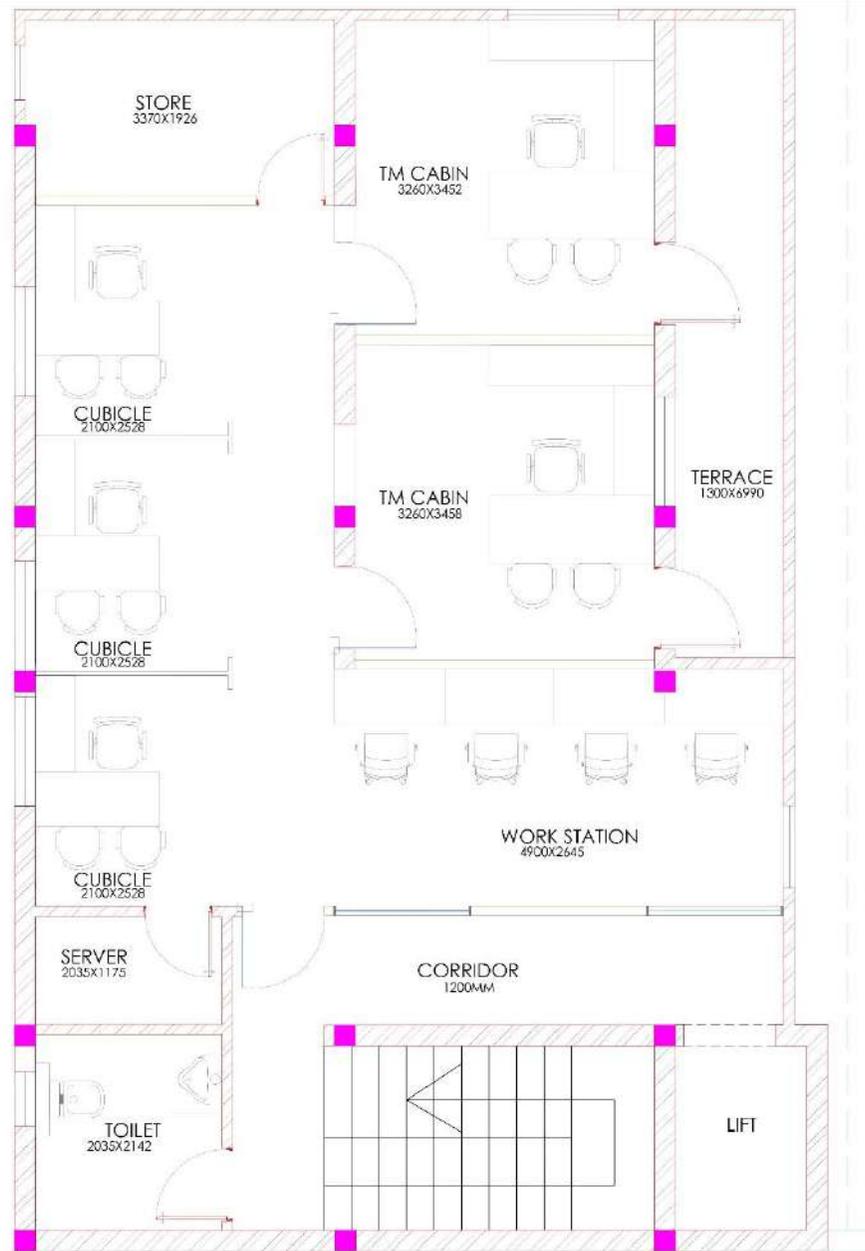

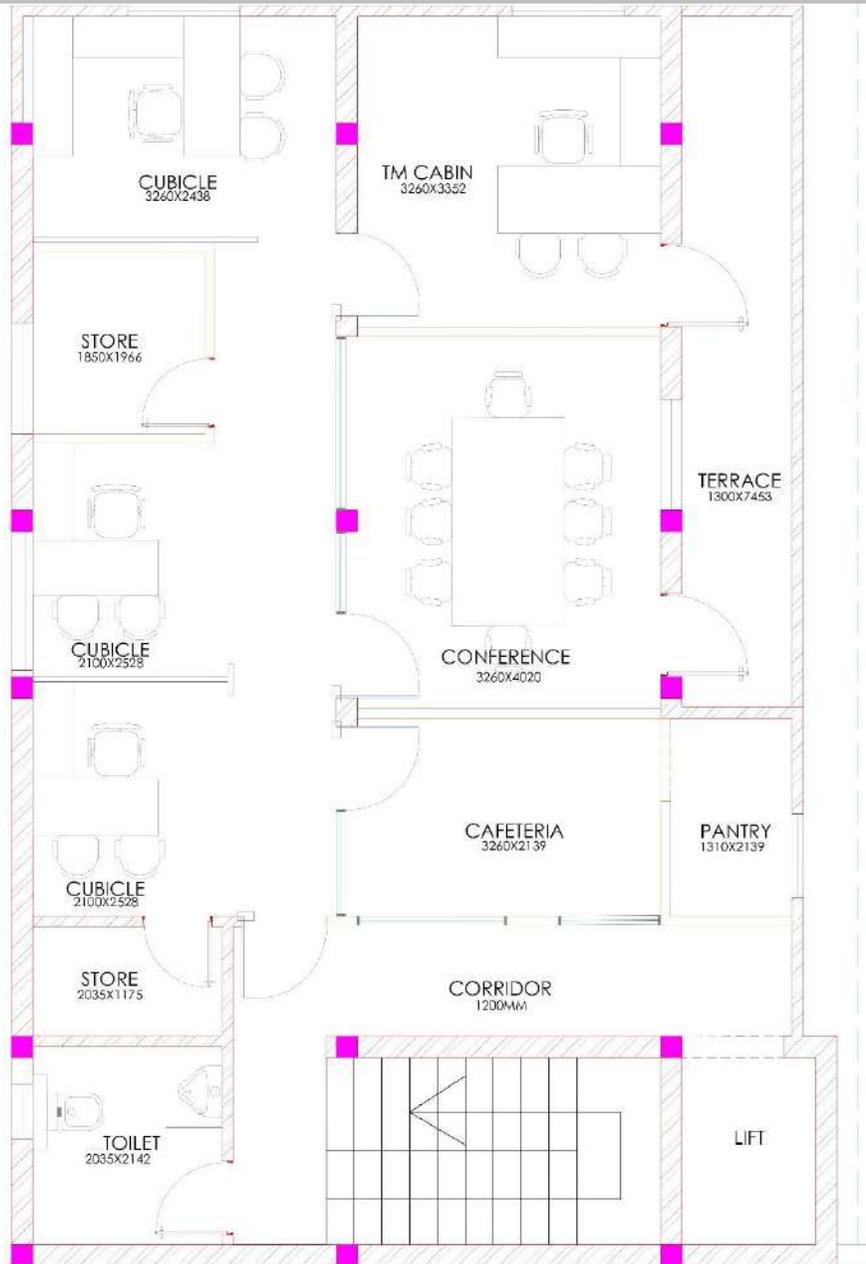


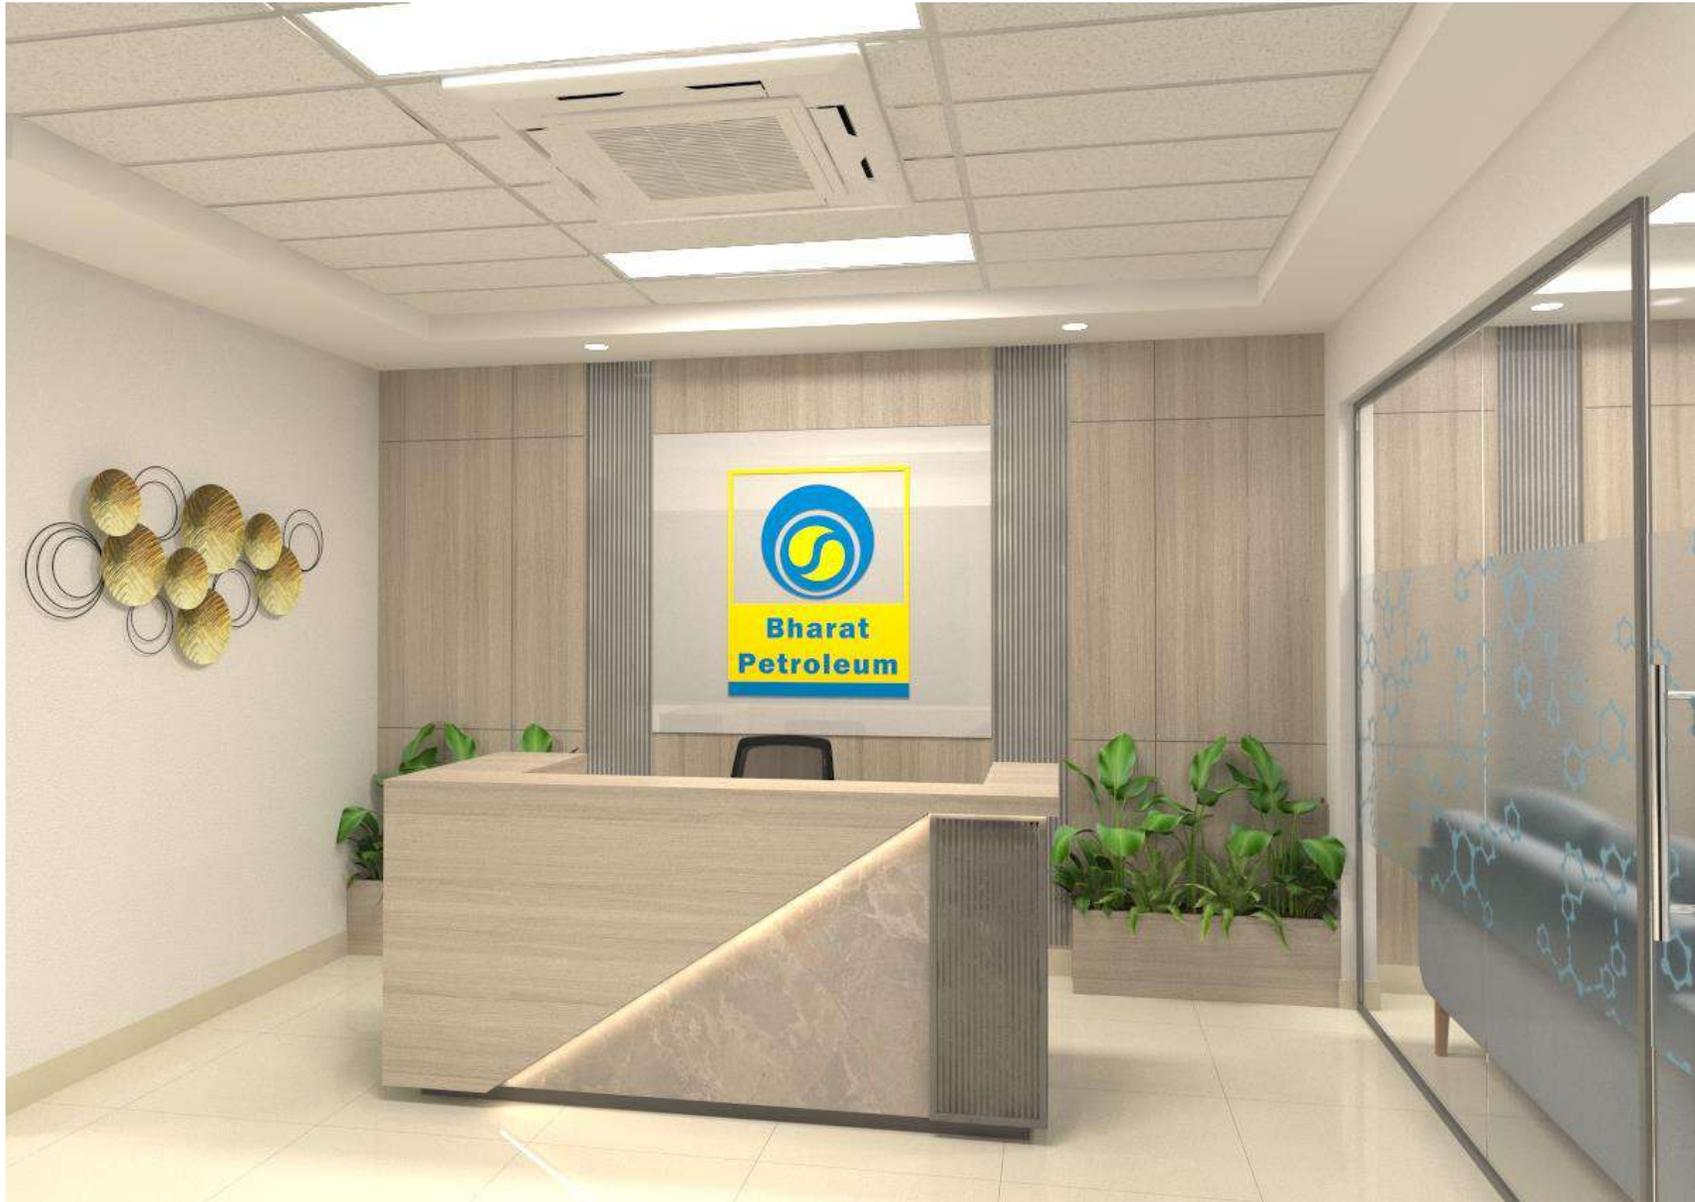


RECEPTION

APPROVED VIEW



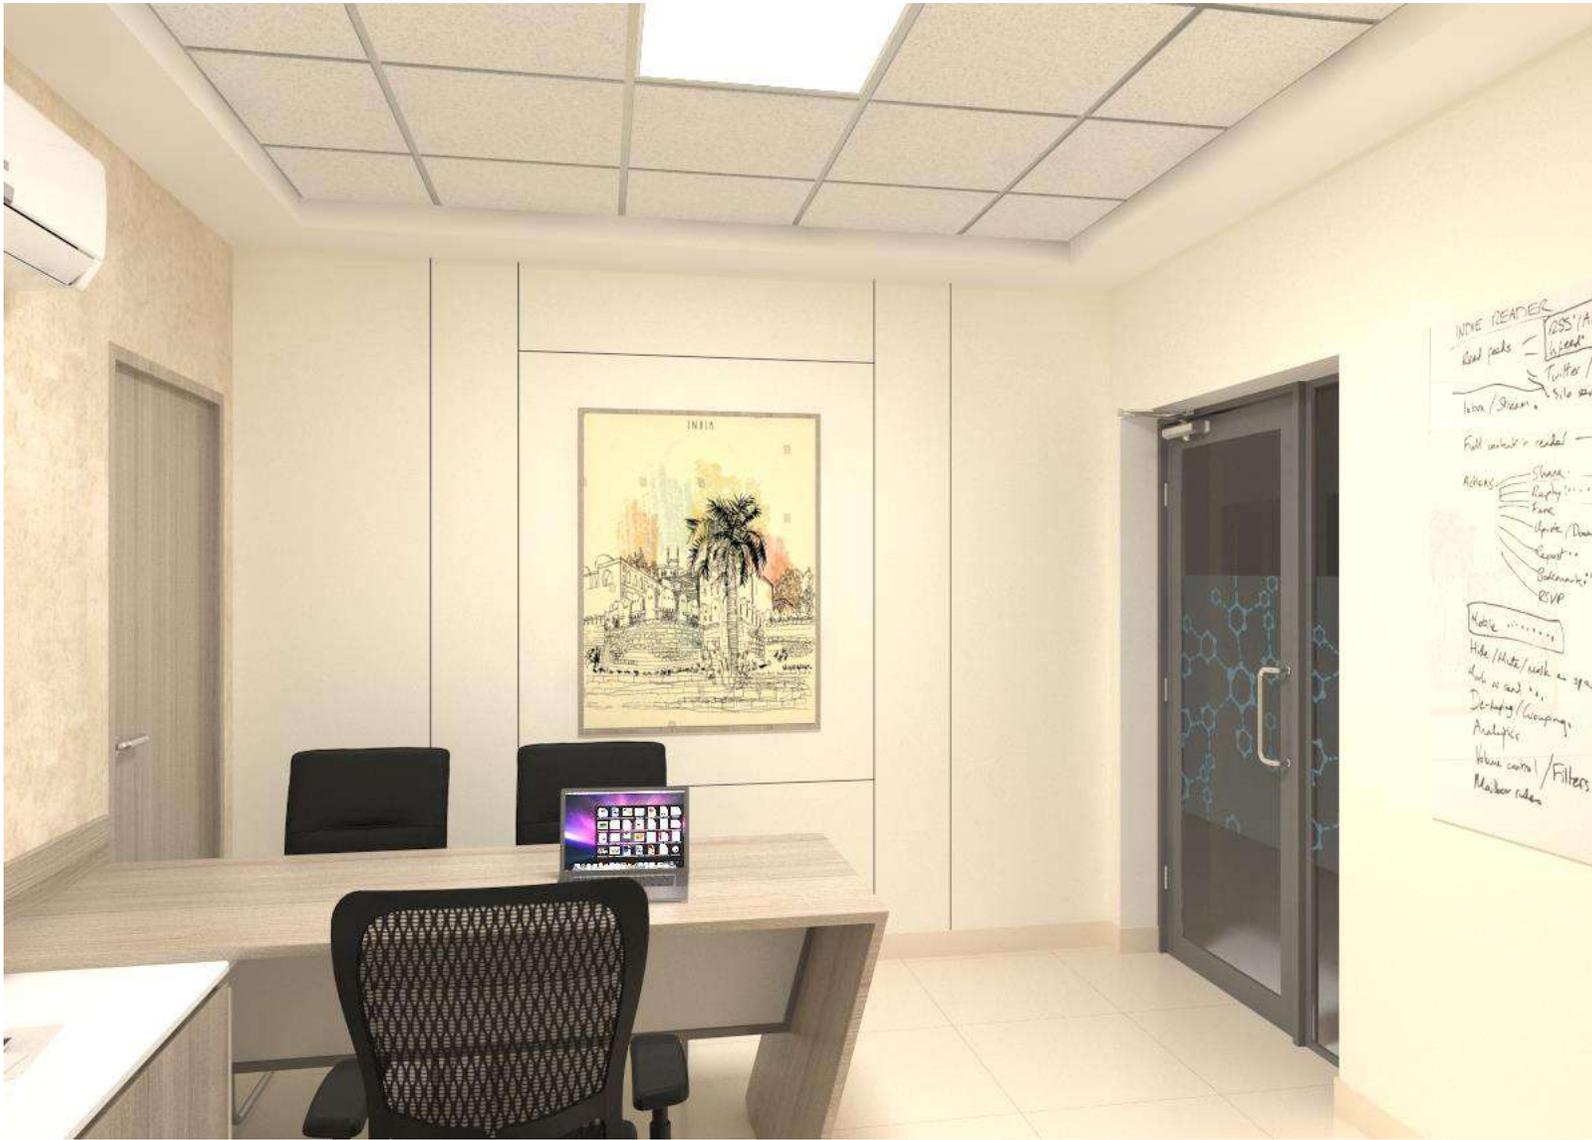

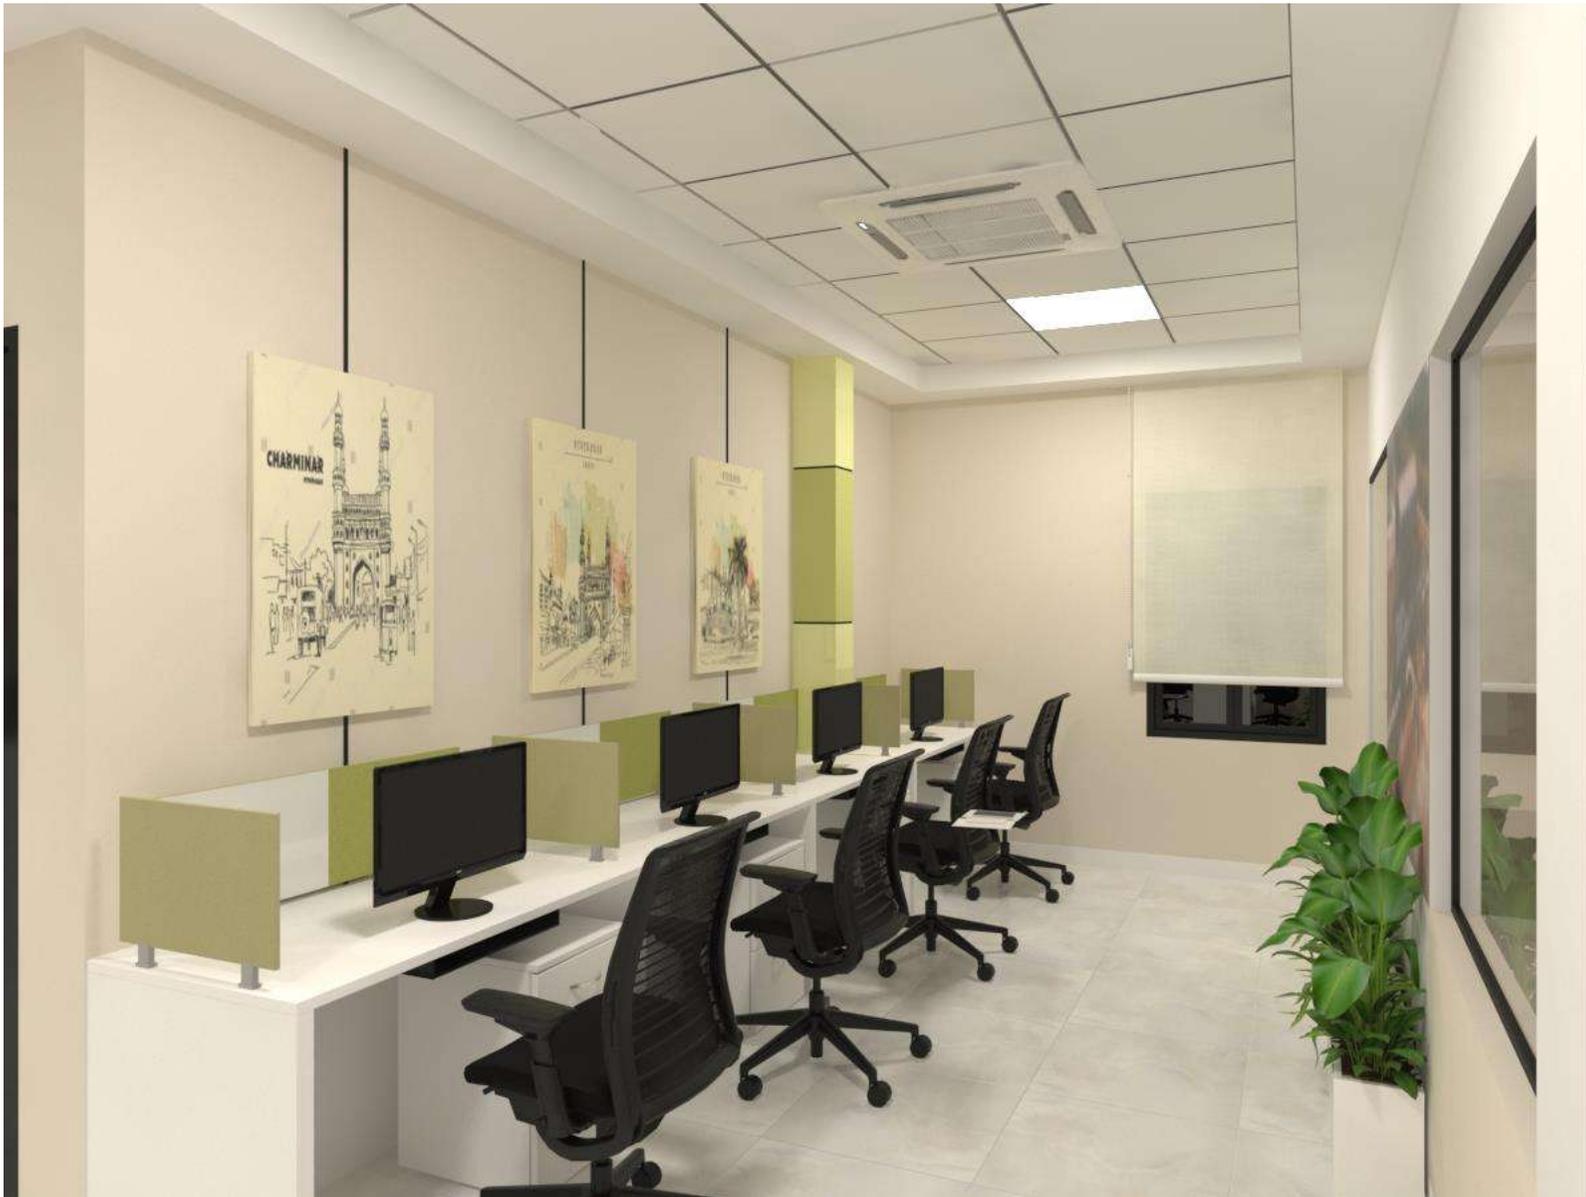

WORKSTATION

REVISED VIEW



WORKSTATION


REVISED VIEW



EXTERIOR ELEVATION

REVISED VIEW

THANK YOU

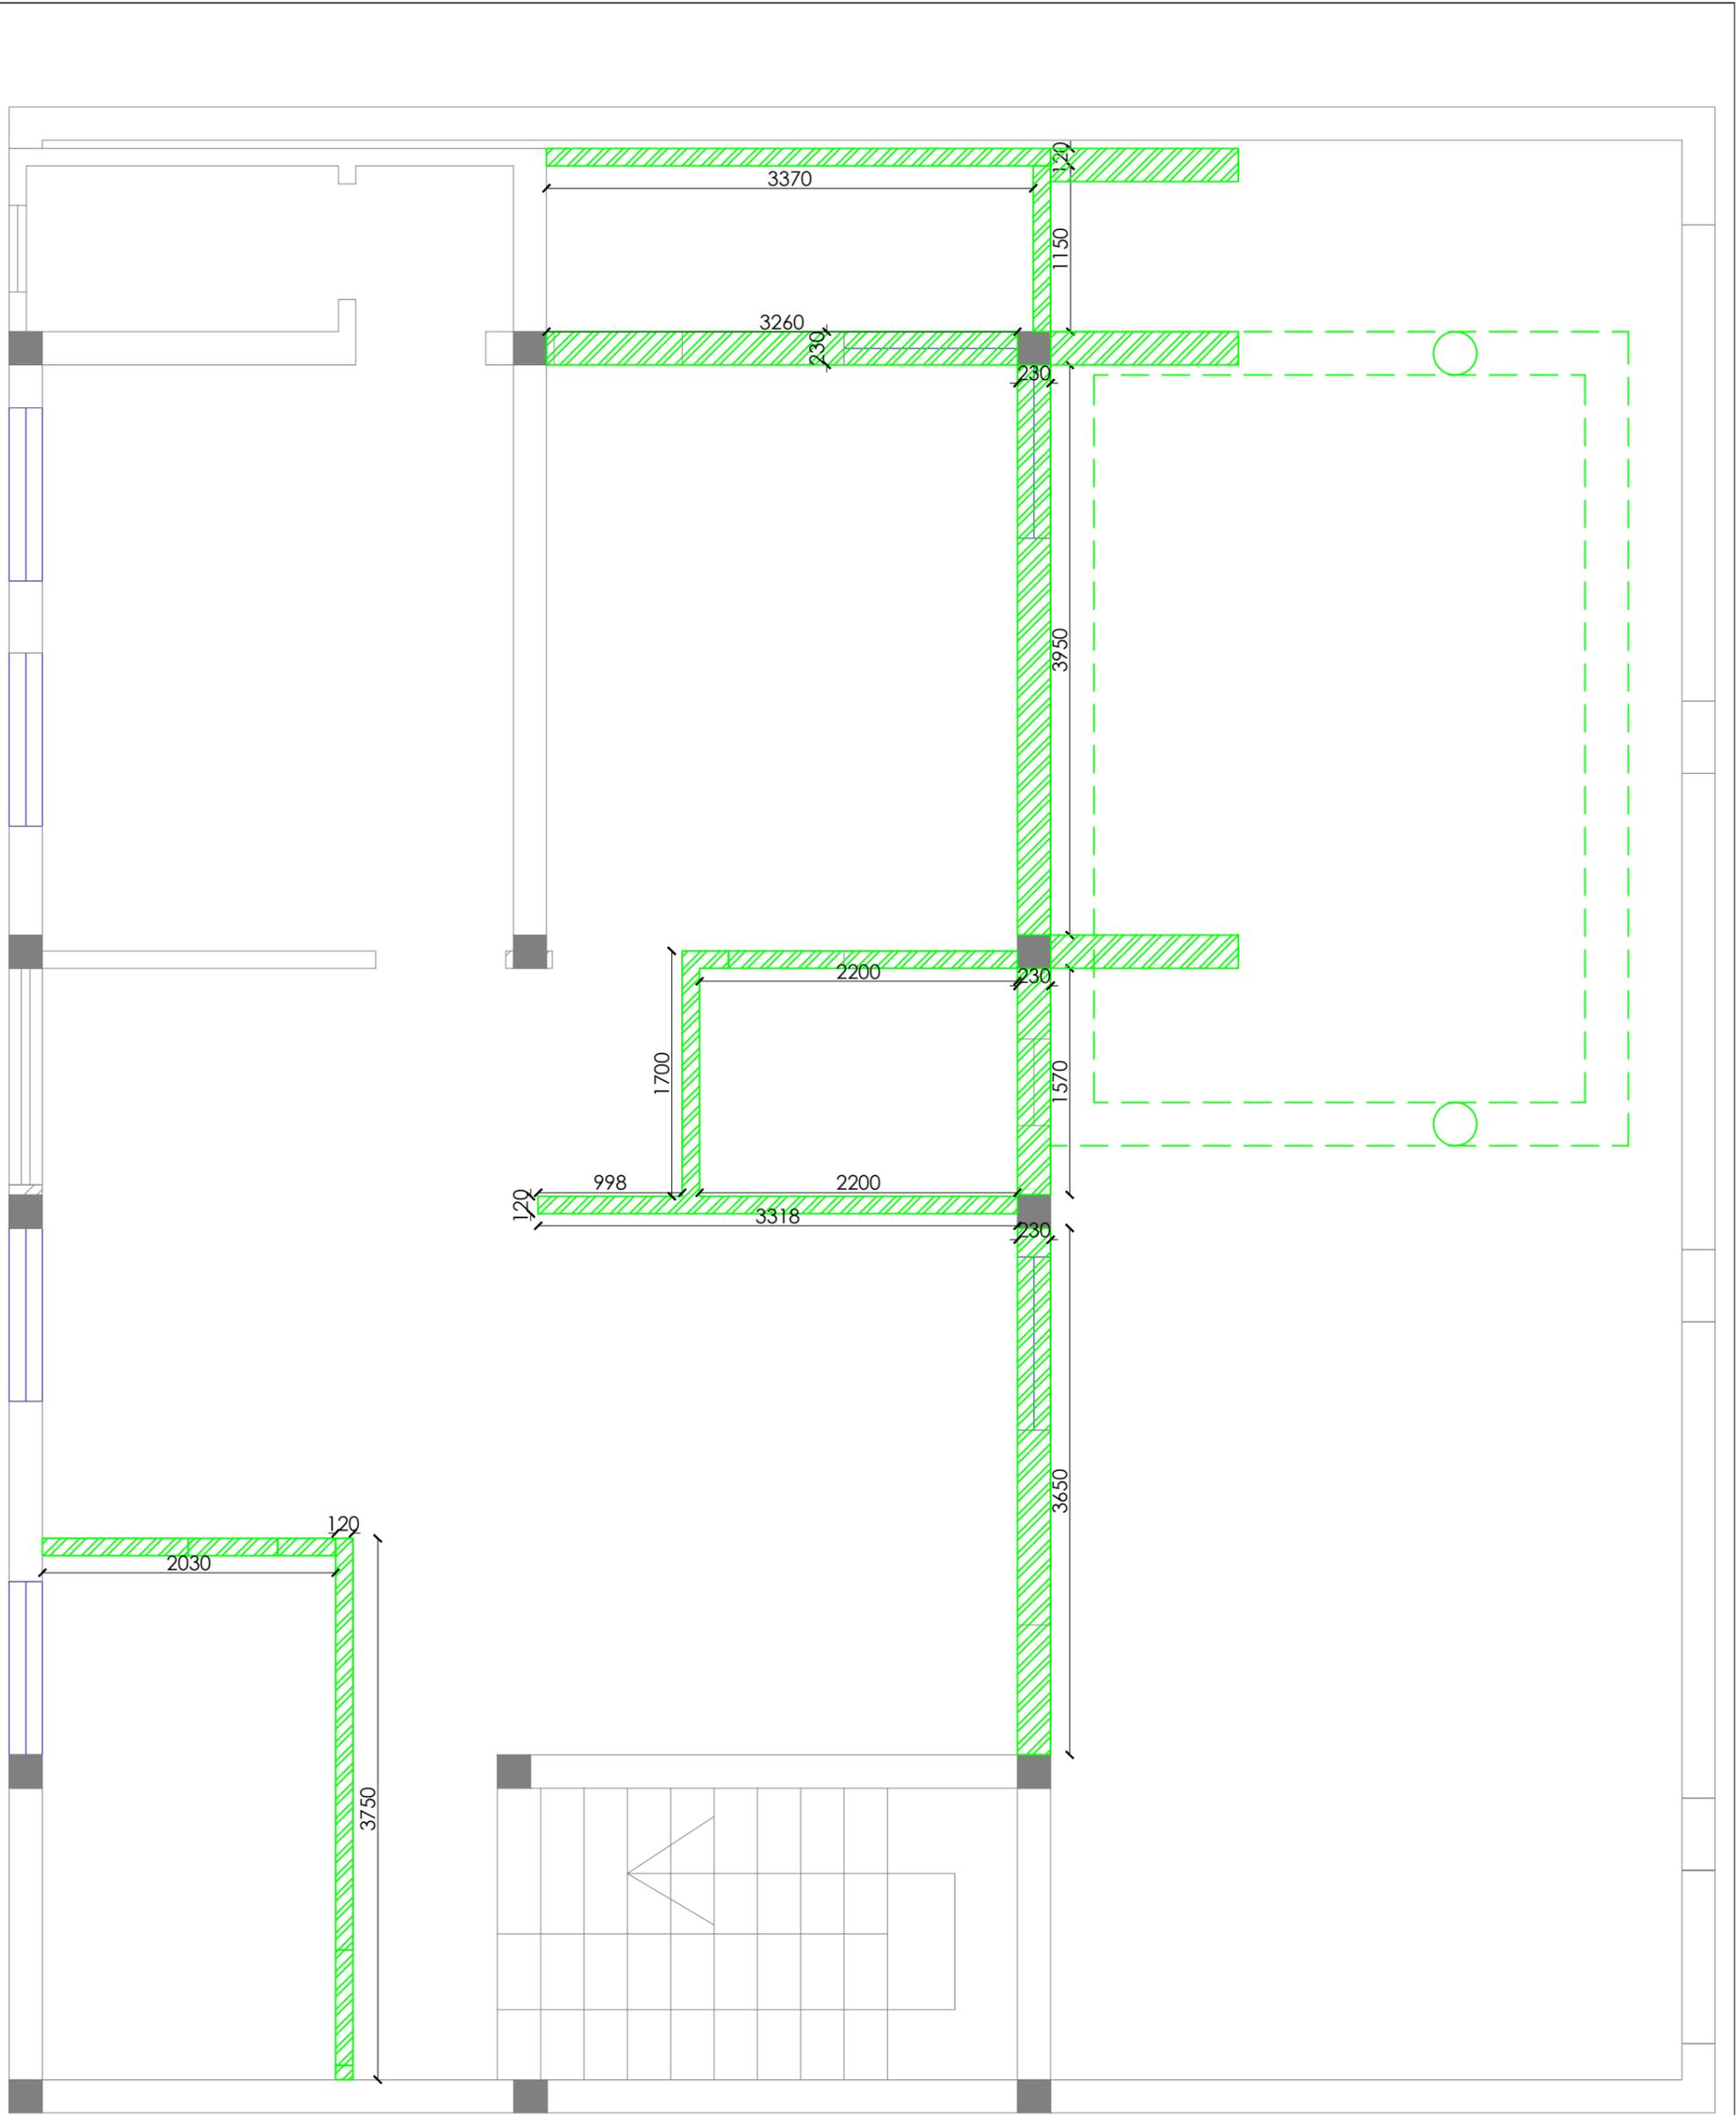


GROUND FLOOR PLAN

CIVIL CHANGES LEGEND

- WALL TO BE DEMOLISHED
- PROPOSED BRICK WALL


Client	BPCL	Project Title	PROPOSED INTERIORS FOR BPCL TERRITORY OFFICE @ VIJAYAWADA		Drawing Title	DEMOLITION LAYOUT		Dwg No	BPCL_TO_TD-001
GENERAL NOTE: 1. DRAWING TO BE USED ONLY FOR THE PURPOSE RELEASED. 2. DO NOT SCALE THIS DRAWING, ONLY WRITTEN DIMENSIONS TO BE FOLLOWED. 3. ANY DISCREPANCY IN THE DRAWING SHOULD BE IMMEDIATELY BROUGHT TO THE NOTICE OF ARCHITECT.		REV	DESCRIPTION	BY	DATE	Drawn	KARTHIK		
						Checked	VYOM		
						Approved	VYOM		
						Date	23.01.2024		
						Issued for	ISSUEDFORTENDER	Scale	
						New Designer Web Pvt Ltd <small>No.185, 2nd Floor, 1st Main road, Nehru nagar, Kandanchavadi, Perungudi, Chennai - 600096 Tel: +91- 044 - 4212511www.designerweb.in</small>			

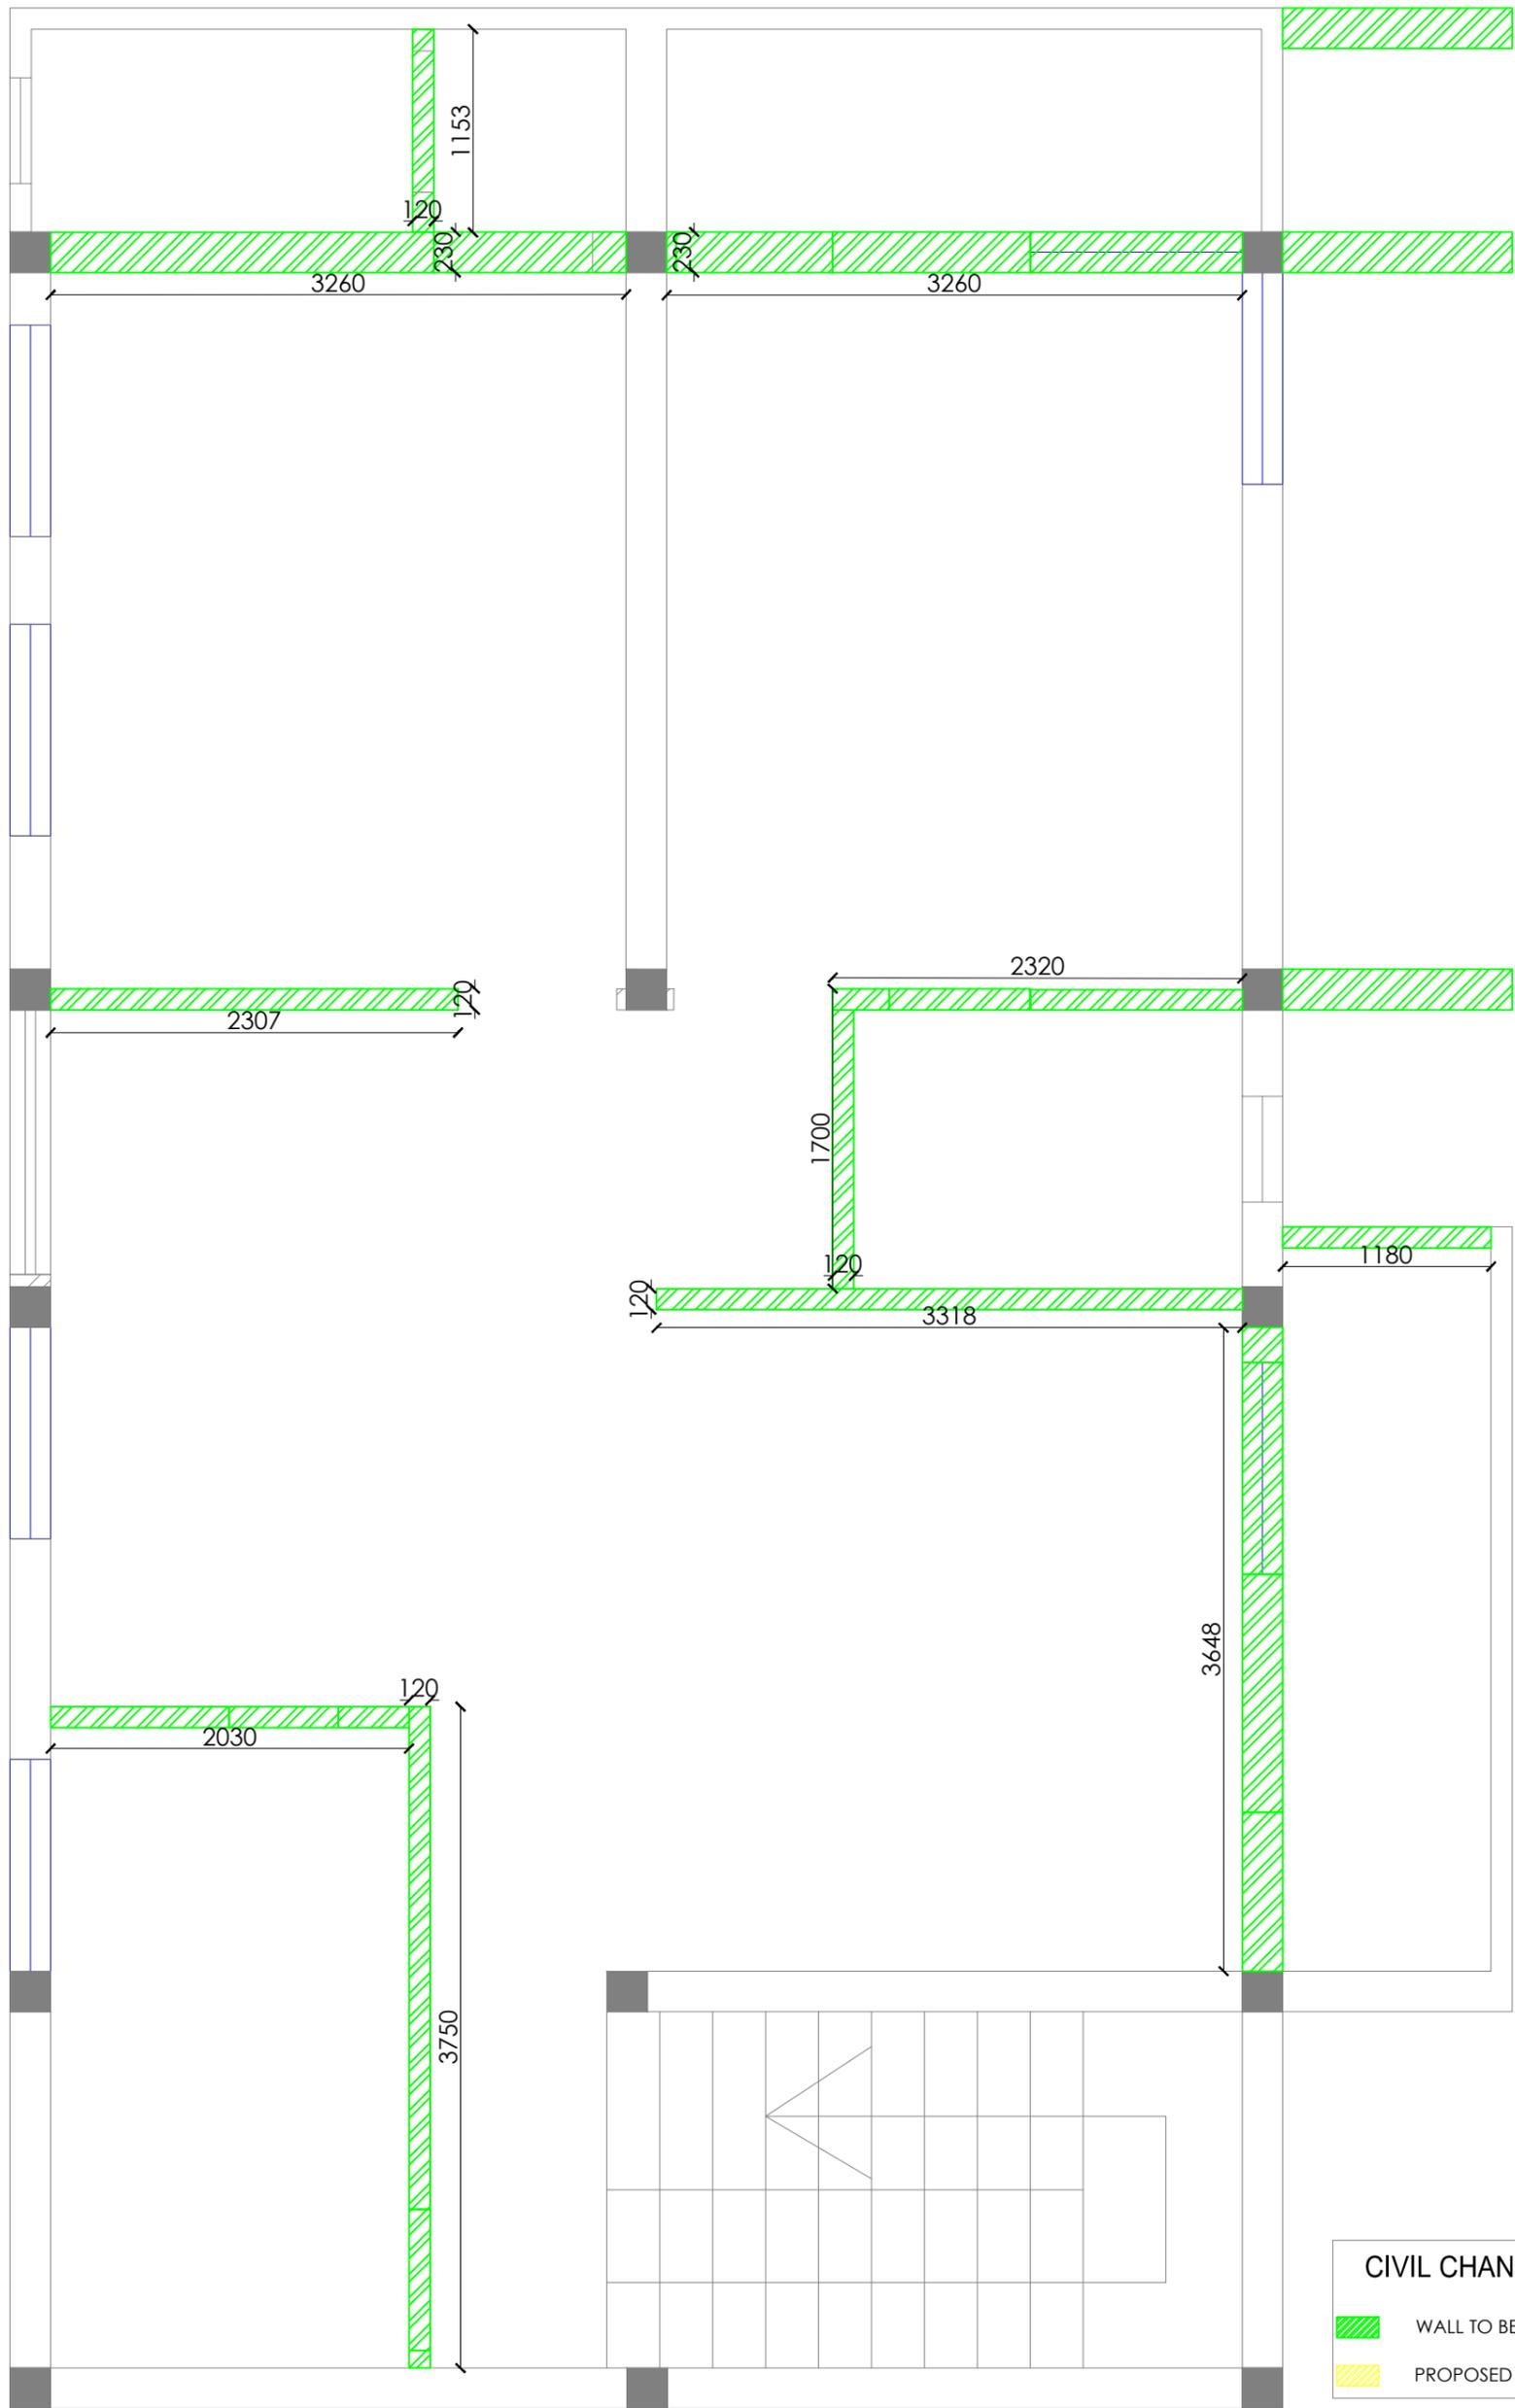

CIVIL CHANGES LEGEND	
	WALL TO BE DEMOLISHED
	PROPOSED BRICK WALL


FIRST FLOOR PLAN

Client	BPCL	Project Title	PROPOSED INTERIORS FOR BPCL TERRITORY OFFICE @ VIJAYAWADA		Drawing Title	DEMOLITION LAYOUT		Dwg No	BPCL_TO_TD-001
GENERAL NOTE: 1. DRAWING TO BE USED ONLY FOR THE PURPOSE RELEASED. 2. DO NOT SCALE THIS DRAWING, ONLY WRITTEN DIMENSIONS TO BE FOLLOWED. 3. ANY DISCREPANCY IN THE DRAWING SHOULD BE IMMEDIATELY BROUGHT TO THE NOTICE OF ARCHITECT.		REV	DESCRIPTION	BY	DATE	Drawn	KARTHIK		Architects  New Designer Web Pvt Ltd No.185, 2nd Floor, 1st Main road, Nehru nagar, Kandanchavadi, Perungudi, Chennai - 600096 Tel: +91- 044 - 4212511 www.designerweb.in
						Checked	VYOM		
						Approved	VYOM		
						Date	23.01.2024		
						Issued for	ISSUEDFORTENDER		

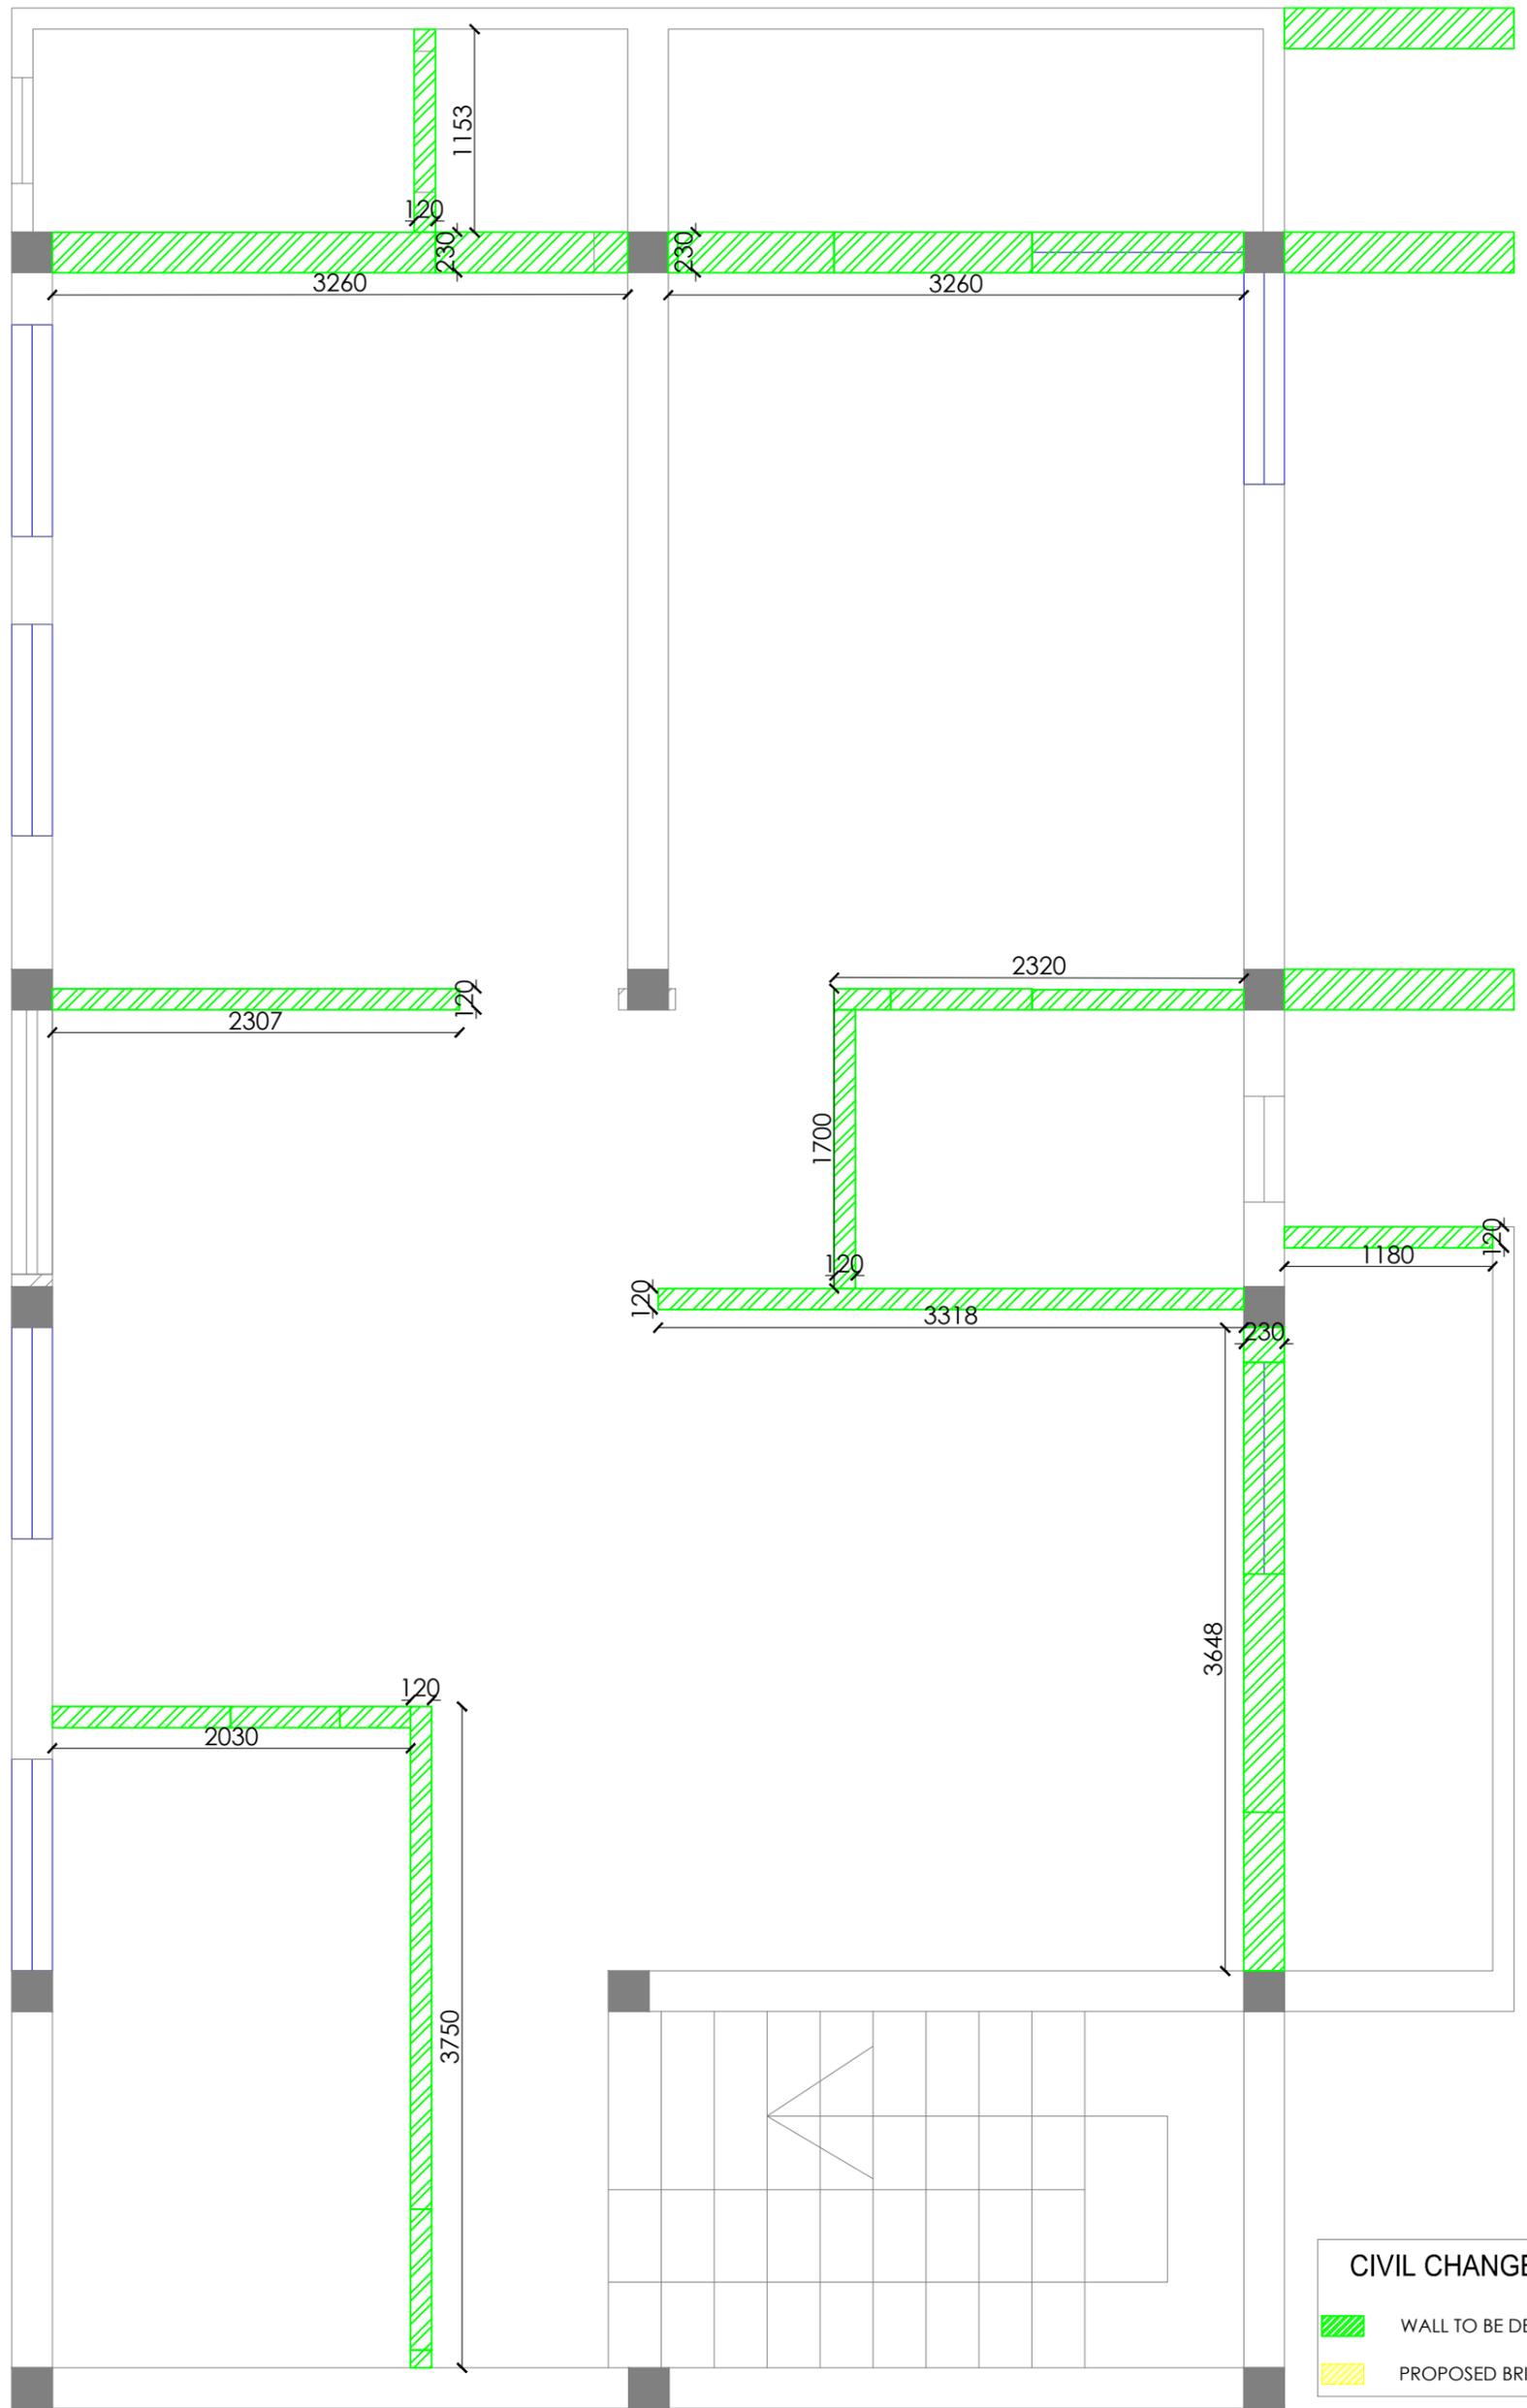

SECOND FLOOR PLAN

Client	BPCL	Project Title	PROPOSED INTERIORS FOR BPCL TERRITORY OFFICE @ VIJAYAWADA		Drawing Title	DEMOLITION LAYOUT		Dwg No	BPCL_TO_TD-001
GENERAL NOTE: 1. DRAWING TO BE USED ONLY FOR THE PURPOSE RELEASED. 2. DO NOT SCALE THIS DRAWING, ONLY WRITTEN DIMENSIONS TO BE FOLLOWED. 3. ANY DISCREPANCY IN THE DRAWING SHOULD BE IMMEDIATELY BROUGHT TO THE NOTICE OF ARCHITECT.		REV	DESCRIPTION	BY	DATE	Drawn	KARTHIK		Architects  New Designer Web Pvt Ltd No.185, 2nd Floor, 1st Main road, Nehru nagar, Kandanchavadi, Perungudi, Chennai - 600096 Tel: +91- 044 - 4212511 www.designerweb.in
						Checked	VYOM		
						Approved	VYOM		
						Date	23.01.2024		
						Issued for	ISSUEDFORTENDER		

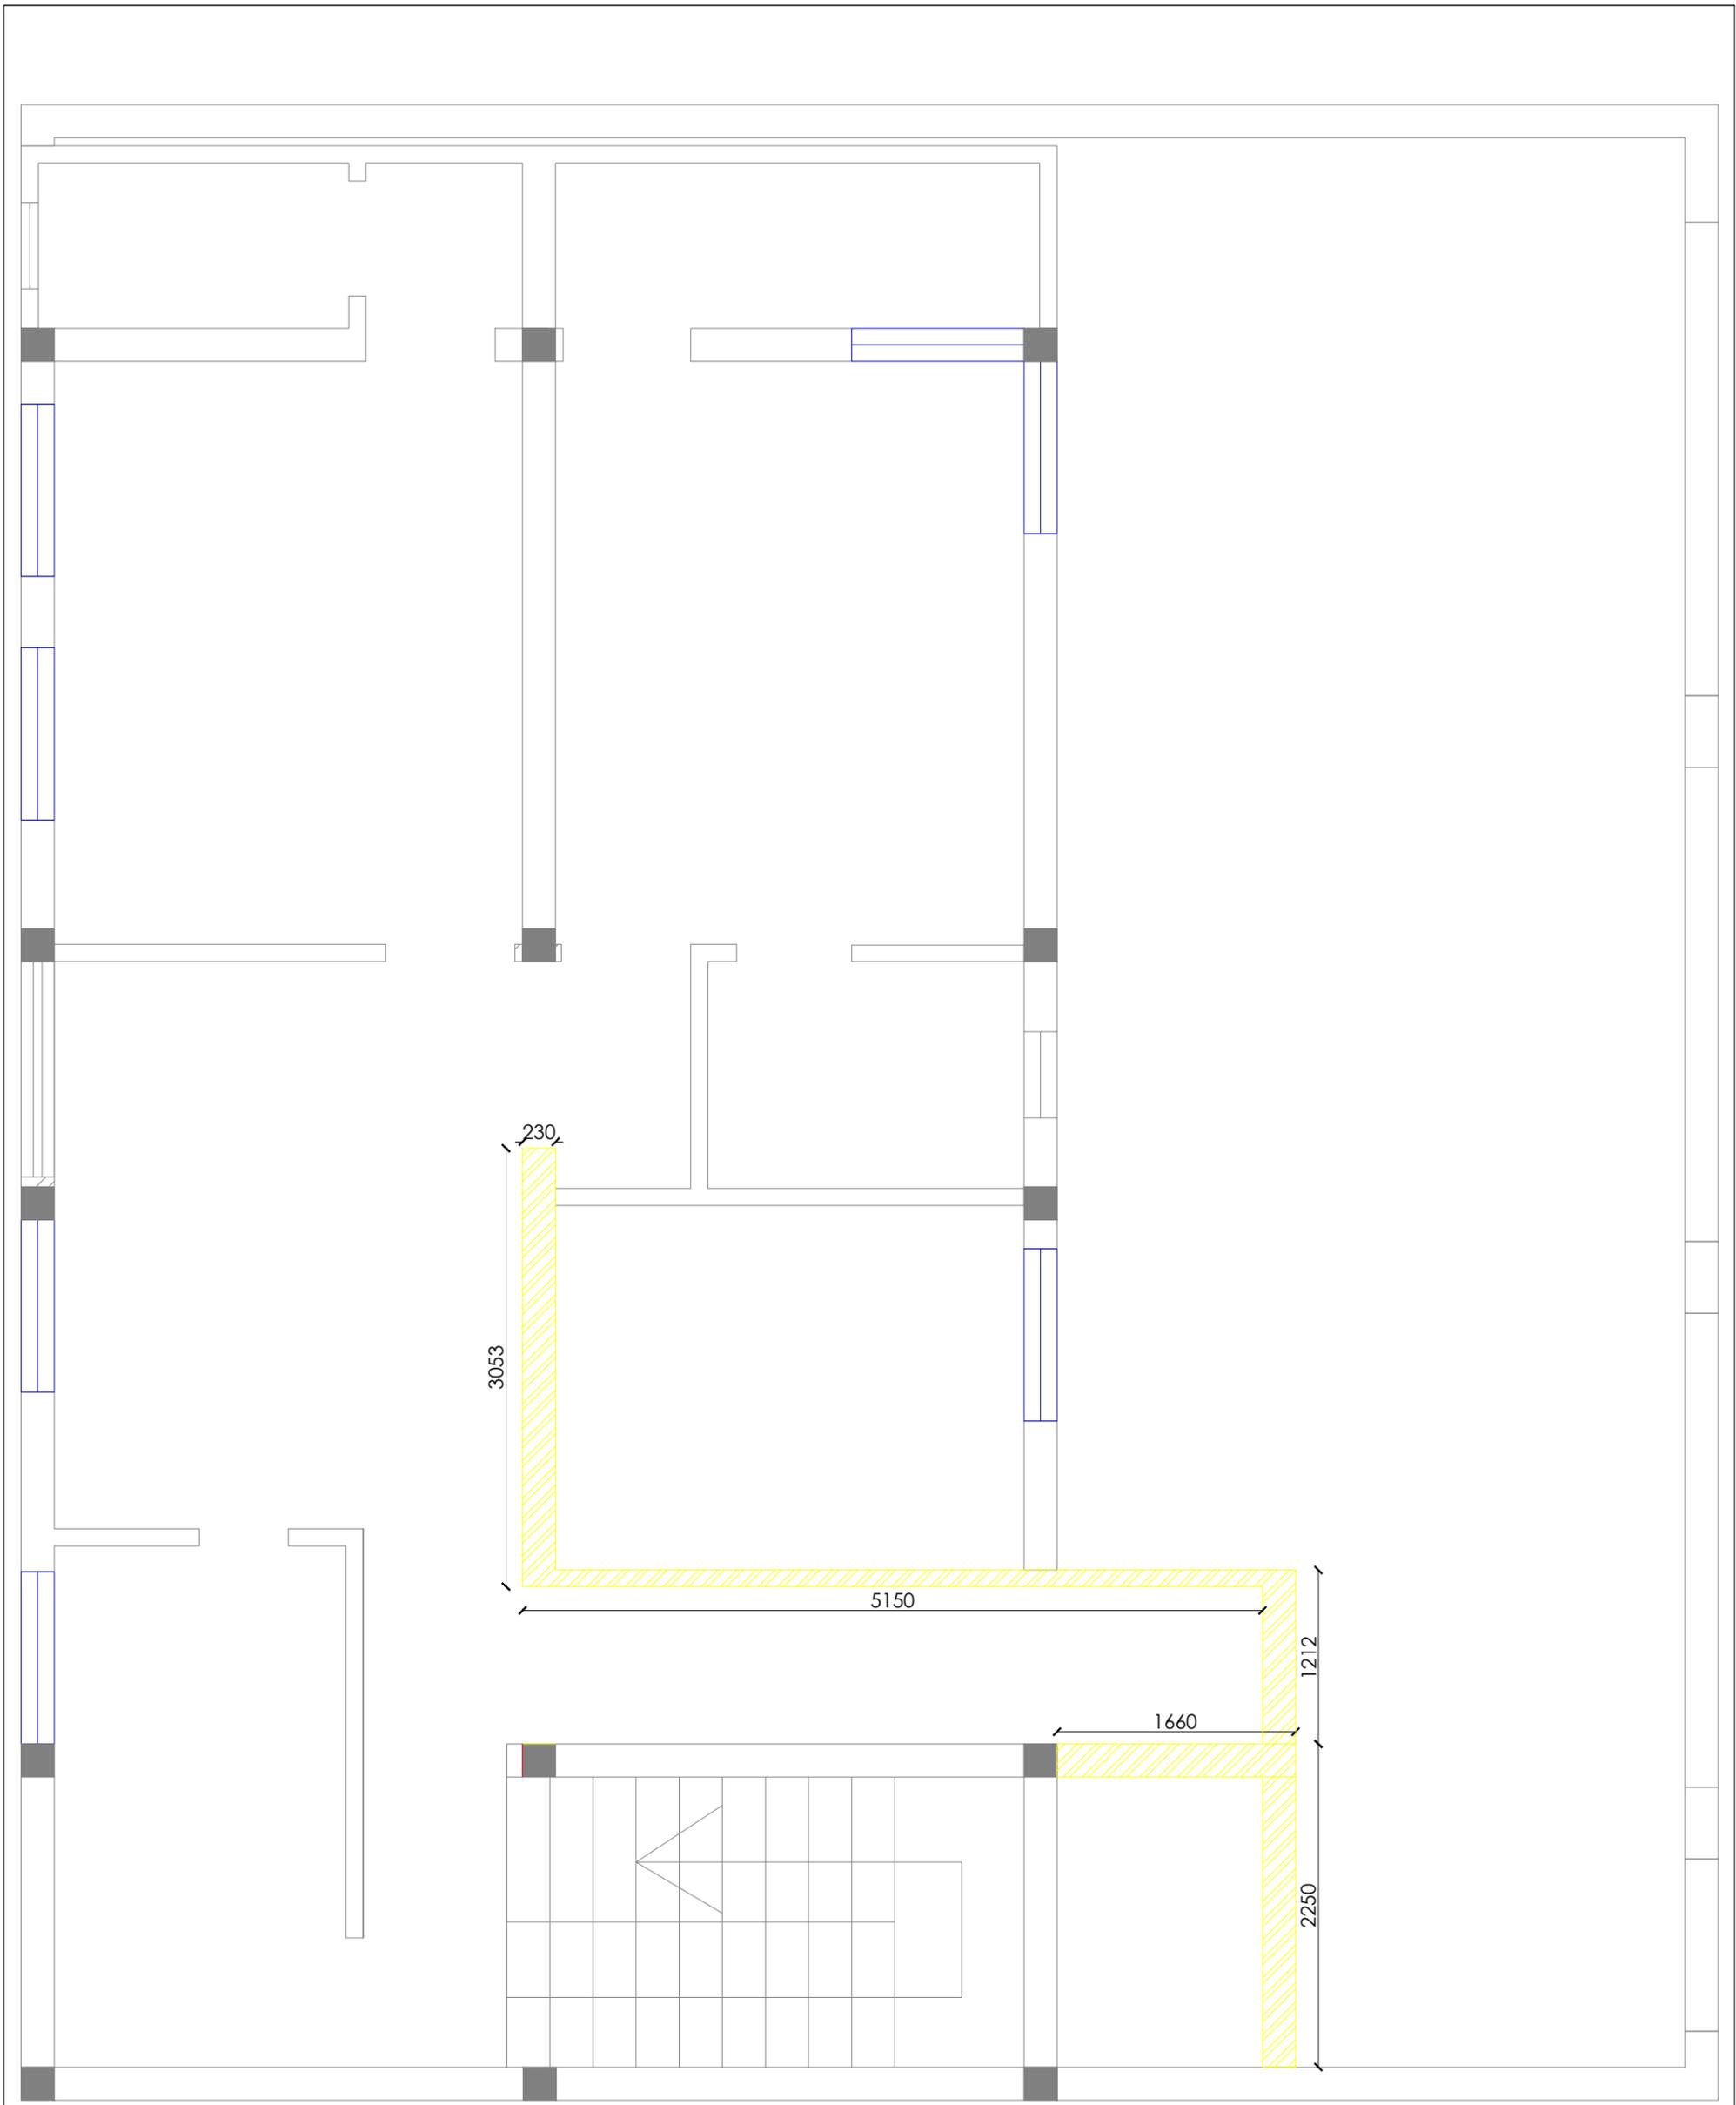


GROUND FLOOR PLAN

CIVIL CHANGES LEGEND

 WALL TO BE DEMOLISHED


 PROPOSED BRICK WALL

Client	BPCL	Project Title	PROPOSED INTERIORS FOR BPCL TERRITORY OFFICE @ VIJAYAWADA		Drawing Title	CIVIL CONSTRUCTION LAYOUT		Dwg No	BPCL_TO_ID-002
GENERAL NOTE: 1. DRAWING TO BE USED ONLY FOR THE PURPOSE RELEASED. 2. DO NOT SCALE THIS DRAWING, ONLY WRITTEN DIMENSIONS TO BE FOLLOWED. 3. ANY DISCREPANCY IN THE DRAWING SHOULD BE IMMEDIATELY BROUGHT TO THE NOTICE OF ARCHITECT.		REV	DESCRIPTION	BY	DATE	Drawn	KARTHIK		Architects  New Designer Web Pvt Ltd No.185, 2nd Floor, 1st Main road, Nehru nagar, Kandanchavadi, Perungudi, Chennai - 600096 Tel: +91- 044 - 4212511www.designerweb.in
						Checked	VYOM		
						Approved	VYOM		
						Date	23.01.2024		
						Issued for	ISSUEDFORTENDER		

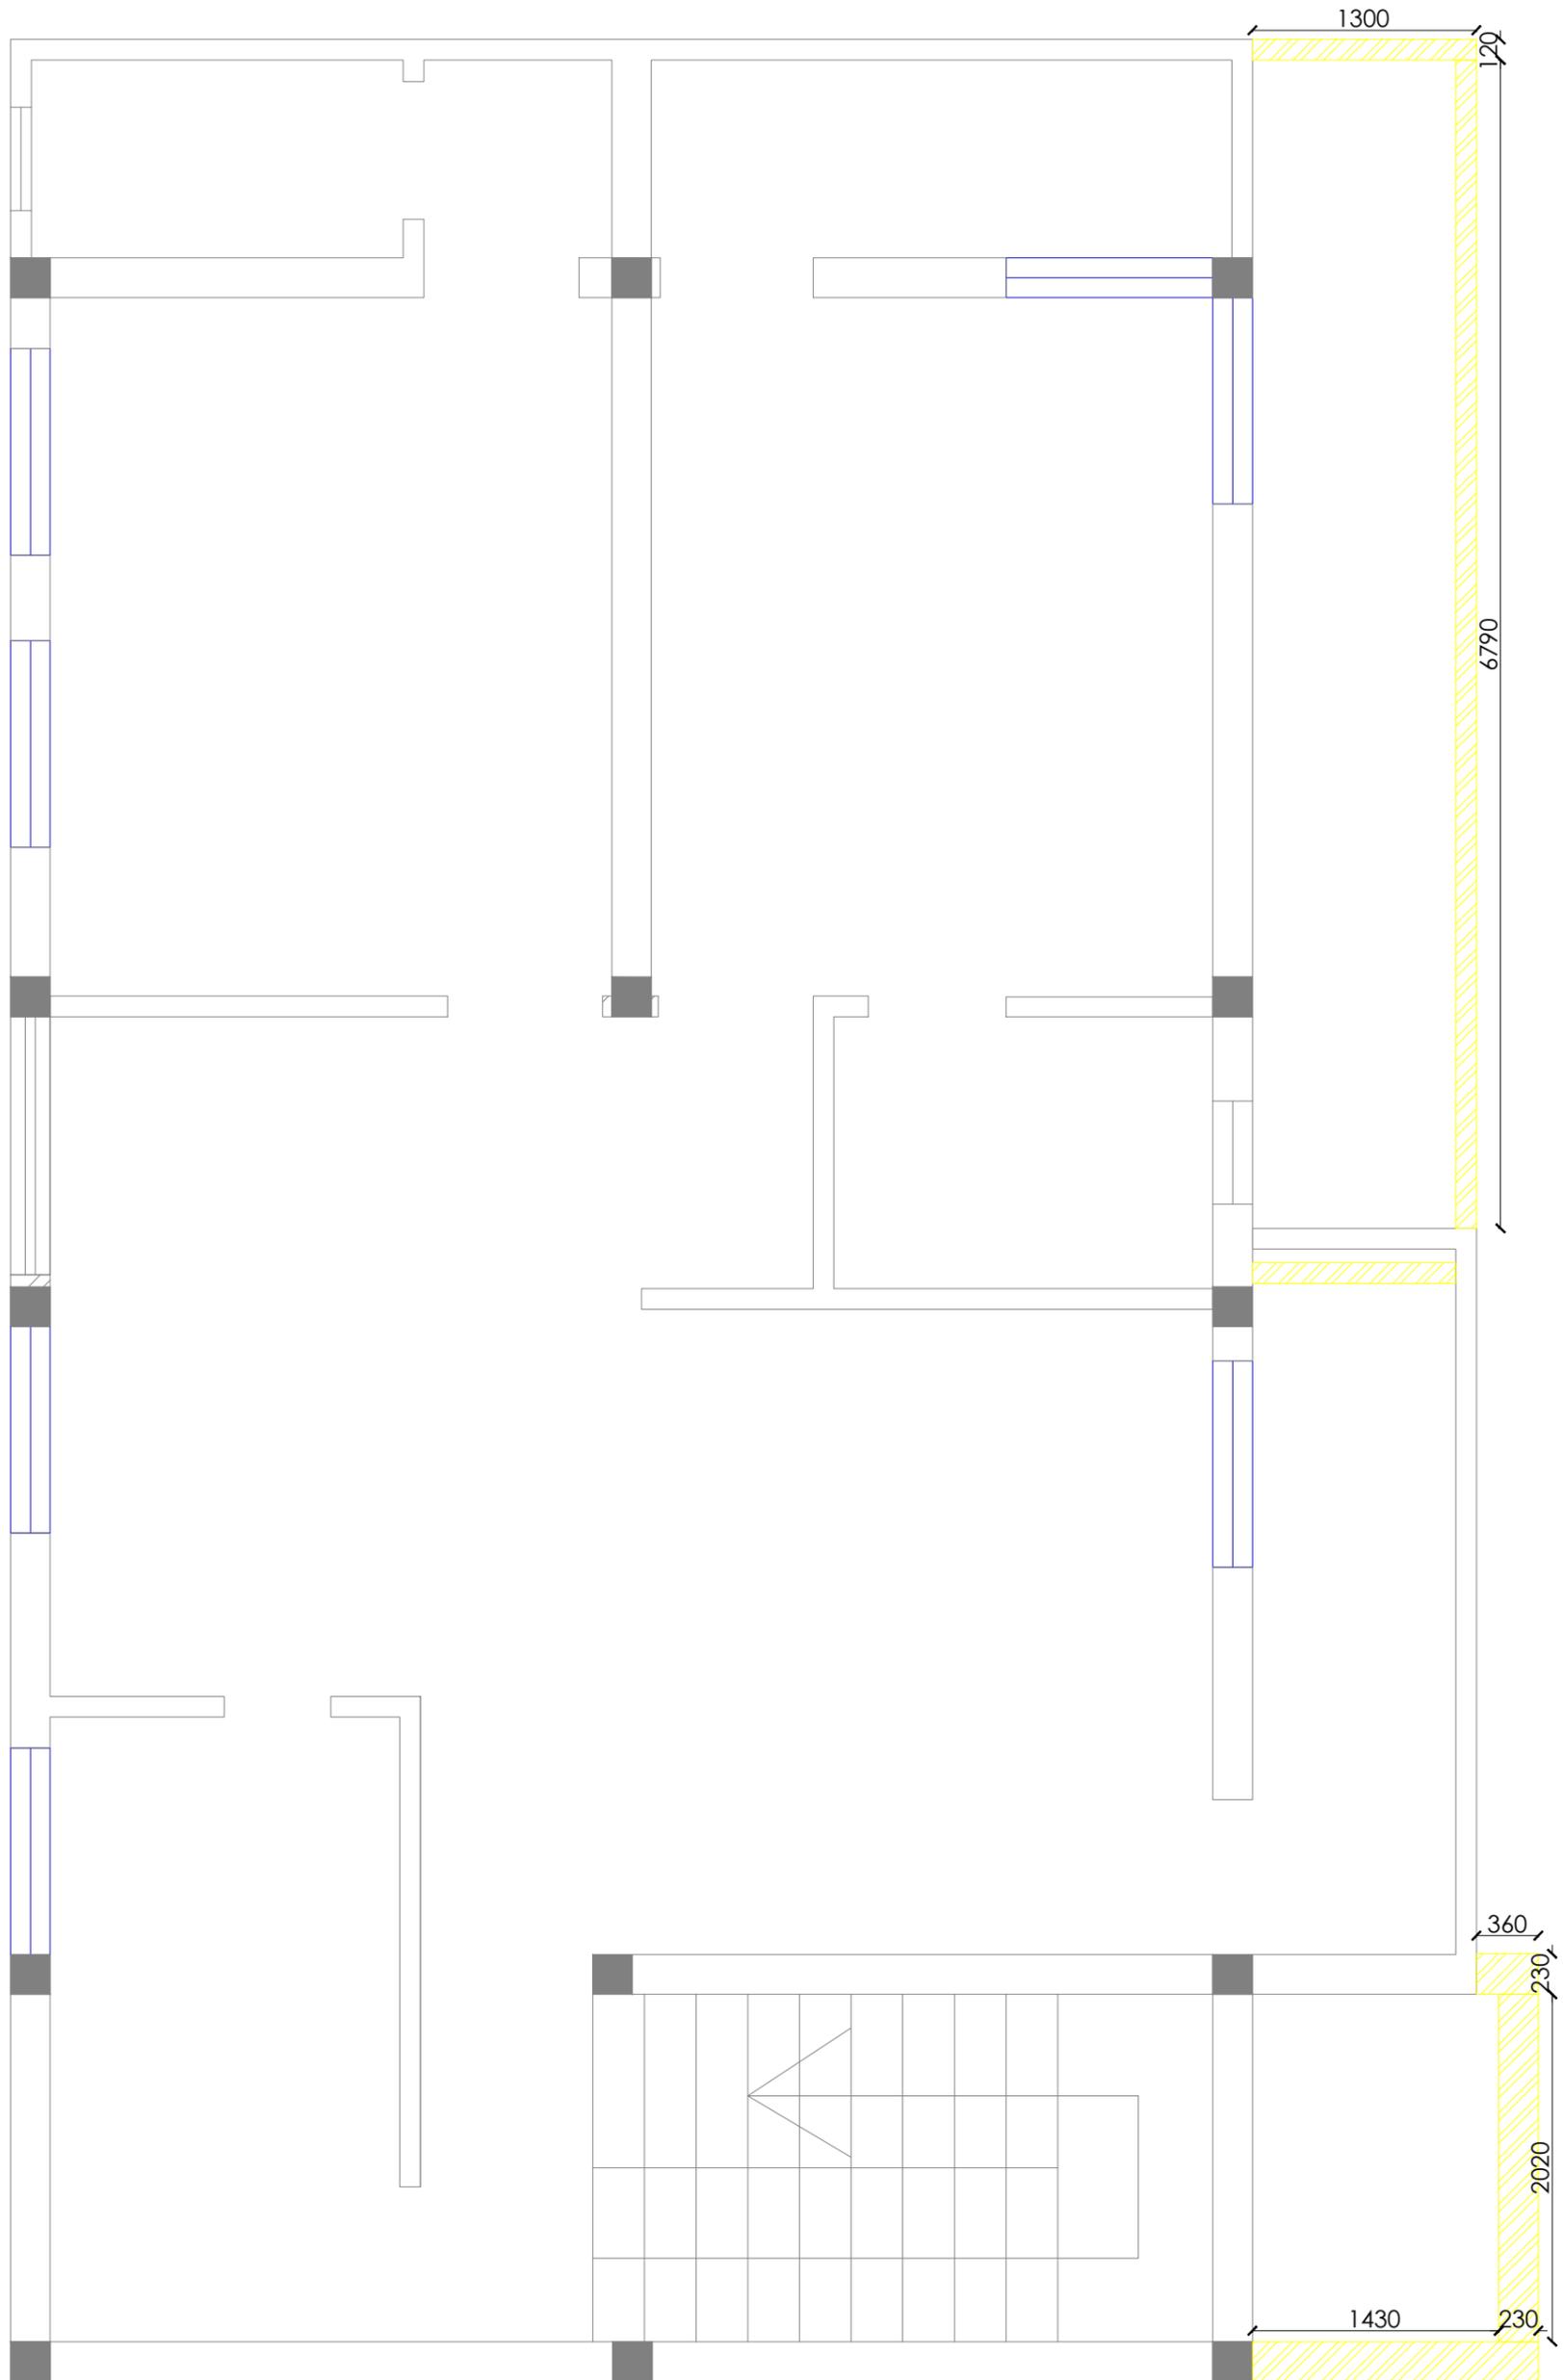


FIRST FLOOR PLAN

Client	BPCL	Project Title	PROPOSED INTERIORS FOR BPCL TERRITORY OFFICE @ VIJAYAWADA		Drawing Title	CIVIL CONSTRUCTION LAYOUT		Dwg No	BPCL_TO_TD-002
GENERAL NOTE: 1. DRAWING TO BE USED ONLY FOR THE PURPOSE RELEASED. 2. DO NOT SCALE THIS DRAWING, ONLY WRITTEN DIMENSIONS TO BE FOLLOWED. 3. ANY DISCREPANCY IN THE DRAWING SHOULD BE IMMEDIATELY BROUGHT TO THE NOTICE OF ARCHITECT.		REV	DESCRIPTION	BY	DATE	Drawn	KARTHIK		Architects New Designer Web Pvt Ltd No.185, 2nd Floor, 1st Main road, Nehru nagar, Kandanchavadi, Perungudi, Chennai - 600096 Tel: +91- 044 - 4212511 www.designerweb.in
						Checked	VYOM		
						Approved	VYOM		
						Date	23.01.2024		
						Issued for	ISSUEDFORTENDER		

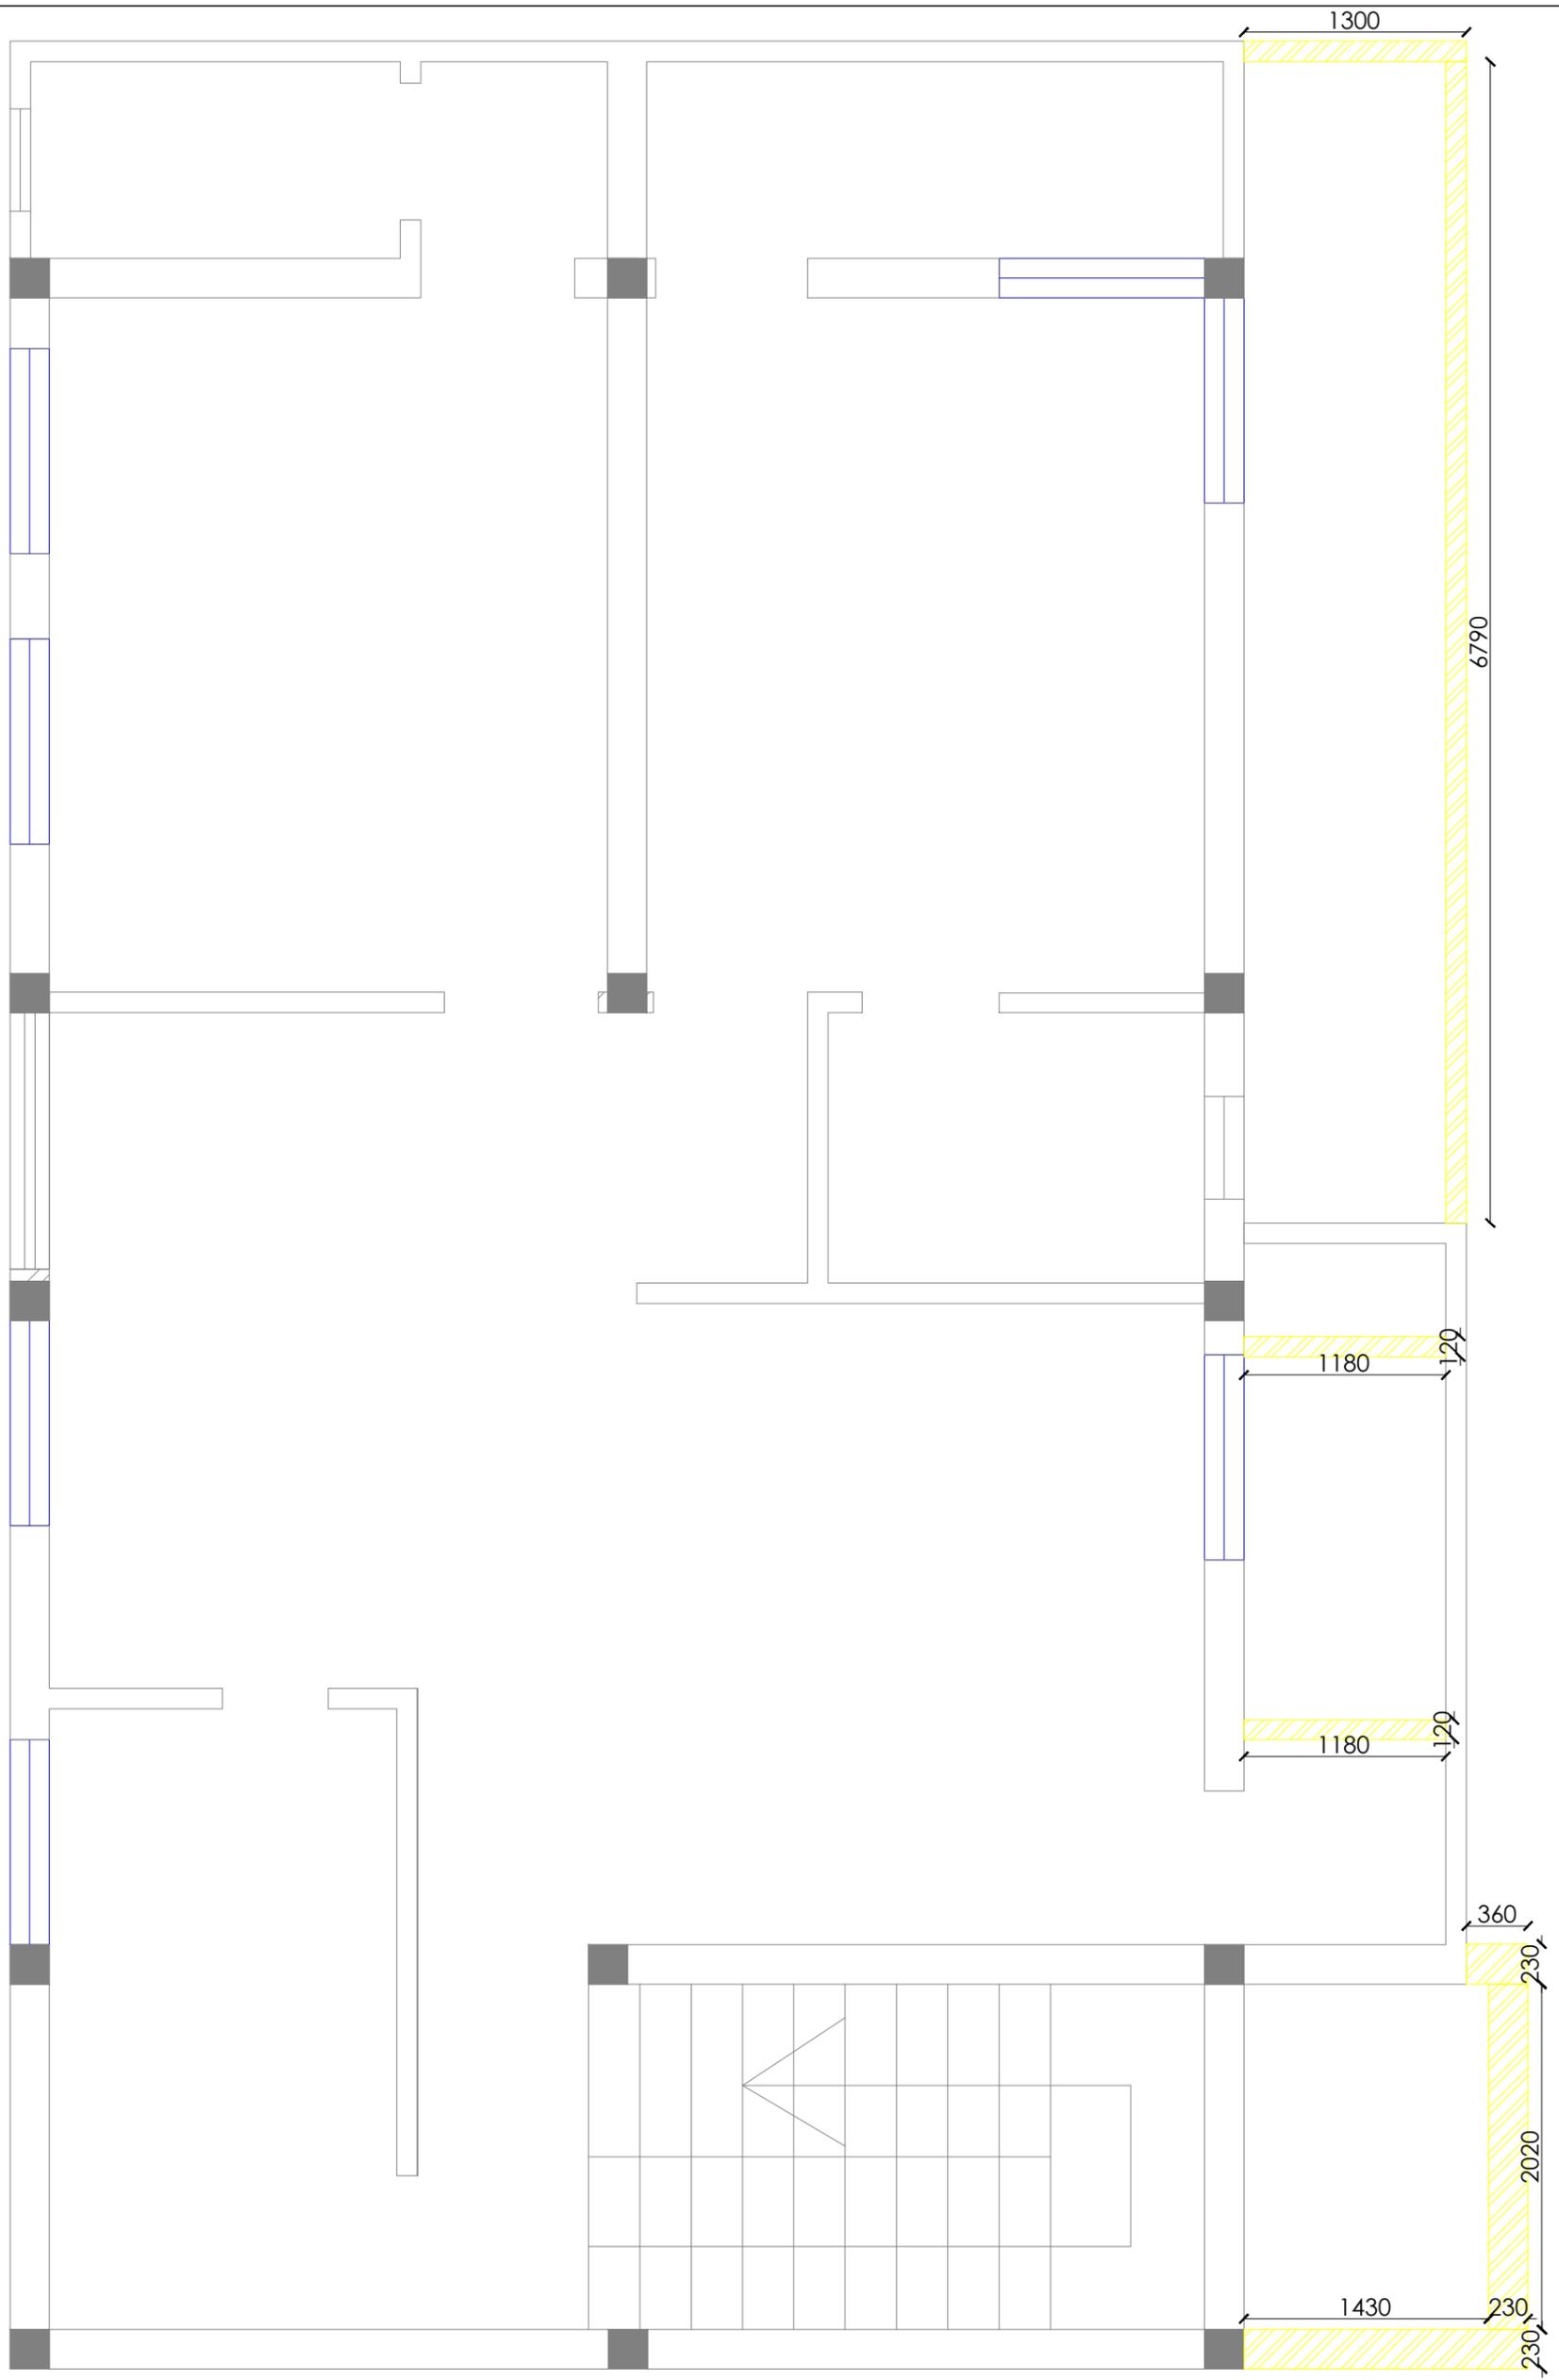


SECOND FLOOR PLAN

Client	BPCL	Project Title	PROPOSED INTERIORS FOR BPCL TERRITORY OFFICE @ VIJAYAWADA		Drawing Title	CIVIL CONSTRUCTION LAYOUT		Dwg No	BPCL_TO_TD-002
GENERAL NOTE: 1. DRAWING TO BE USED ONLY FOR THE PURPOSE RELEASED. 2. DO NOT SCALE THIS DRAWING, ONLY WRITTEN DIMENSIONS TO BE FOLLOWED. 3. ANY DISCREPANCY IN THE DRAWING SHOULD BE IMMEDIATELY BROUGHT TO THE NOTICE OF ARCHITECT.		REV	DESCRIPTION	BY	DATE	Drawn	KARTHIK		Architects  New Designer Web Pvt Ltd No.185, 2nd Floor, 1st Main road, Nehru nagar, Kandanchavadi, Perungudi, Chennai - 600096 Tel: +91- 044 - 4212511www.designerweb.in
						Checked	VYOM		
						Approved	VYOM		
						Date	23.01.2024		
						Issued for	ISSUEDFORTENDER		

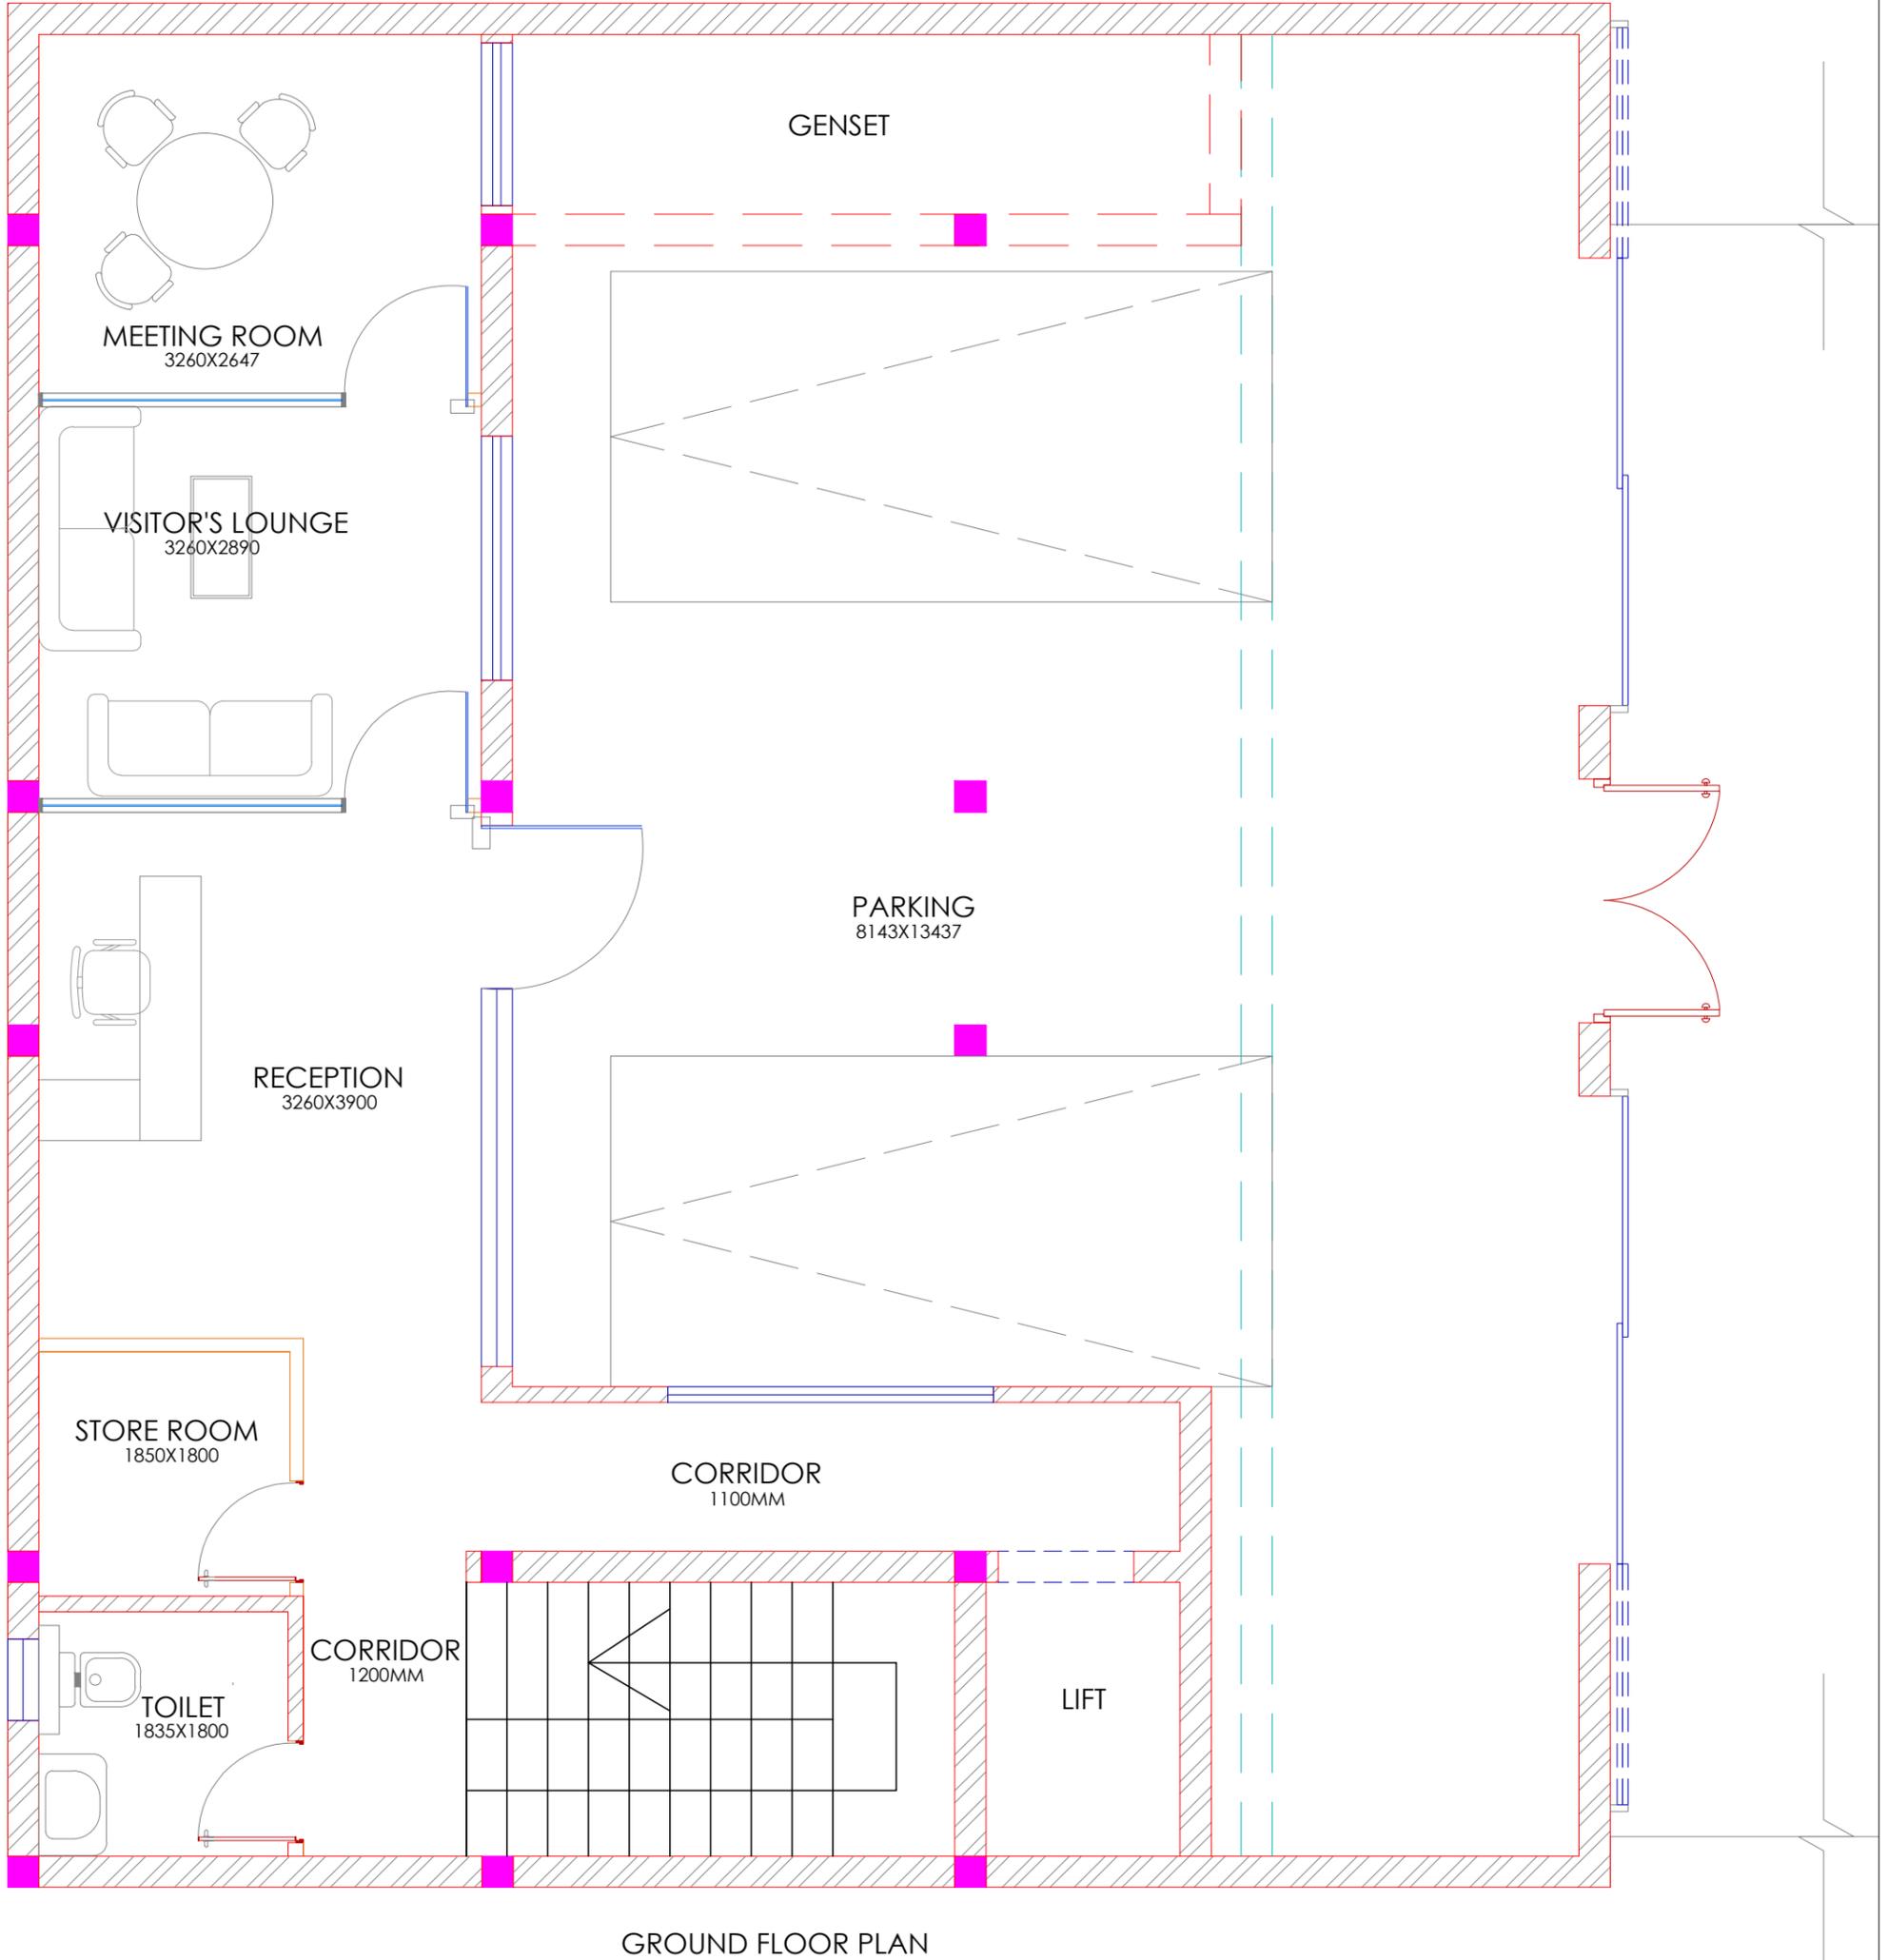


Client	BPCL	Project Title	PROPOSED INTERIORS FOR BPCL TERRITORY OFFICE @ VIJAYAWADA		Drawing Title	INTERIOR LAYOUT		Dwg No	BPCL_TO_ID-003	
GENERAL NOTE: 1. DRAWING TO BE USED ONLY FOR THE PURPOSE RELEASED. 2. DO NOT SCALE THIS DRAWING, ONLY WRITTEN DIMENSIONS TO BE FOLLOWED. 3. ANY DISCREPANCY IN THE DRAWING SHOULD BE IMMEDIATELY BROUGHT TO THE NOTICE OF ARCHITECT.		REV	DESCRIPTION	BY	DATE	Drawn	KARTHIK		 Architects New Designer Web Pvt Ltd <small>No.185, 2nd Floor, 1st Main road, Nehru nagar, Kandanchavadi, Perungudi, Chennai - 600096 Tel: +91- 044 - 4212511 www.designerweb.in</small>	
		01	GF - New corridor for lift, new toilet	KARTHIK	24.05.2024	Checked	VYOM			
		02	FF,SF - Workstation changed to cubicle	KARTHIK	25.06.2024	Approved	VYOM			
						Date	23.01.2024			
						Issued for	ISSUEDFORTENDER	Scale		

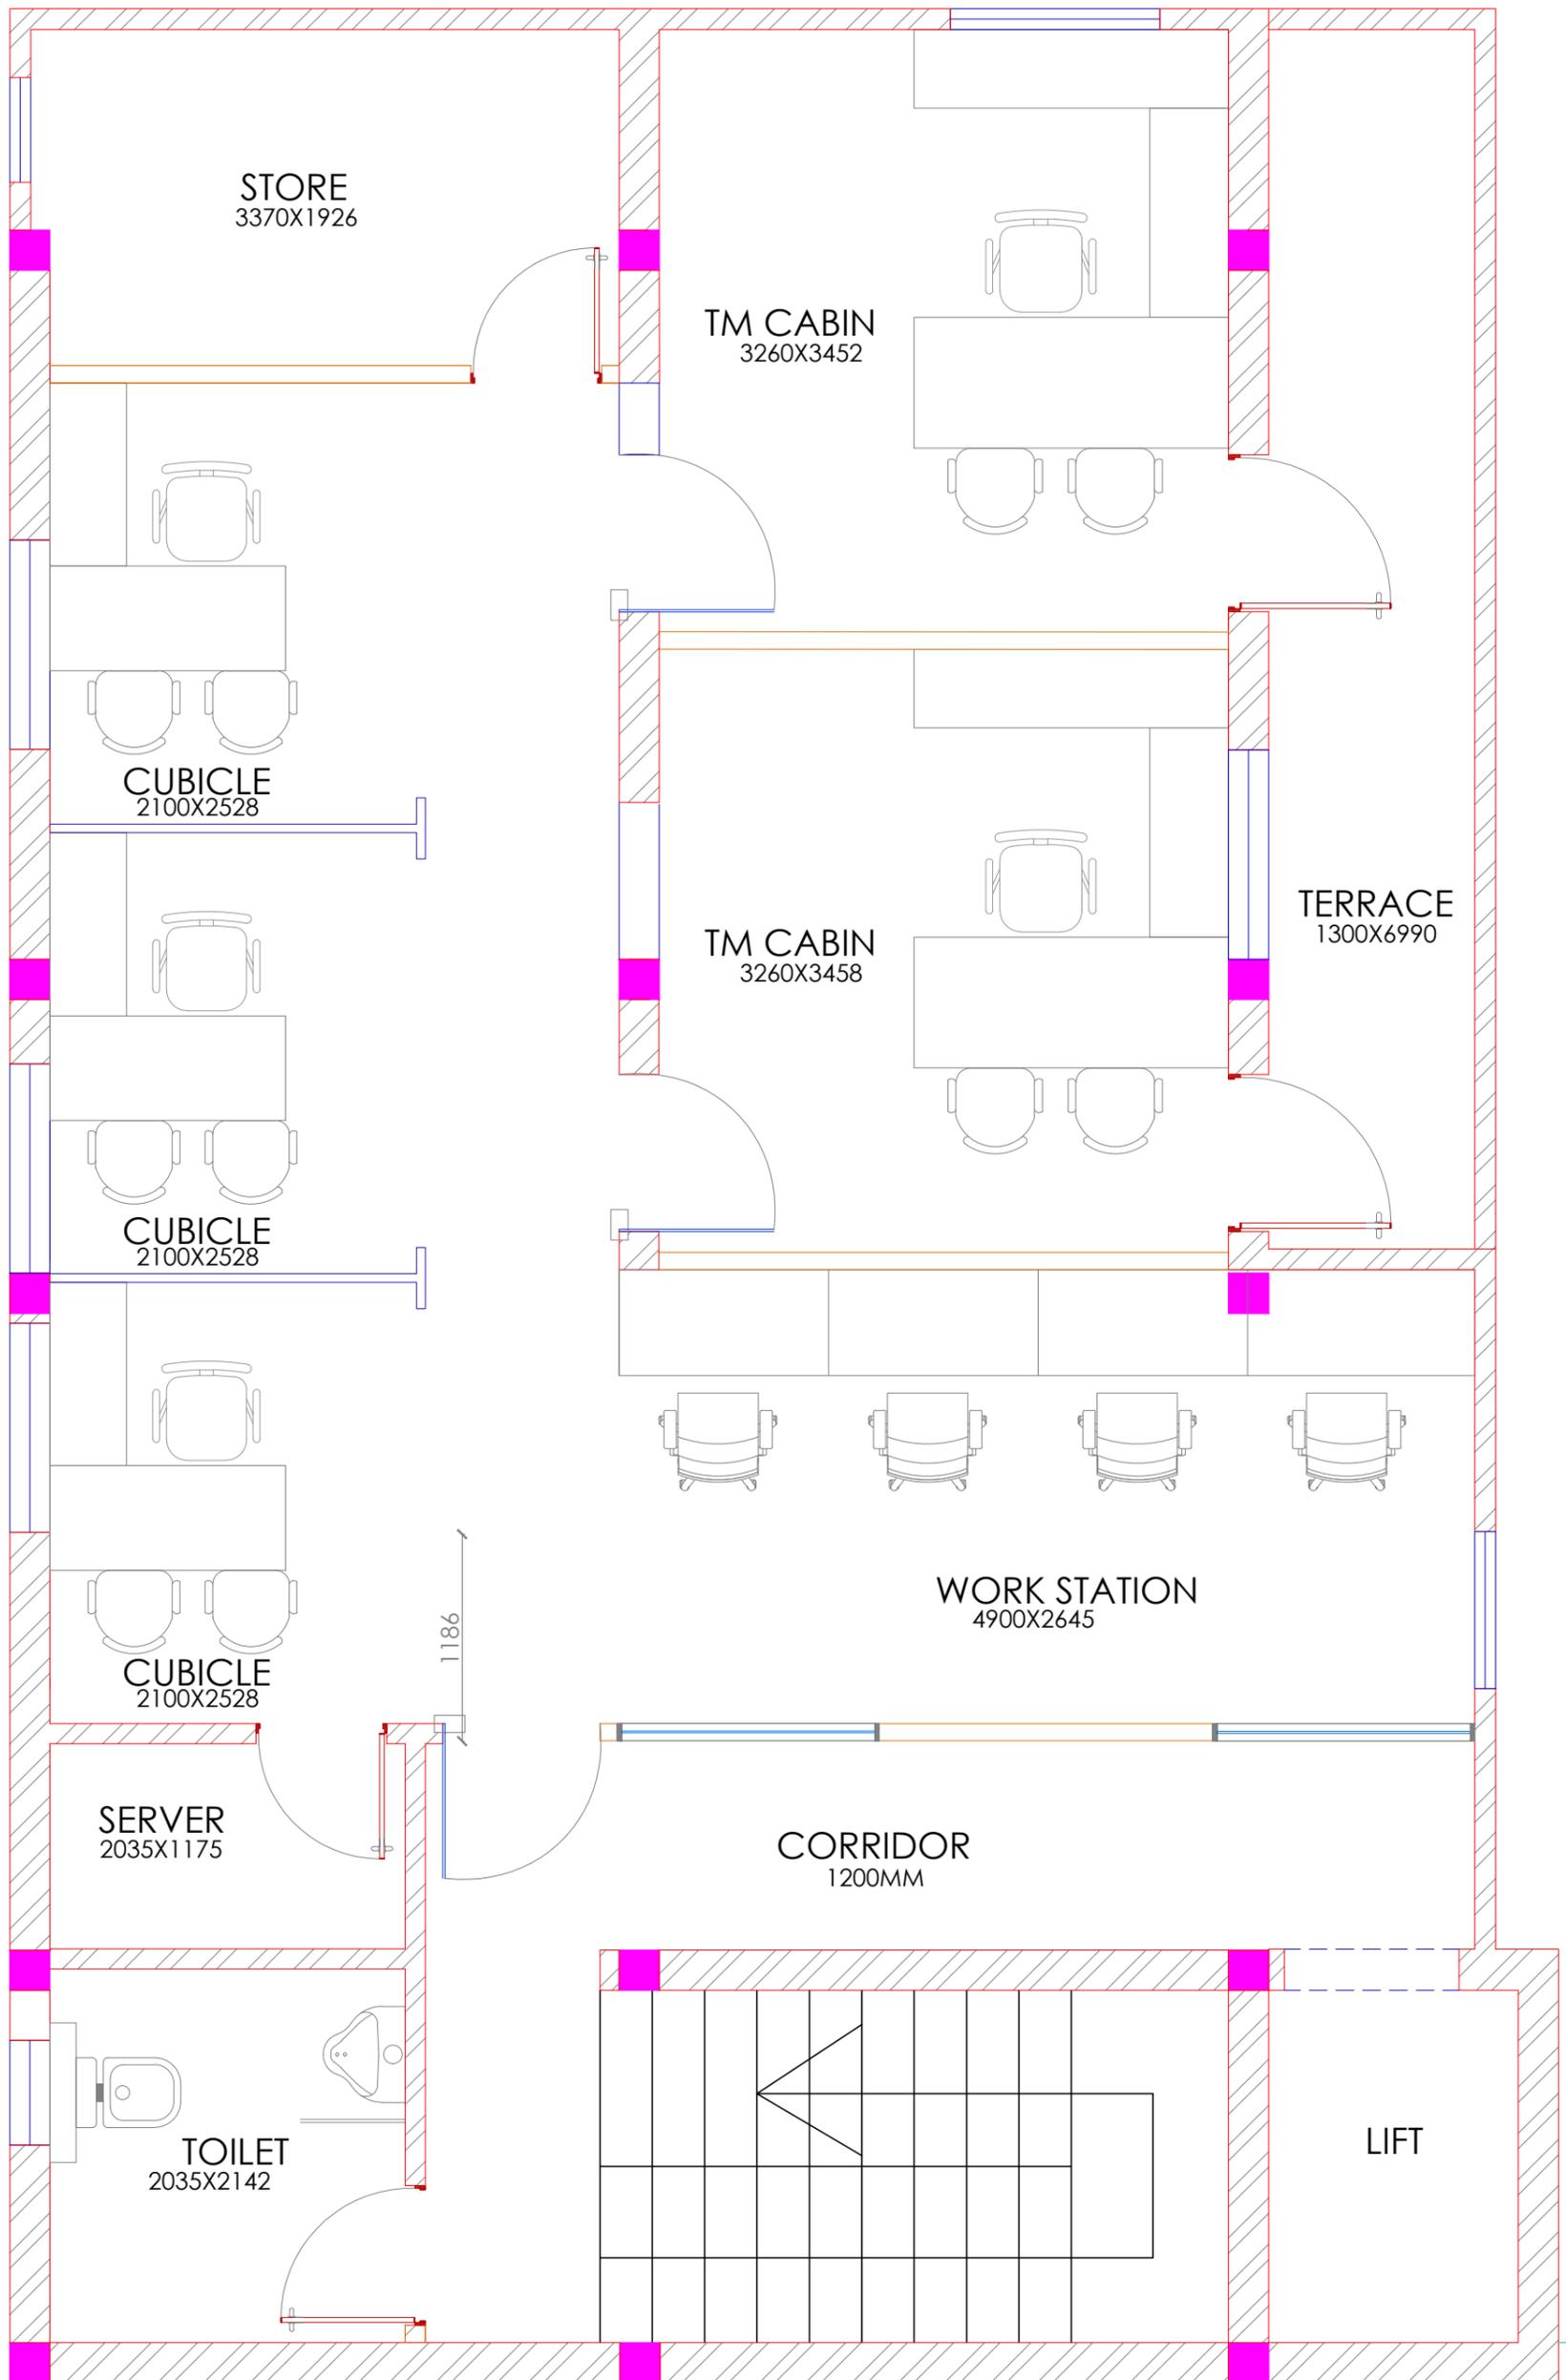


FIRST FLOOR PLAN

Client	BPCL	Project Title	PROPOSED INTERIORS FOR BPCL TERRITORY OFFICE @ VIJAYAWADA		Drawing Title	INTERIOR LAYOUT		Dwg No	BPCL_TD_T-003
GENERAL NOTE: 1. DRAWING TO BE USED ONLY FOR THE PURPOSE RELEASED. 2. DO NOT SCALE THIS DRAWING, ONLY WRITTEN DIMENSIONS TO BE FOLLOWED. 3. ANY DISCREPANCY IN THE DRAWING SHOULD BE IMMEDIATELY BROUGHT TO THE NOTICE OF ARCHITECT.		REV	DESCRIPTION	BY	DATE	Drawn	KARTHIK	 Architects New Designer Web Pvt Ltd No.185, 2nd Floor, 1st Main road, Nehru nagar, Kandanchavadi, Perungudi, Chennai - 600096 Tel: +91- 044 - 42125111www.designerweb.in	
		01	GF - New corridor for lift, new toilet			Checked	VYOM		
		02	FF,SF - Workstation changed to cubicle			Approved	VYOM		
						Date	23.01.2024		
						Issued for	ISSUEDFORTENDER		

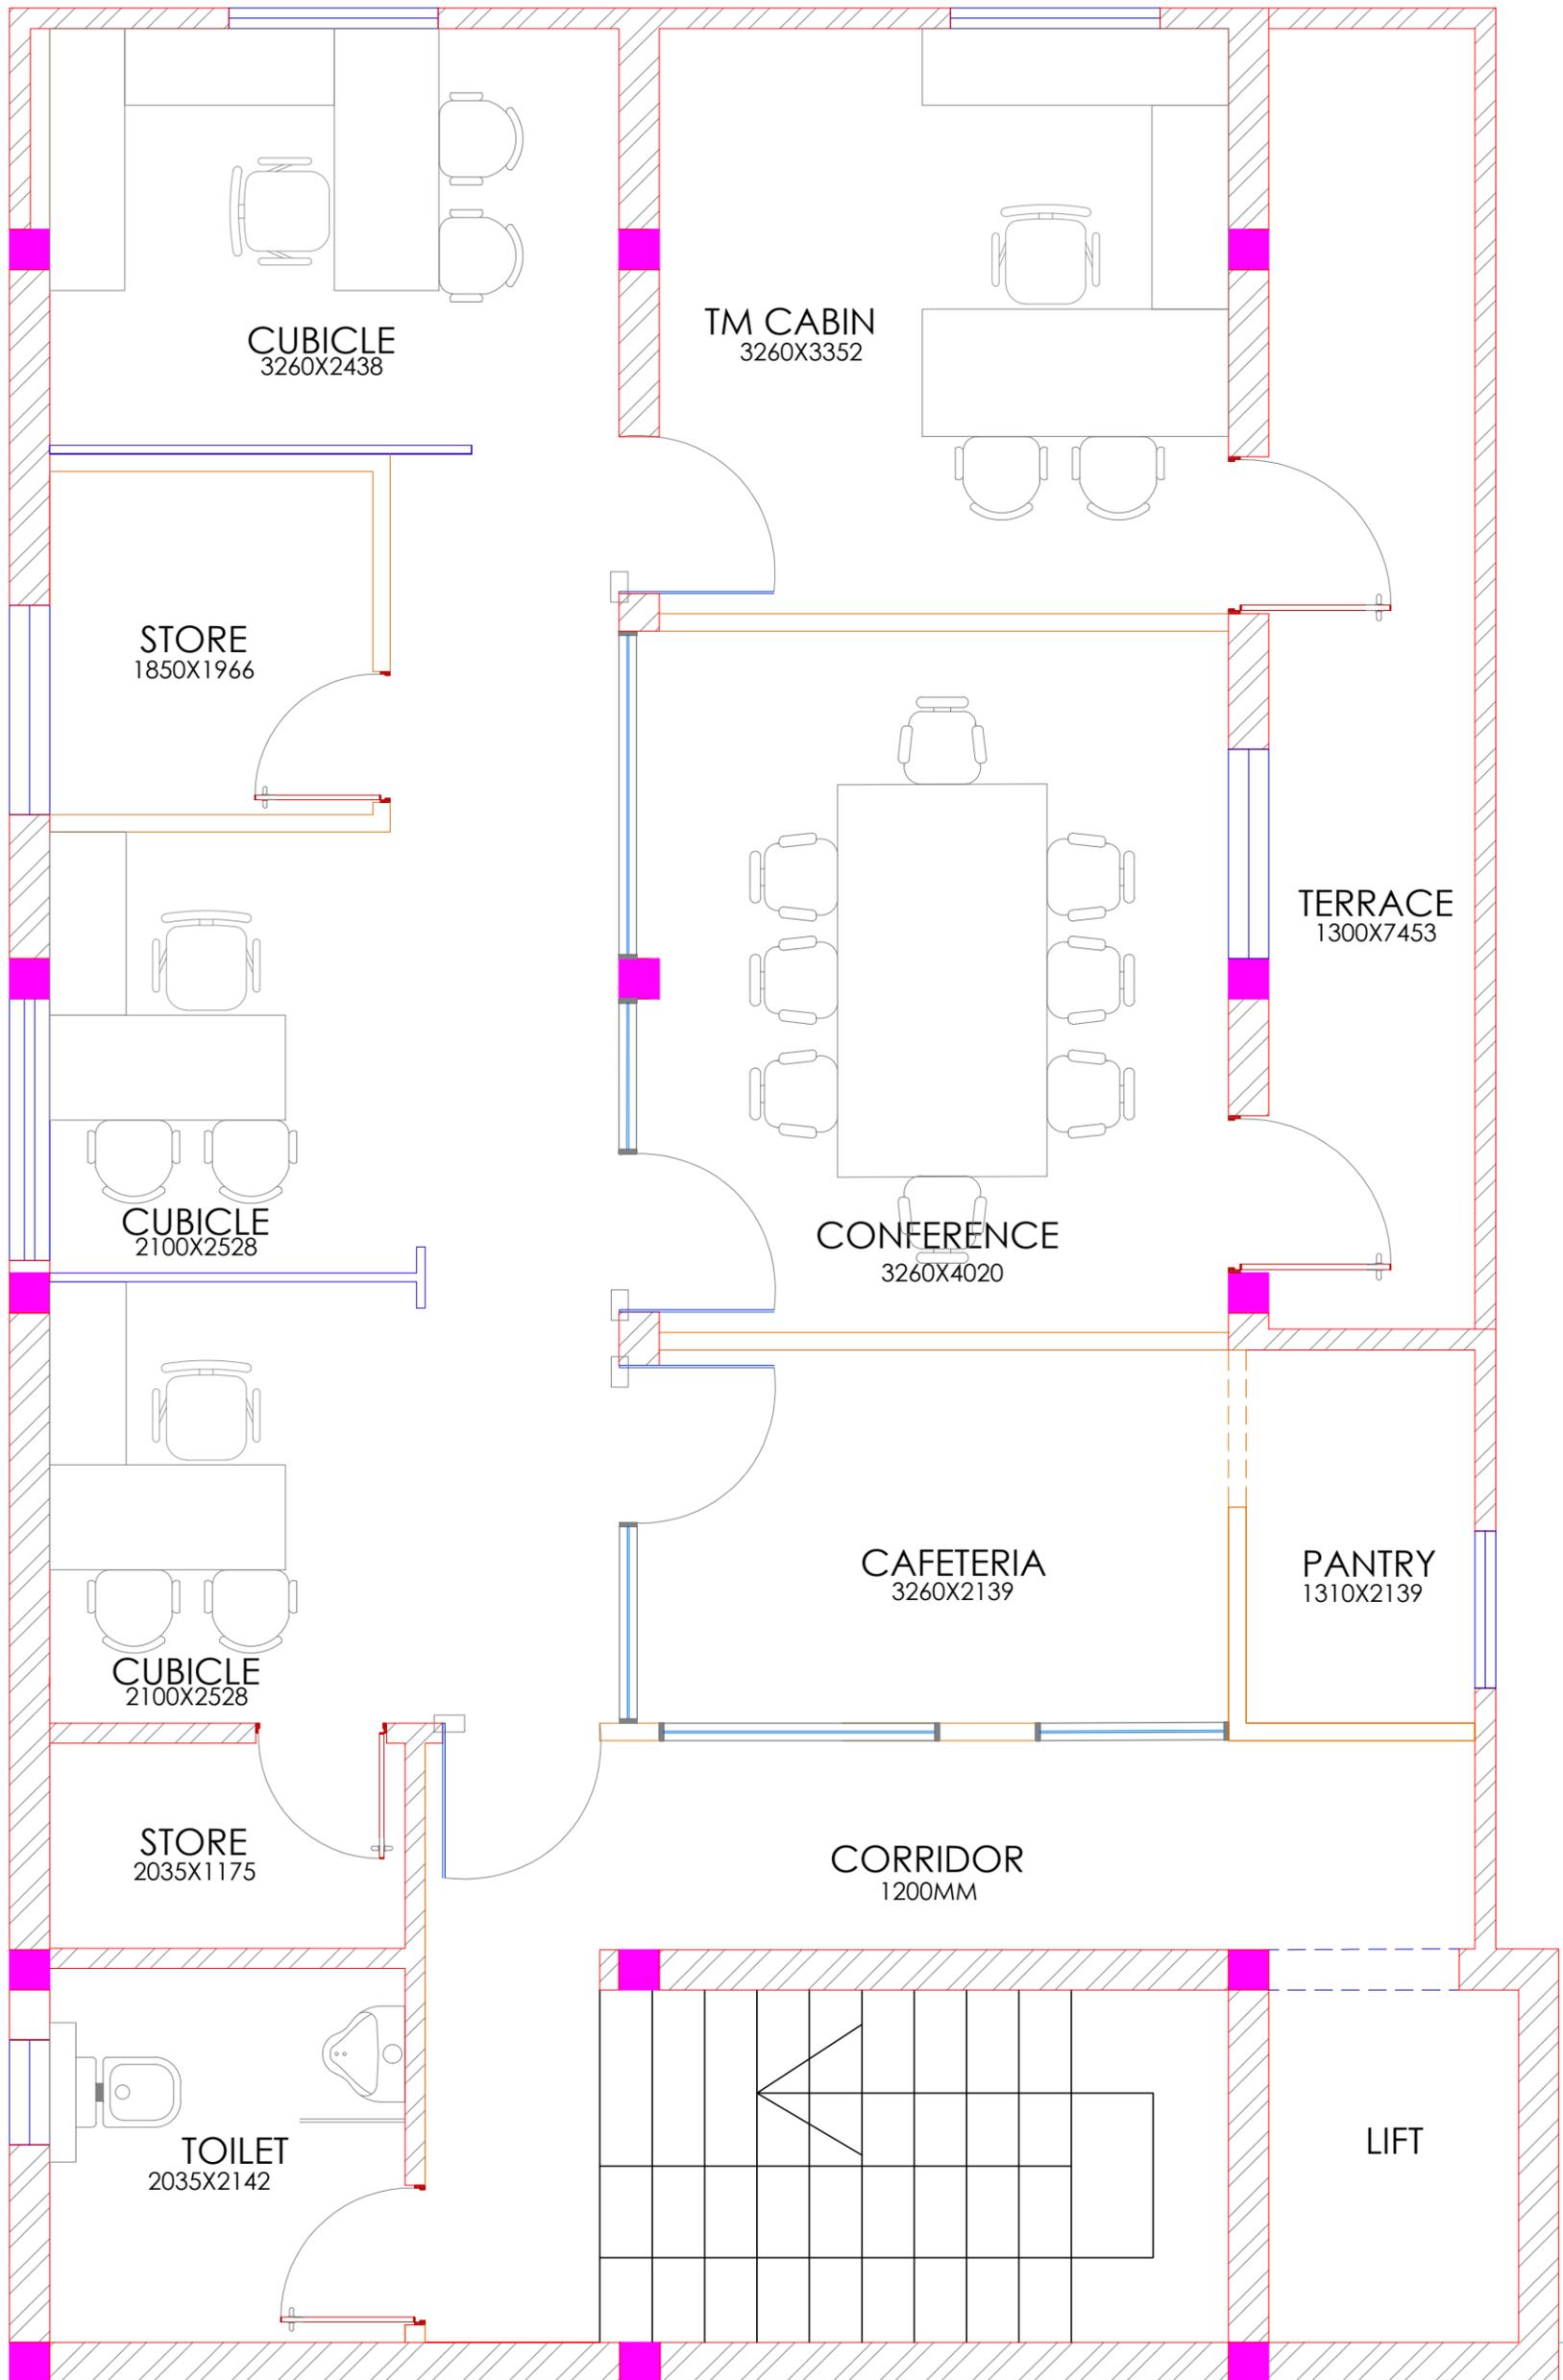

SECOND FLOOR PLAN


Client	BPCL	Project Title	PROPOSED INTERIORS FOR BPCL TERRITORY OFFICE @ VIJAYAWADA		Drawing Title	INTERIOR LAYOUT		Dwg No	BPCL_TO_ID-003
GENERAL NOTE: 1. DRAWING TO BE USED ONLY FOR THE PURPOSE RELEASED. 2. DO NOT SCALE THIS DRAWING, ONLY WRITTEN DIMENSIONS TO BE FOLLOWED. 3. ANY DISCREPANCY IN THE DRAWING SHOULD BE IMMEDIATELY BROUGHT TO THE NOTICE OF ARCHITECT.		REV	DESCRIPTION	BY	DATE	Drawn	KARTHIK	 Architects New Designer Web Pvt Ltd No.185, 2nd Floor, 1st Main road, Nehru nagar, Kandanchavadi, Perungudi, Chennai - 600096 Tel: +91- 044 - 42125111www.designerweb.in	
		01	GF - New corridor for lift, new toilet			Checked	VYOM		
		02	FF,SF - Workstation changed to cubicle			Approved	VYOM		
						Date	23.01.2024		
						Issued for	ISSUEDFORTENDER		

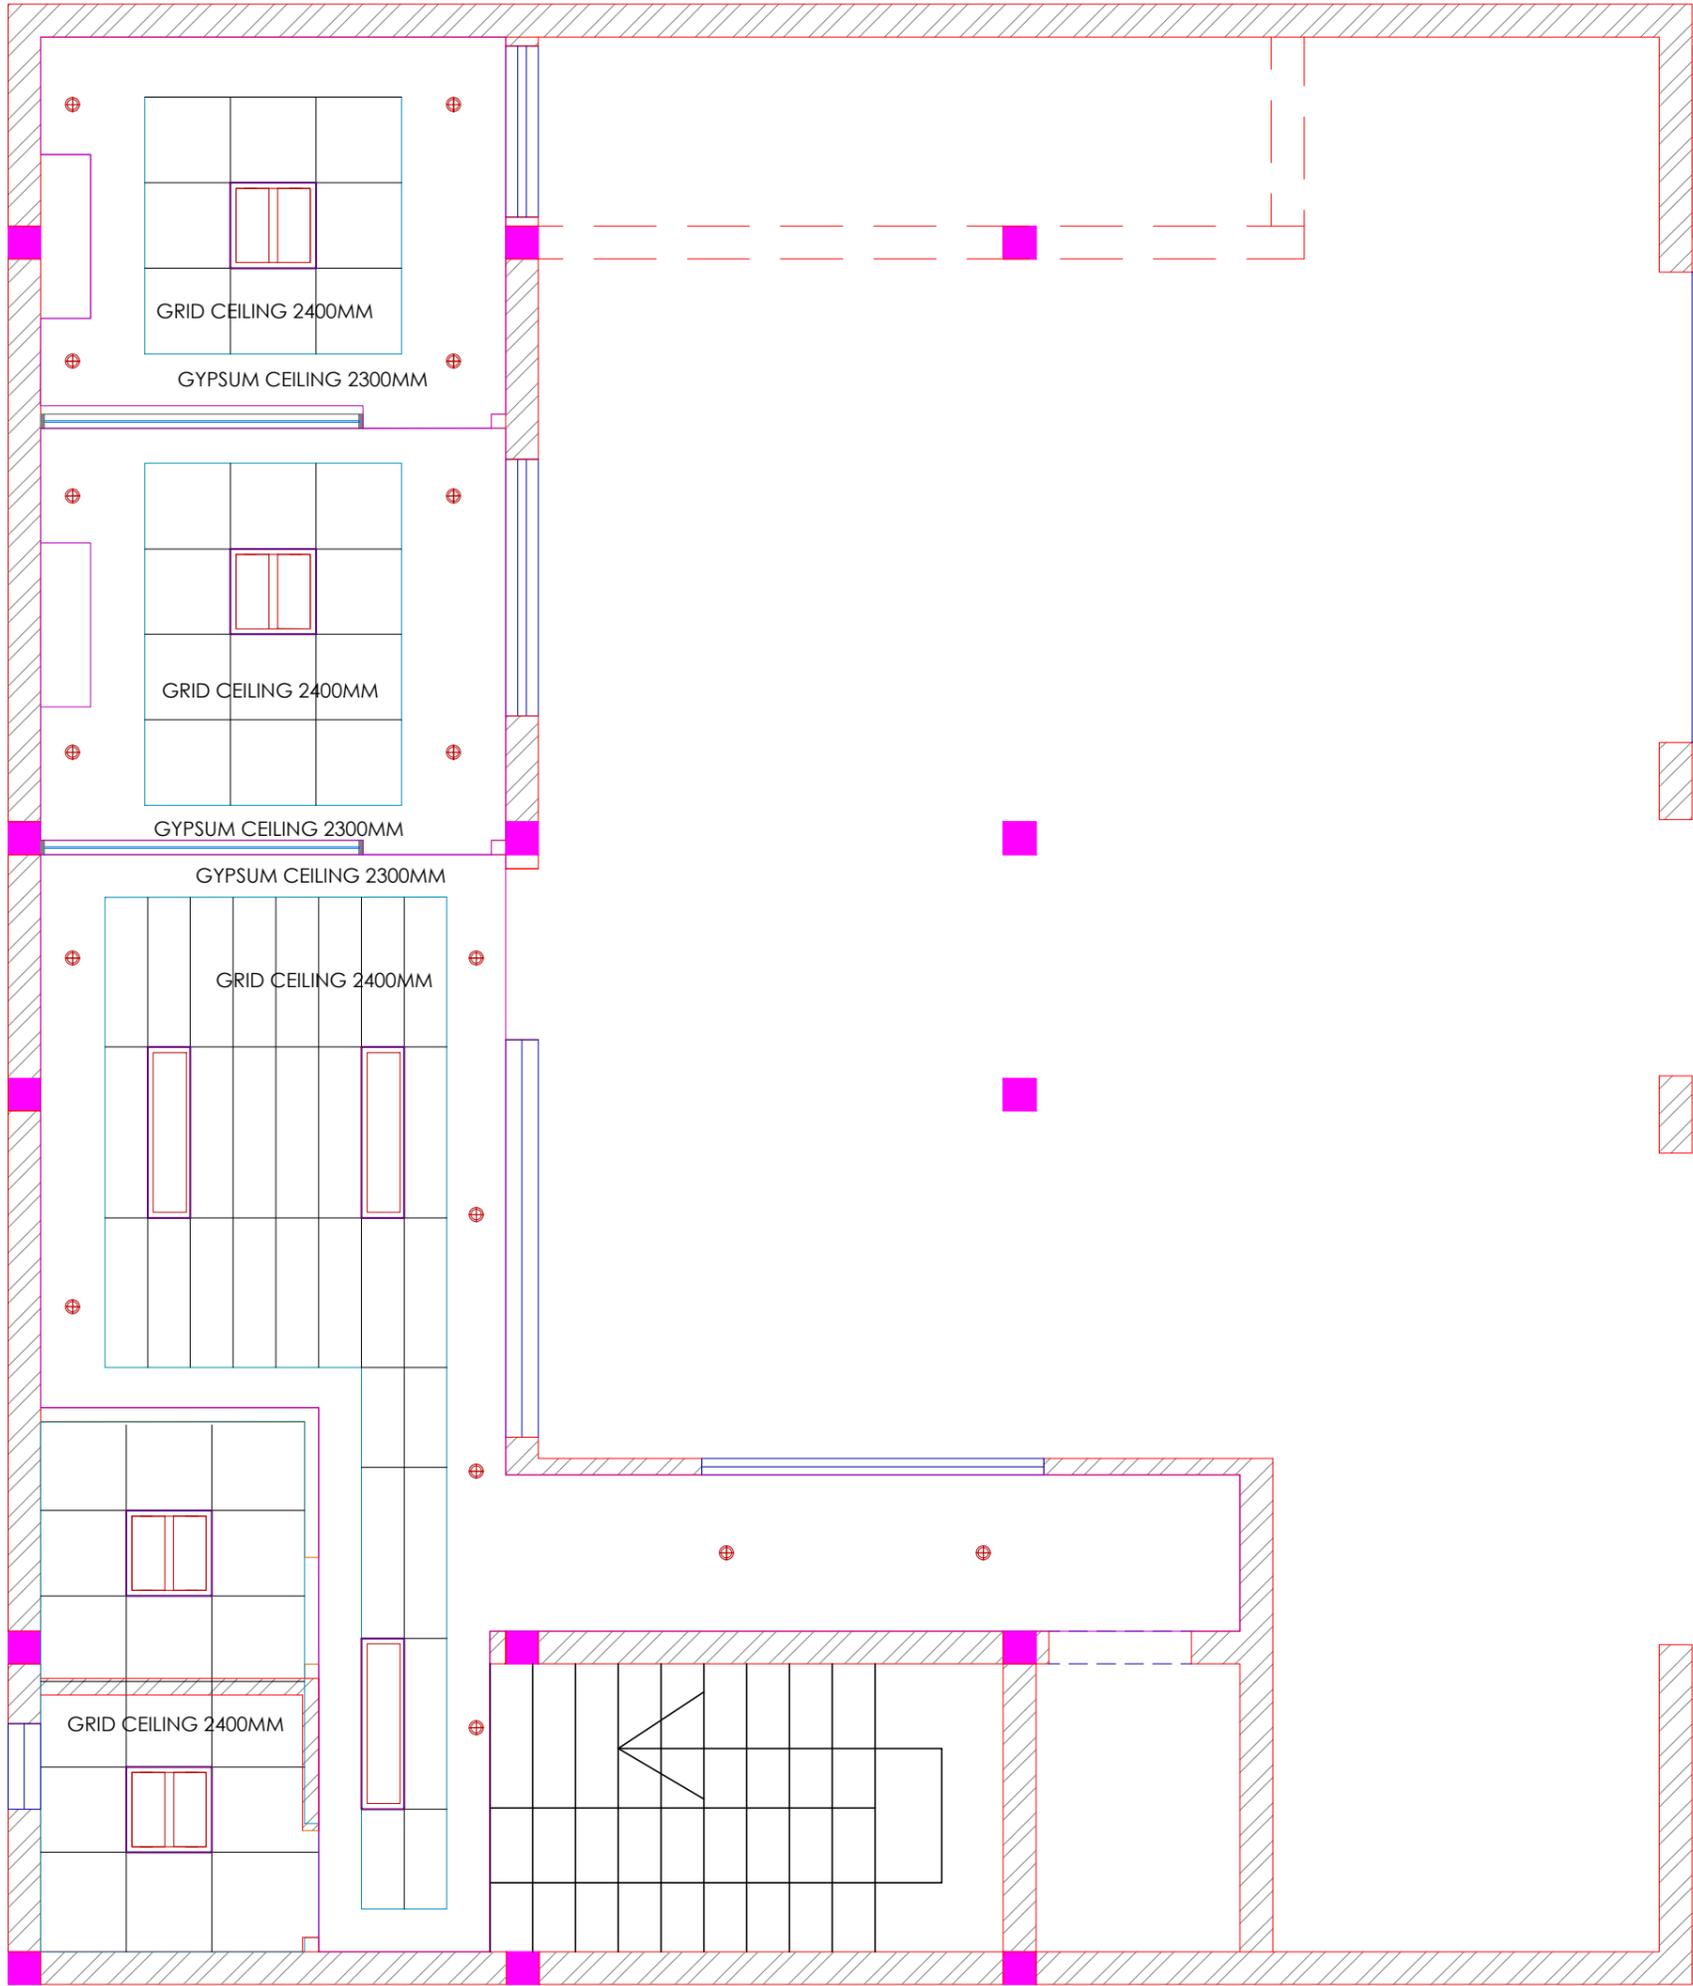

LEGEND

SYMBOL	DESCRIPTION
	GYPSUM CEILING
	600X600 GRID CEILING
	300X1200 GRID CEILING

Client	BPCL	Project Title	PROPOSED INTERIORS FOR BPCL TERRITORY OFFICE @ VIJAYAWADA		Drawing Title	RCP LAYOUT		Dwg No	BPCL_TO_TD-004
GENERAL NOTE: 1. DRAWING TO BE USED ONLY FOR THE PURPOSE RELEASED. 2. DO NOT SCALE THIS DRAWING, ONLY WRITTEN DIMENSIONS TO BE FOLLOWED. 3. ANY DISCREPANCY IN THE DRAWING SHOULD BE IMMEDIATELY BROUGHT TO THE NOTICE OF ARCHITECT.		REV	DESCRIPTION	BY	DATE	Drawn	KARTHIK		Architects New Designer Web Pvt Ltd No.185, 2nd Floor, 1st Main road, Nehru nagar, Kandanchavadi, Perungudi, Chennai - 600096 Tel: +91- 044 - 4212511www.designerweb.in
						Checked	VYOM		
						Approved	VYOM		
						Date	23.01.2024		
						Issued for	ISSUEDFORTENDER		

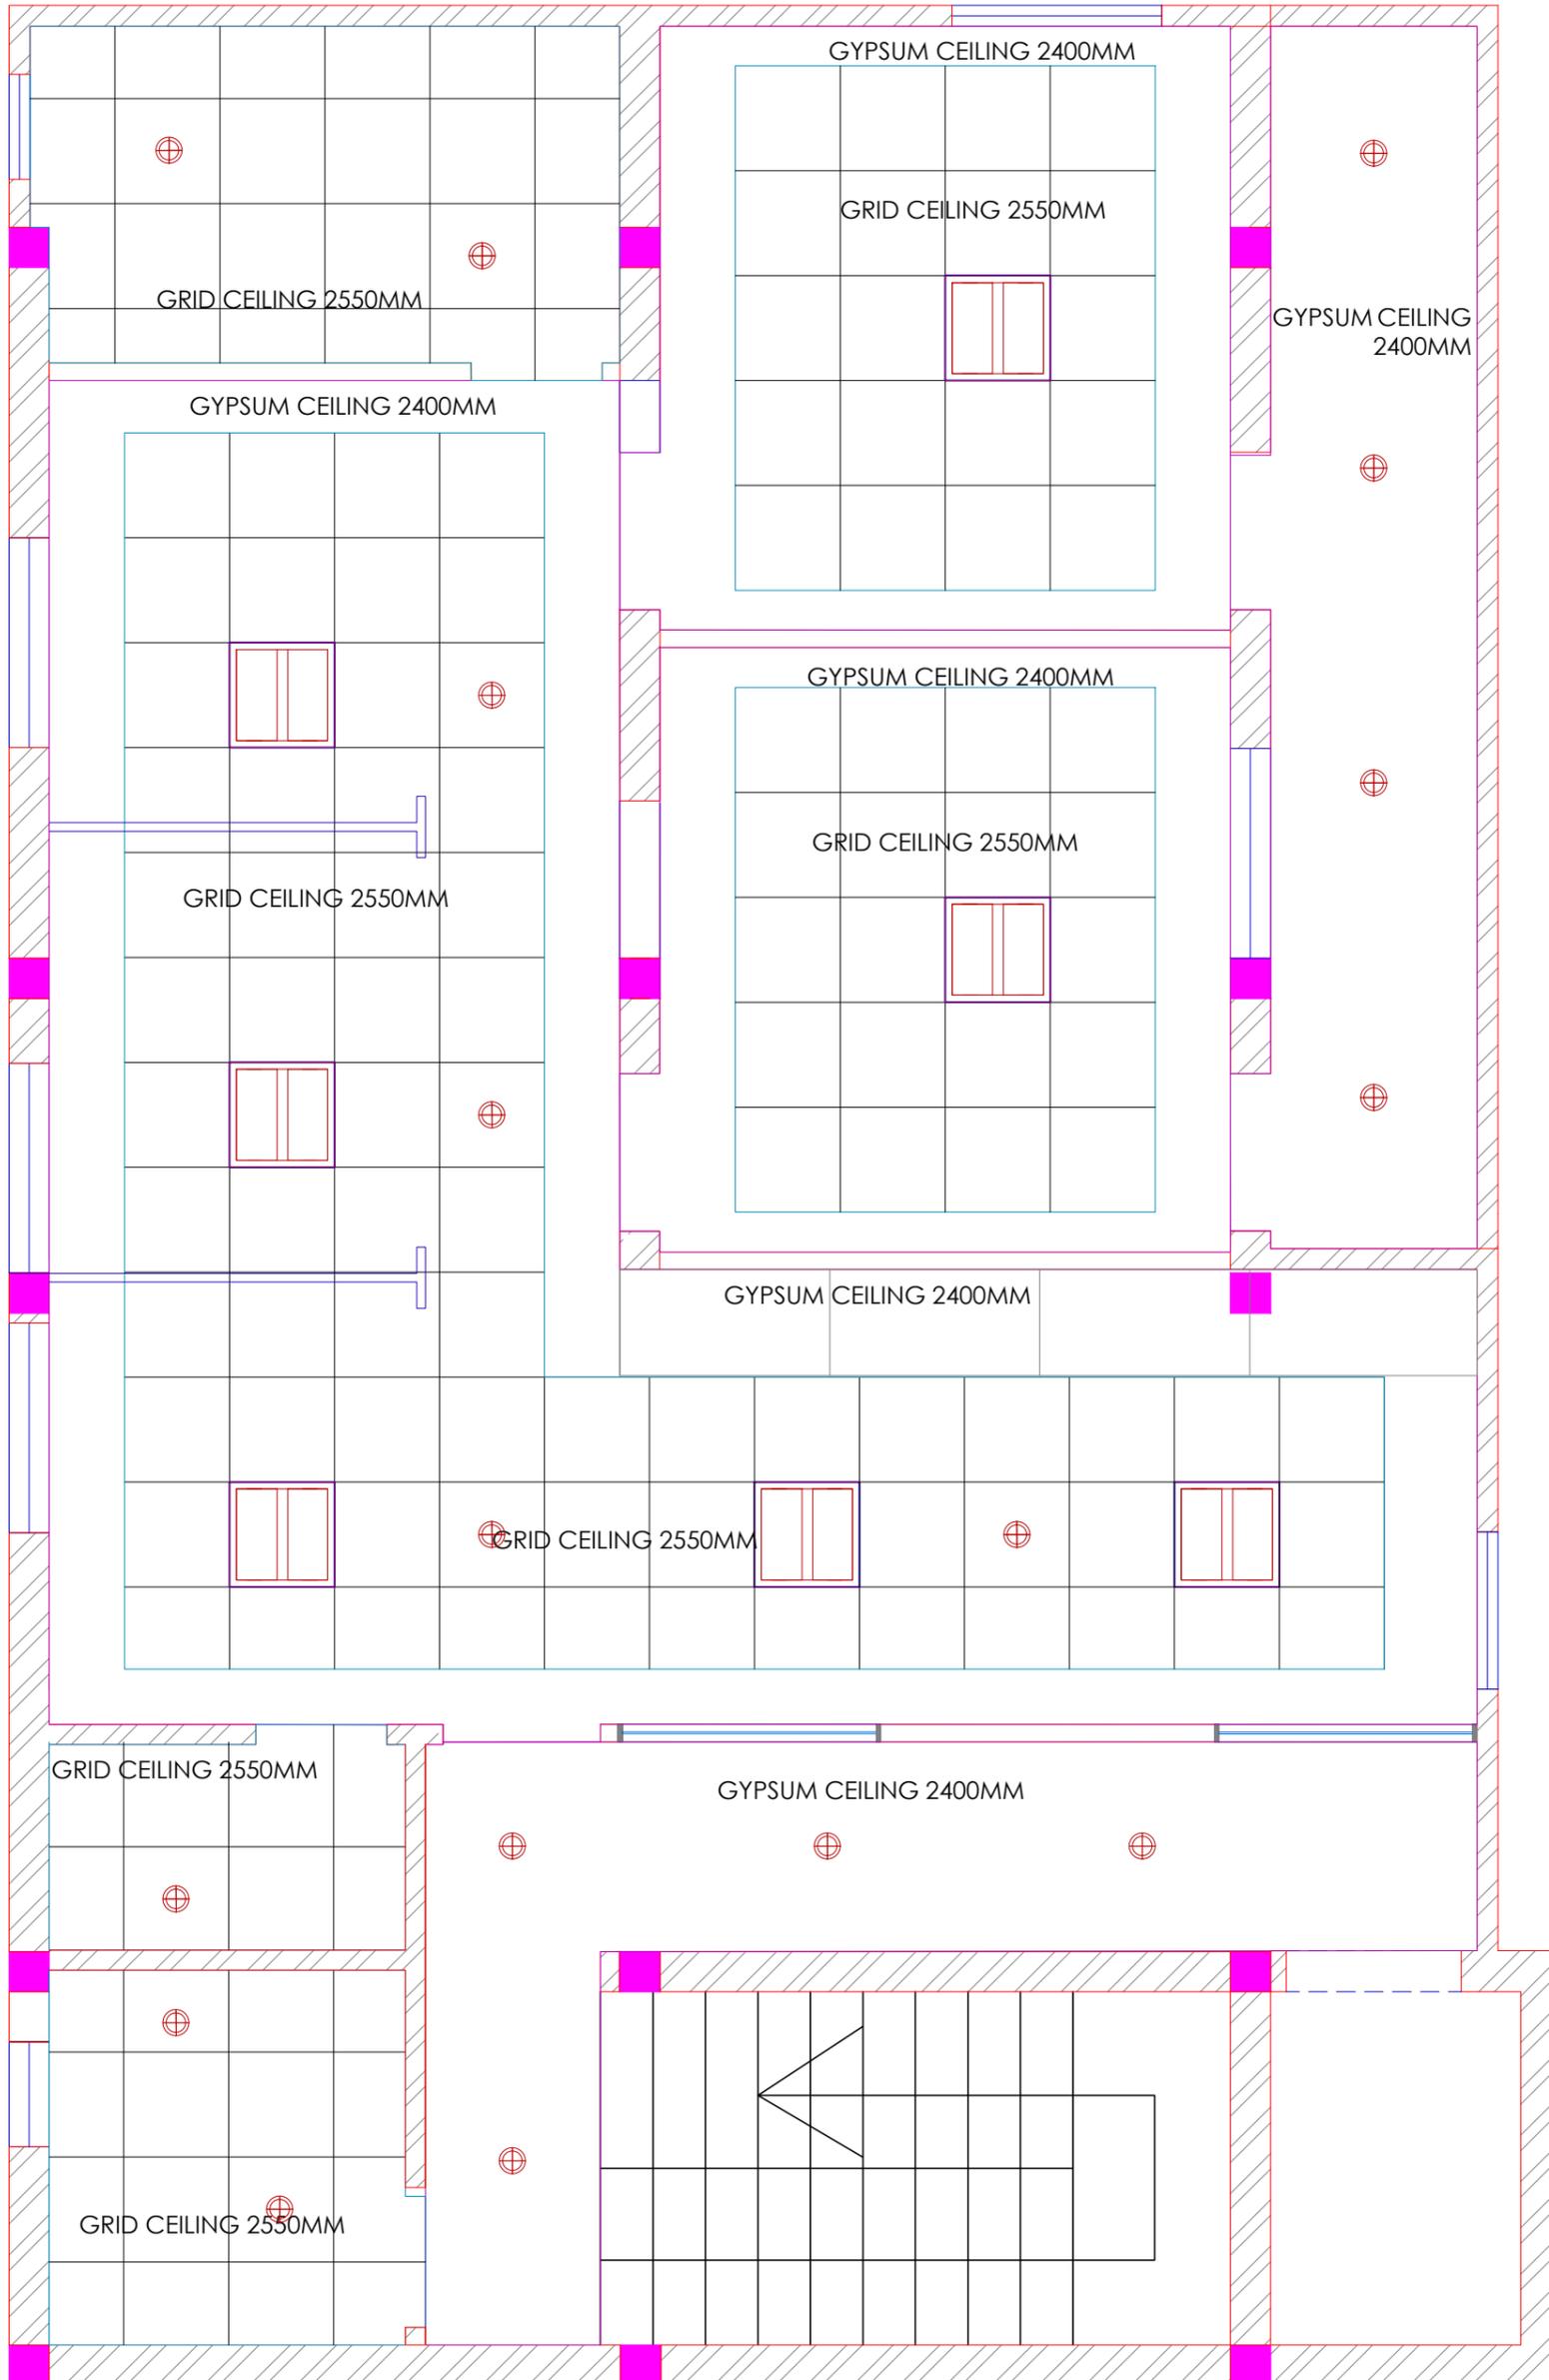

LEGEND

SYMBOL	DESCRIPTION
	GYPSUM CEILING
	600X600 GRID CEILING
	300X1200 GRID CEILING


Client	BPCL	Project Title	PROPOSED INTERIORS FOR BPCL TERRITORY OFFICE @ VIJAYAWADA	Drawing Title	RCP LAYOUT	Dwg No	BPCL_TO_TD-004		
GENERAL NOTE:		REV		DESCRIPTION		BY		DATE	
1. DRAWING TO BE USED ONLY FOR THE PURPOSE RELEASED.									
2. DO NOT SCALE THIS DRAWING, ONLY WRITTEN DIMENSIONS TO BE FOLLOWED.									
3. ANY DISCREPANCY IN THE DRAWING SHOULD BE IMMEDIATELY BROUGHT TO THE NOTICE OF ARCHITECT.									
				Drawn		KARTHIK			
				Checked		VYOM			
				Approved		VYOM			
				Date		23.01.2024			
				Issued for		ISSUEDFORTENDER		Scale	
						SCALE			
								Architects New Designer Web Pvt Ltd No.185, 2nd Floor, 1st Main road, Nehru nagar, Kandanchavadi, Perungudi, Chennai - 600096 Tel: +91- 044 - 4212511www.designerweb.in	




LEGEND

SYMBOL	DESCRIPTION
	GYPSUM CEILING
	600X600 GRID CEILING
	300X1200 GRID CEILING


Client	BPCL	Project Title	PROPOSED INTERIORS FOR BPCL TERRITORY OFFICE @ VIJAYAWADA	Drawing Title	RCP LAYOUT	Dwg No	BPCL_TO_ID-004
GENERAL NOTE: 1. DRAWING TO BE USED ONLY FOR THE PURPOSE RELEASED. 2. DO NOT SCALE THIS DRAWING, ONLY WRITTEN DIMENSIONS TO BE FOLLOWED. 3. ANY DISCREPANCY IN THE DRAWING SHOULD BE IMMEDIATELY BROUGHT TO THE NOTICE OF ARCHITECT.		REV	DESCRIPTION	BY	DATE	Drawn	KARTHIK
						Checked	VYOM
						Approved	VYOM
						Date	23.01.2024
						Issued for	ISSUEDFORTENDER
						Architects New Designer Web Pvt Ltd No.185, 2nd Floor, 1st Main road, Nehru nagar, Kandanchavadi, Perungudi, Chennai - 600096 Tel: +91- 044 - 4212511www.designerweb.in	

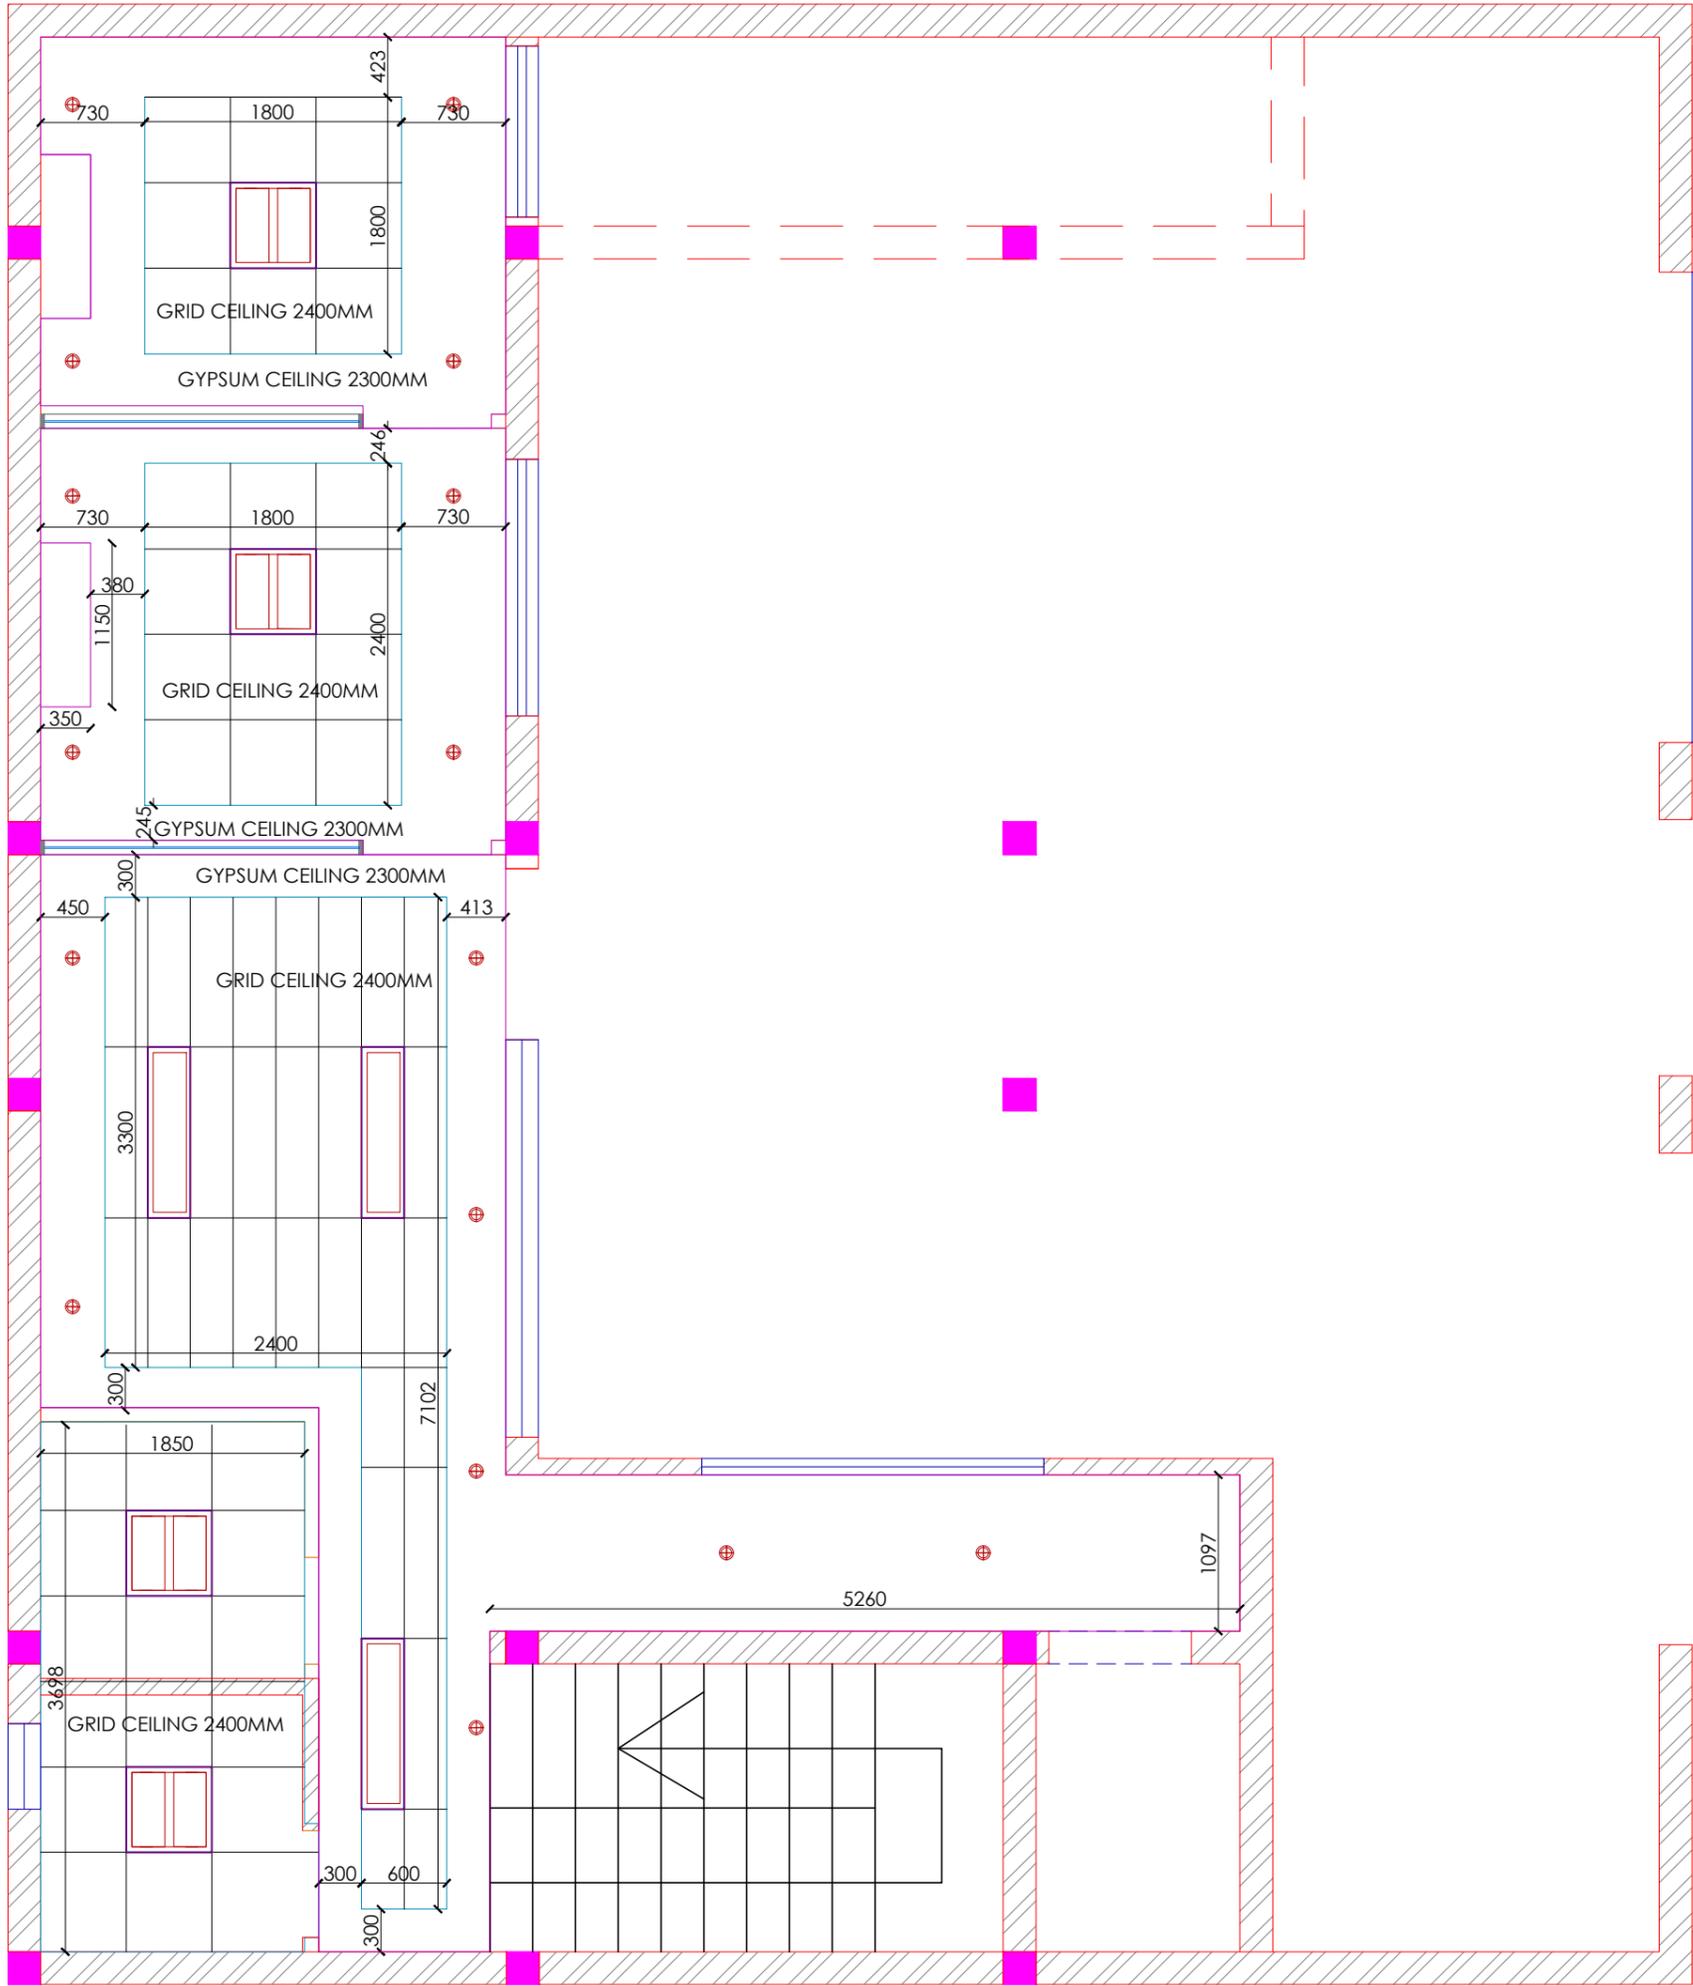

Client	BPCL	Project Title	PROPOSED INTERIORS FOR BPCL TERRITORY OFFICE @ VIJAYAWADA		Drawing Title	RCP MARKING LAYOUT		Dwg No	BPCL_TO_TD-005
GENERAL NOTE: 1. DRAWING TO BE USED ONLY FOR THE PURPOSE RELEASED. 2. DO NOT SCALE THIS DRAWING, ONLY WRITTEN DIMENSIONS TO BE FOLLOWED. 3. ANY DISCREPANCY IN THE DRAWING SHOULD BE IMMEDIATELY BROUGHT TO THE NOTICE OF ARCHITECT.		REV	DESCRIPTION	BY	DATE	Drawn	KARTHIK		Architects  New Designer Web Pvt Ltd No.185, 2nd Floor, 1st Main road, Nehru nagar, Kandanchavadi, Perungudi, Chennai - 600096 Tel: +91- 044 - 4212511 www.designerweb.in
						Checked	VYOM		
						Approved	VYOM		
						Date	23.01.2024		
						Issued for	ISSUEDFORTENDER		

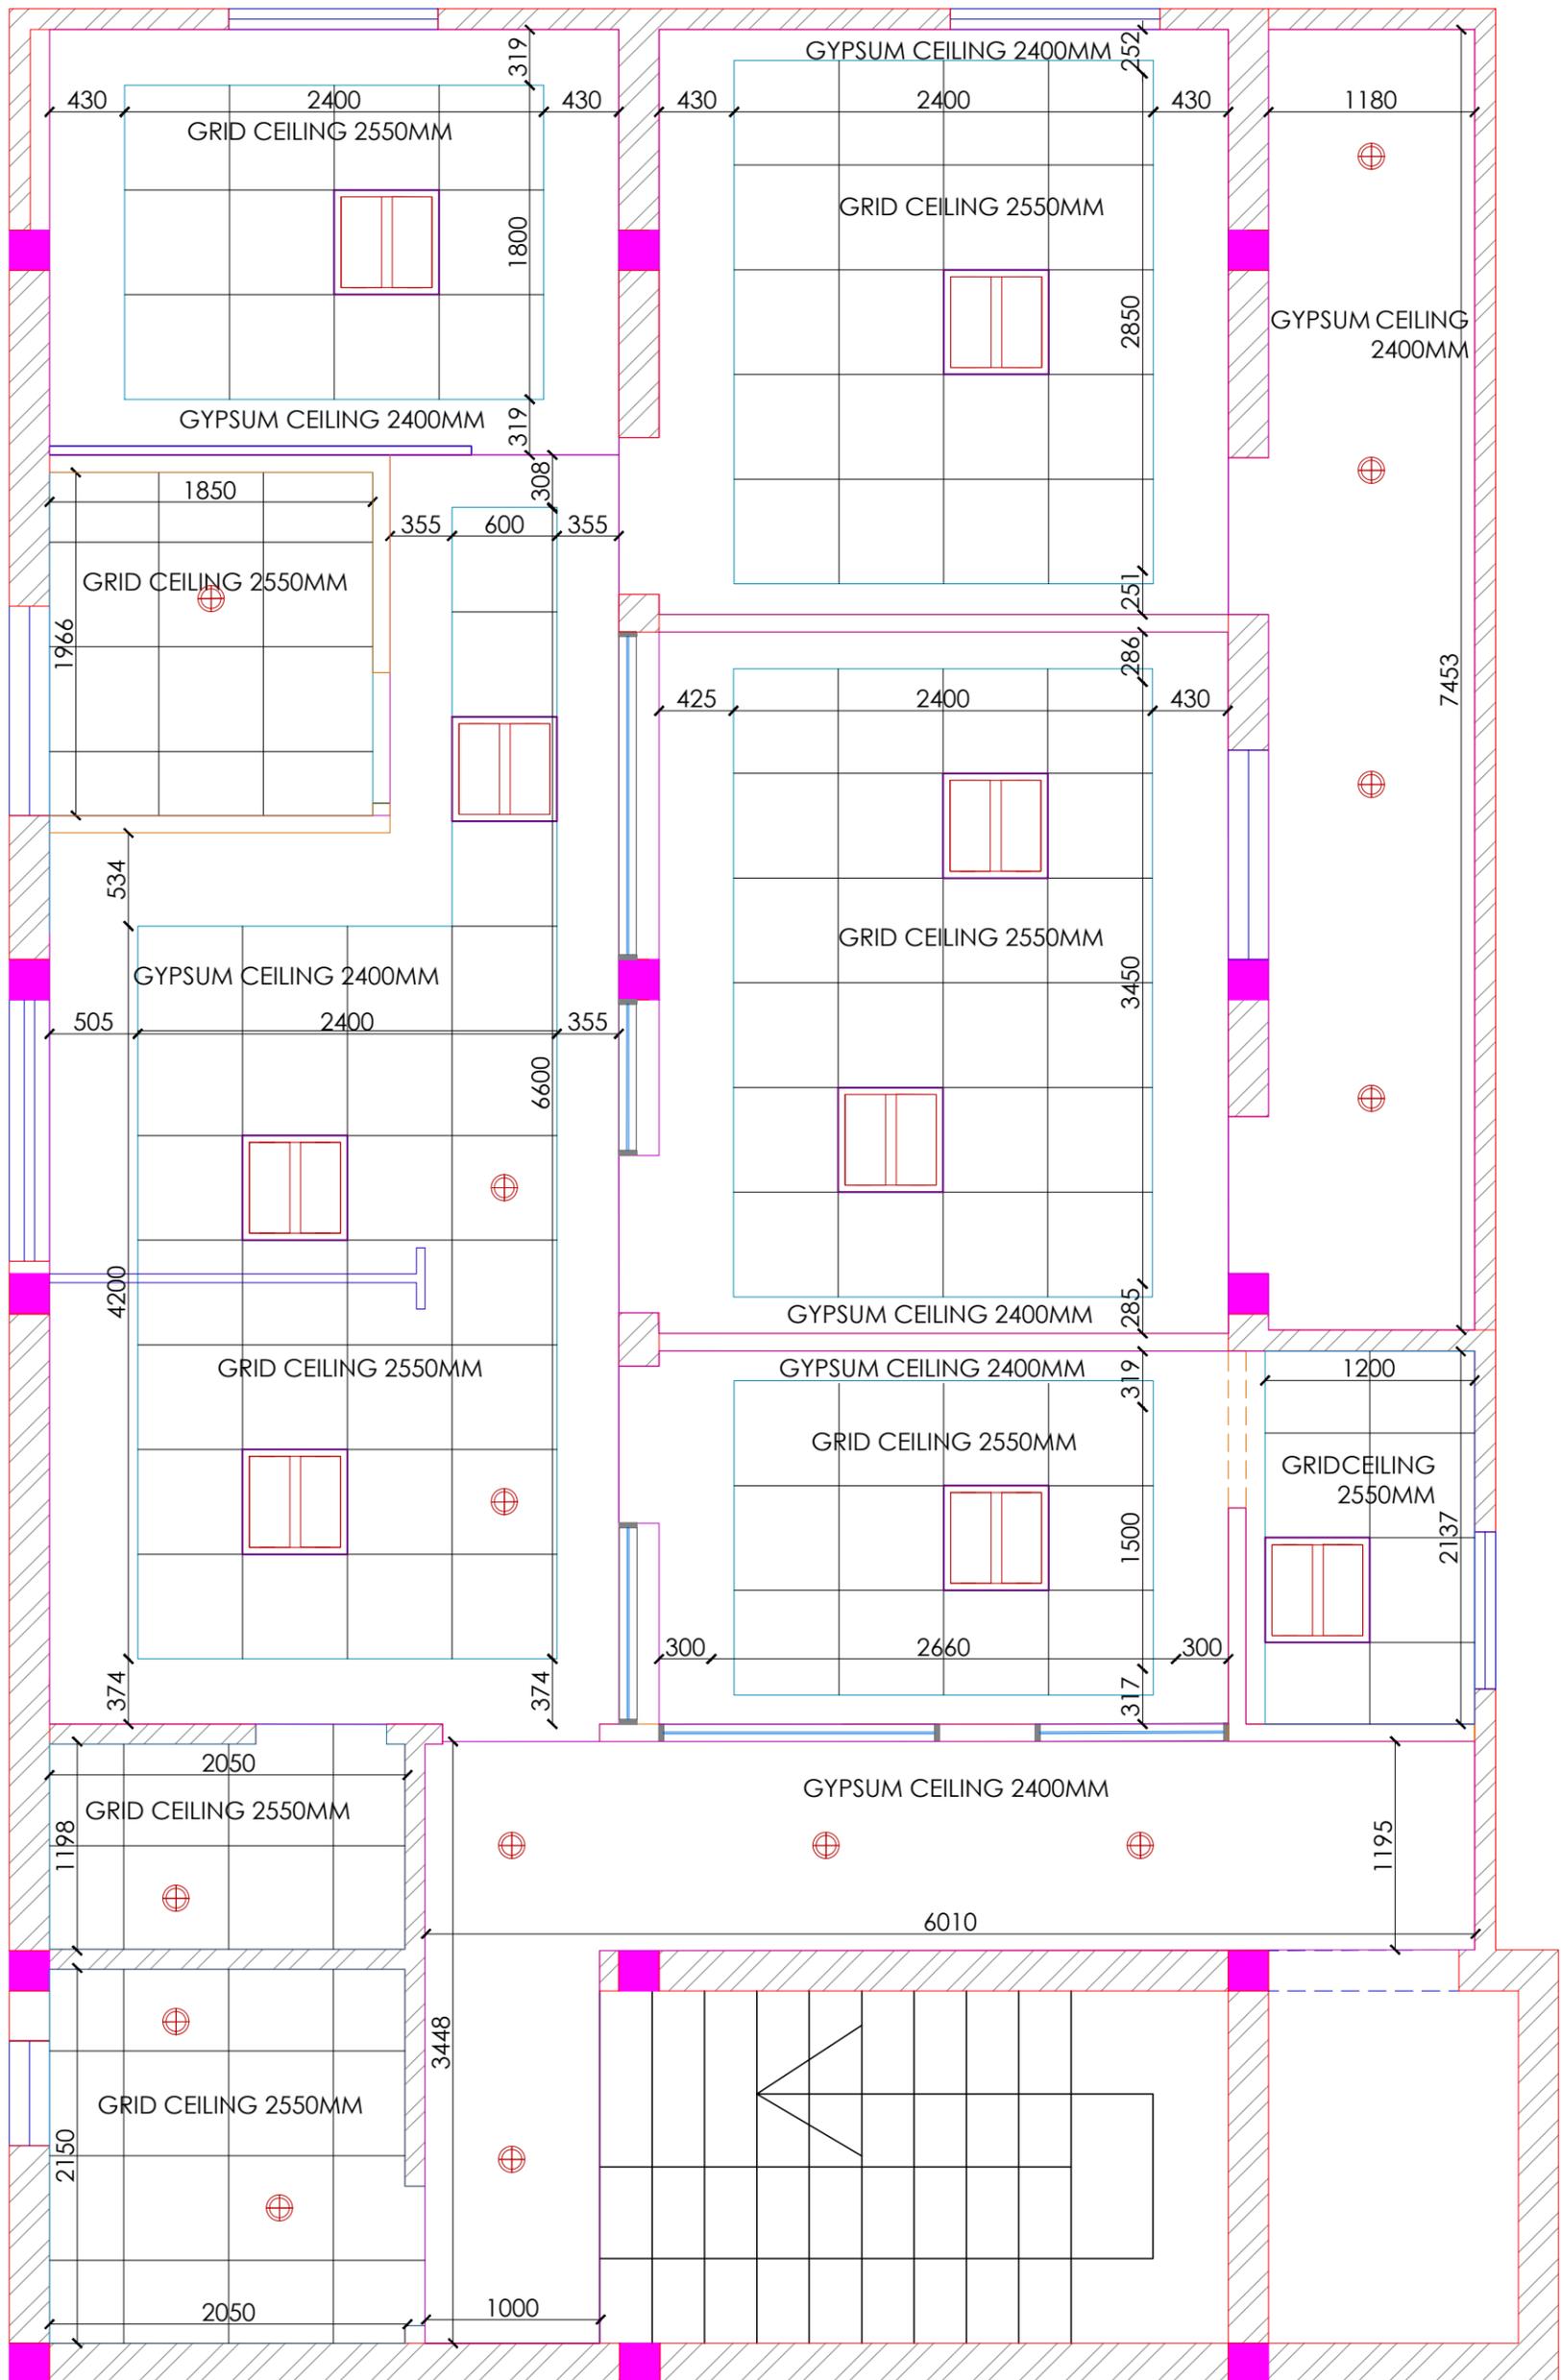


Client	BPCL	Project Title	PROPOSED INTERIORS FOR BPCL TERRITORY OFFICE @ VIJAYAWADA		Drawing Title	RCP MARKING LAYOUT		Dwg No	BPCL_TO_TD-005
GENERAL NOTE: 1. DRAWING TO BE USED ONLY FOR THE PURPOSE RELEASED. 2. DO NOT SCALE THIS DRAWING, ONLY WRITTEN DIMENSIONS TO BE FOLLOWED. 3. ANY DISCREPANCY IN THE DRAWING SHOULD BE IMMEDIATELY BROUGHT TO THE NOTICE OF ARCHITECT.		REV	DESCRIPTION	BY	DATE	Drawn	KARTHIK		Architects  New Designer Web Pvt Ltd No.185, 2nd Floor, 1st Main road, Nehru nagar, Kandanchavadi, Perungudi, Chennai - 600096 Tel: +91- 044 - 4212511 www.designerweb.in
						Checked	VYOM		
						Approved	VYOM		
						Date	23.01.2024		
						Issued for	ISSUEDFORTENDER		

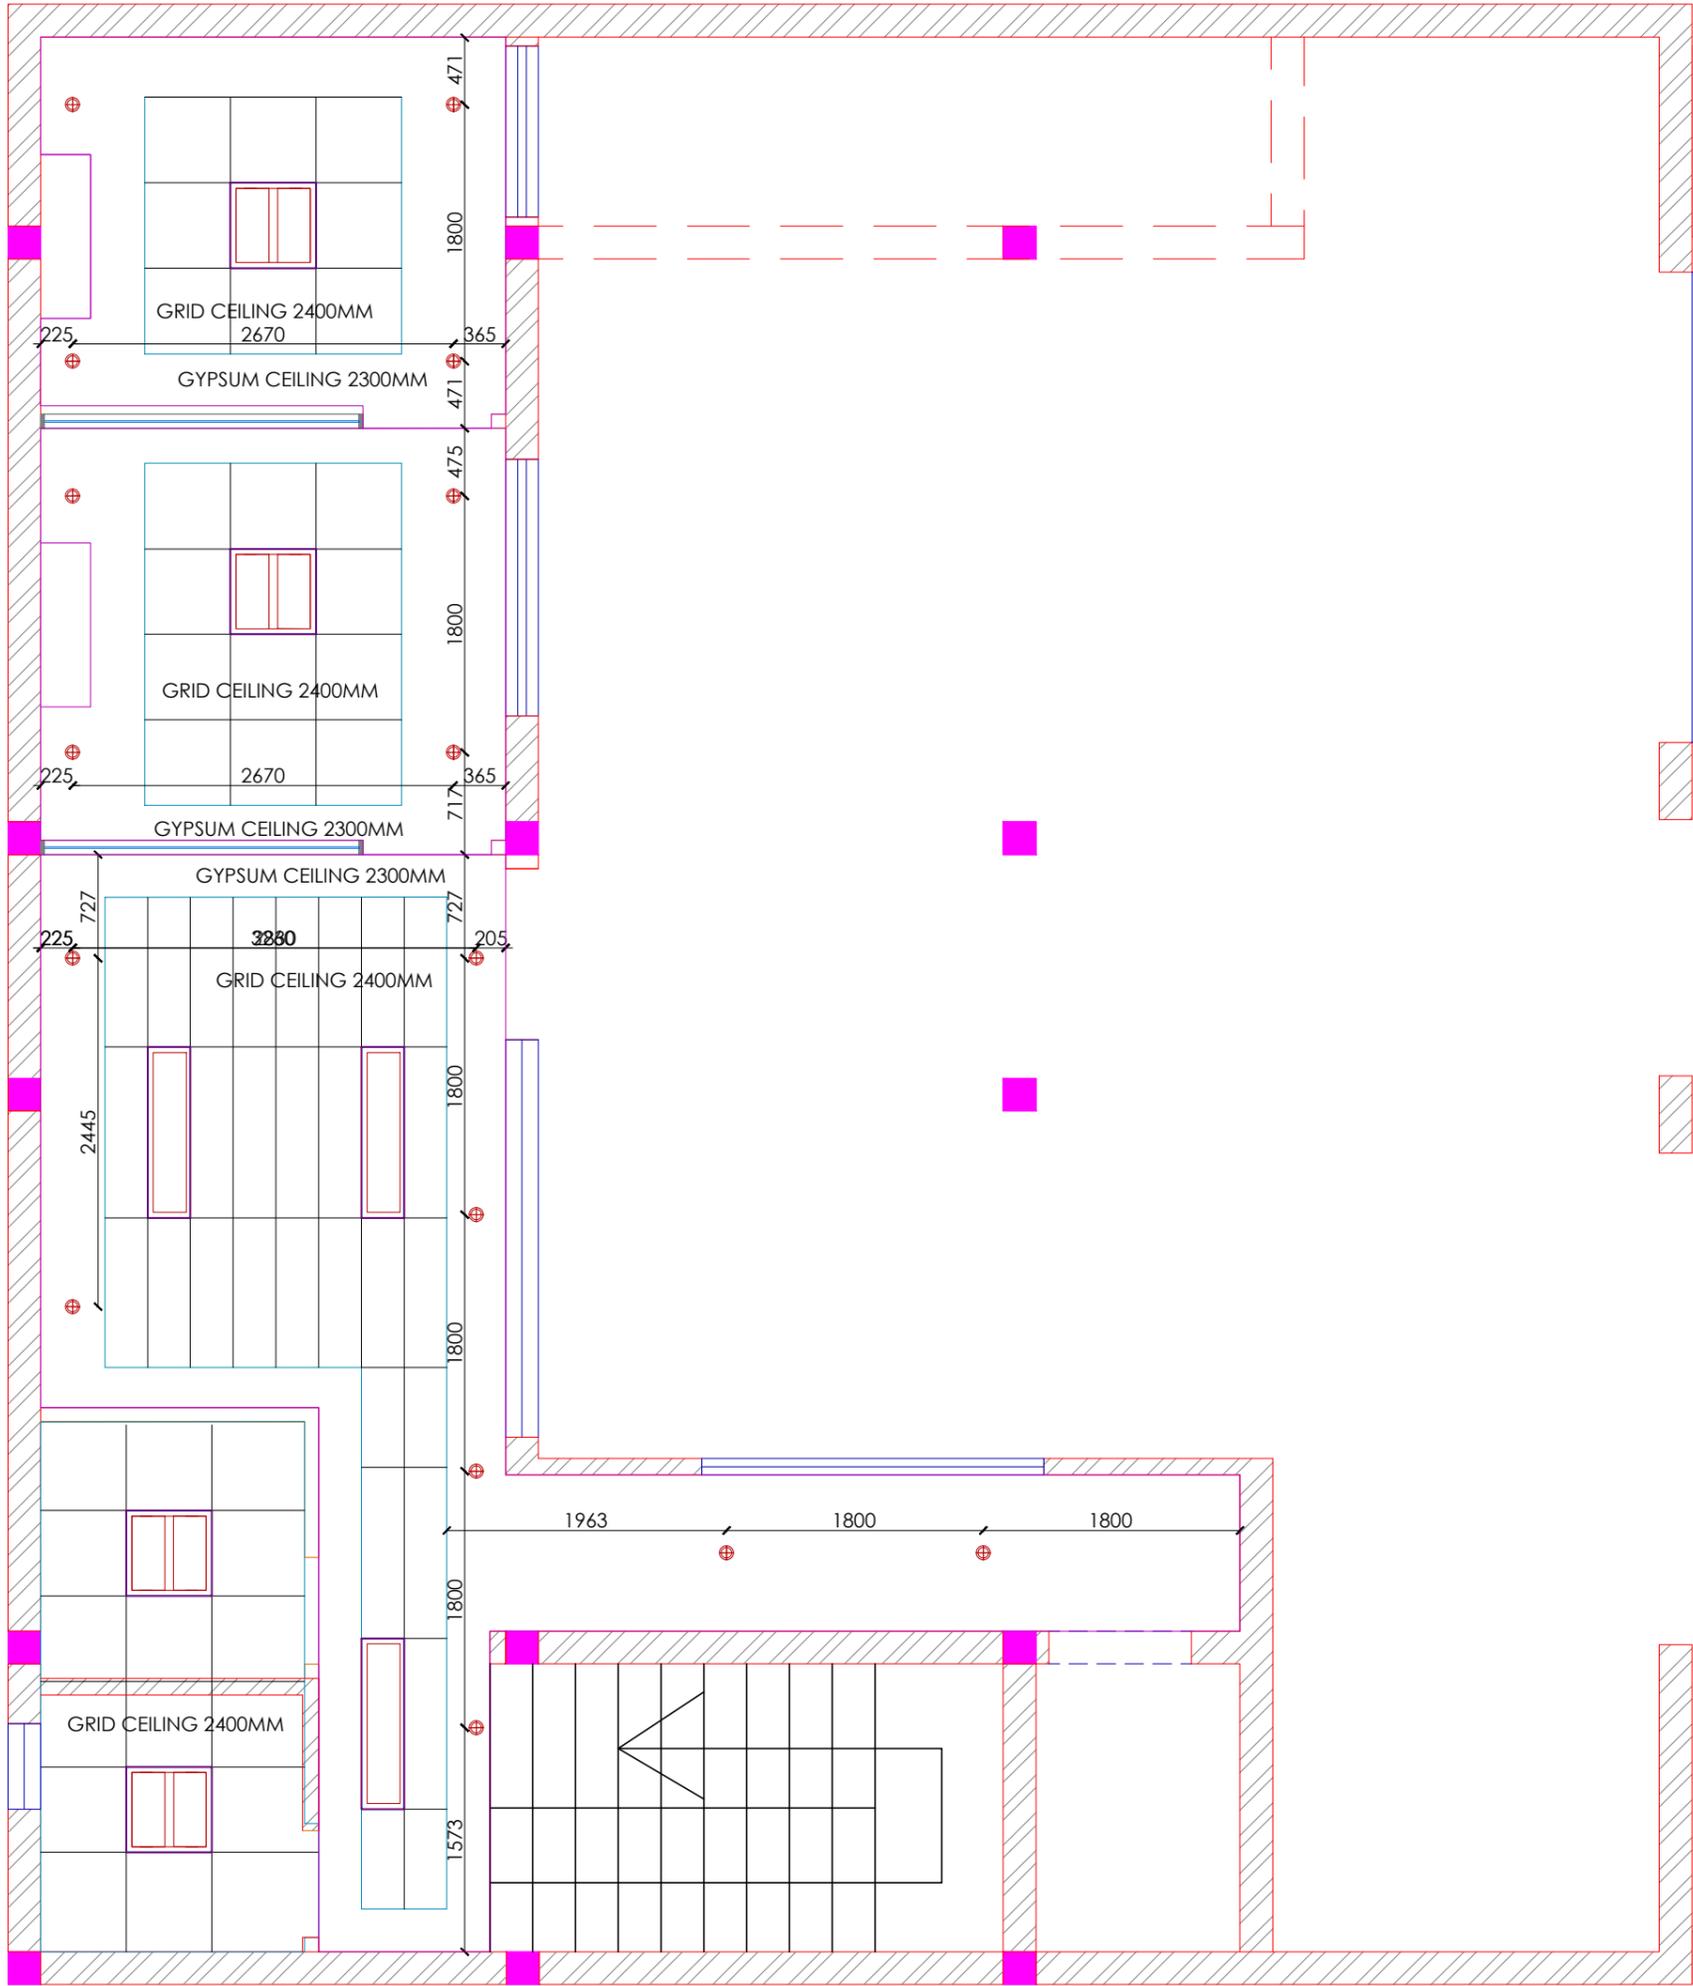


SYMBOL	DESCRIPTION
	100MMØ DOWNLIGHTS
	2'X2' LIGHTS

Client	BPCL	Project Title	PROPOSED INTERIORS FOR BPCL TERRITORY OFFICE @ VIJAYAWADA		Drawing Title	LIGHT MARKING LAYOUT		Dwg No	BPCL_TO_TD-006
GENERAL NOTE: 1. DRAWING TO BE USED ONLY FOR THE PURPOSE RELEASED. 2. DO NOT SCALE THIS DRAWING, ONLY WRITTEN DIMENSIONS TO BE FOLLOWED. 3. ANY DISCREPANCY IN THE DRAWING SHOULD BE IMMEDIATELY BROUGHT TO THE NOTICE OF ARCHITECT.		REV	DESCRIPTION	BY	DATE	Drawn	KARTHIK		Architects New Designer Web Pvt Ltd No.185, 2nd Floor, 1st Main road, Nehru nagar, Kandanchavadi, Perungudi, Chennai - 600096 Tel: +91- 044 - 4212511 www.designerweb.in
						Checked	VYOM		
						Approved	VYOM		
						Date	23.01.2024		
						Issued for	ISSUEDFORTENDER		

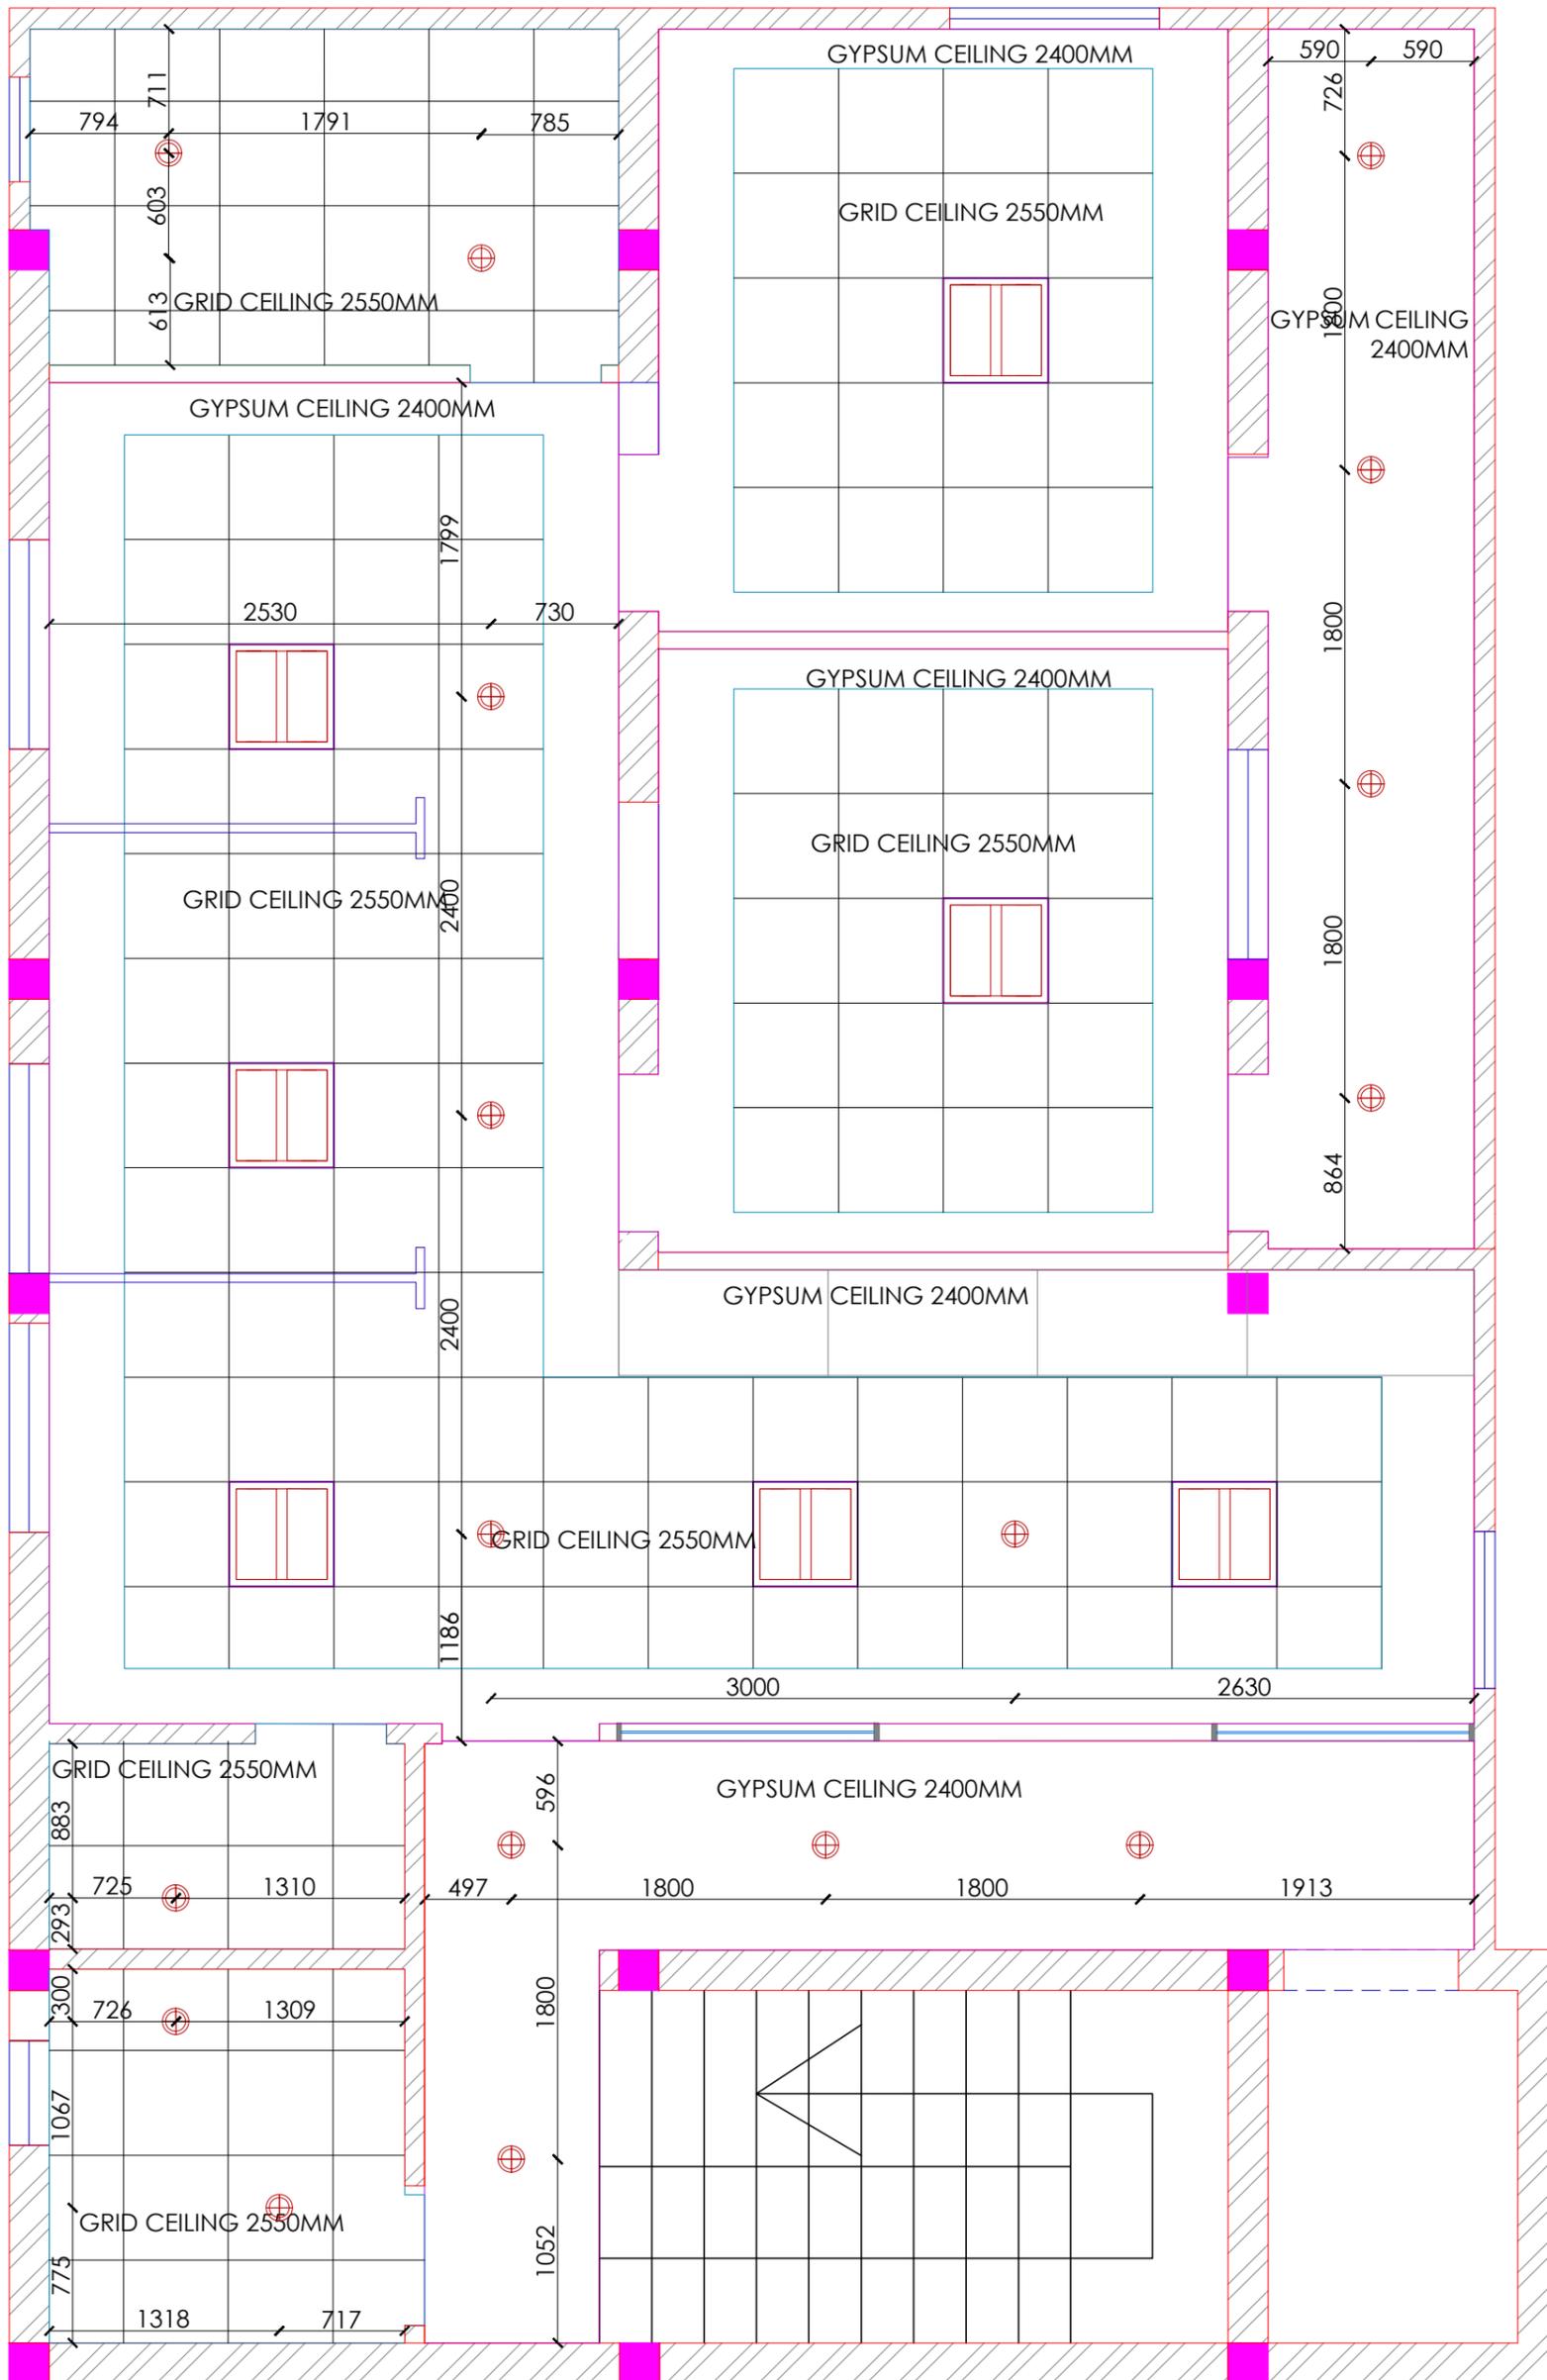


SYMBOL	DESCRIPTION
	100MMØ DOWNLIGHTS
	2'X2' LIGHTS

Client	BPCL	Project Title	PROPOSED INTERIORS FOR BPCL TERRITORY OFFICE @ VIJAYAWADA		Drawing Title	LIGHT MARKING LAYOUT		Dwg No	BPCL_TO_ID-006
GENERAL NOTE: 1. DRAWING TO BE USED ONLY FOR THE PURPOSE RELEASED. 2. DO NOT SCALE THIS DRAWING, ONLY WRITTEN DIMENSIONS TO BE FOLLOWED. 3. ANY DISCREPANCY IN THE DRAWING SHOULD BE IMMEDIATELY BROUGHT TO THE NOTICE OF ARCHITECT.		REV	DESCRIPTION	BY	DATE	Drawn	KARTHIK		Architects No.185, 2nd Floor, 1st Main road, Nehru nagar, Kandanchavadi, Perungudi, Chennai - 600096 Tel: +91- 044 - 4212511www.designerweb.in
						Checked	VYOM		
						Approved	VYOM		
						Date	23.01.2024		
						Issued for	ISSUEDFORTENDER		

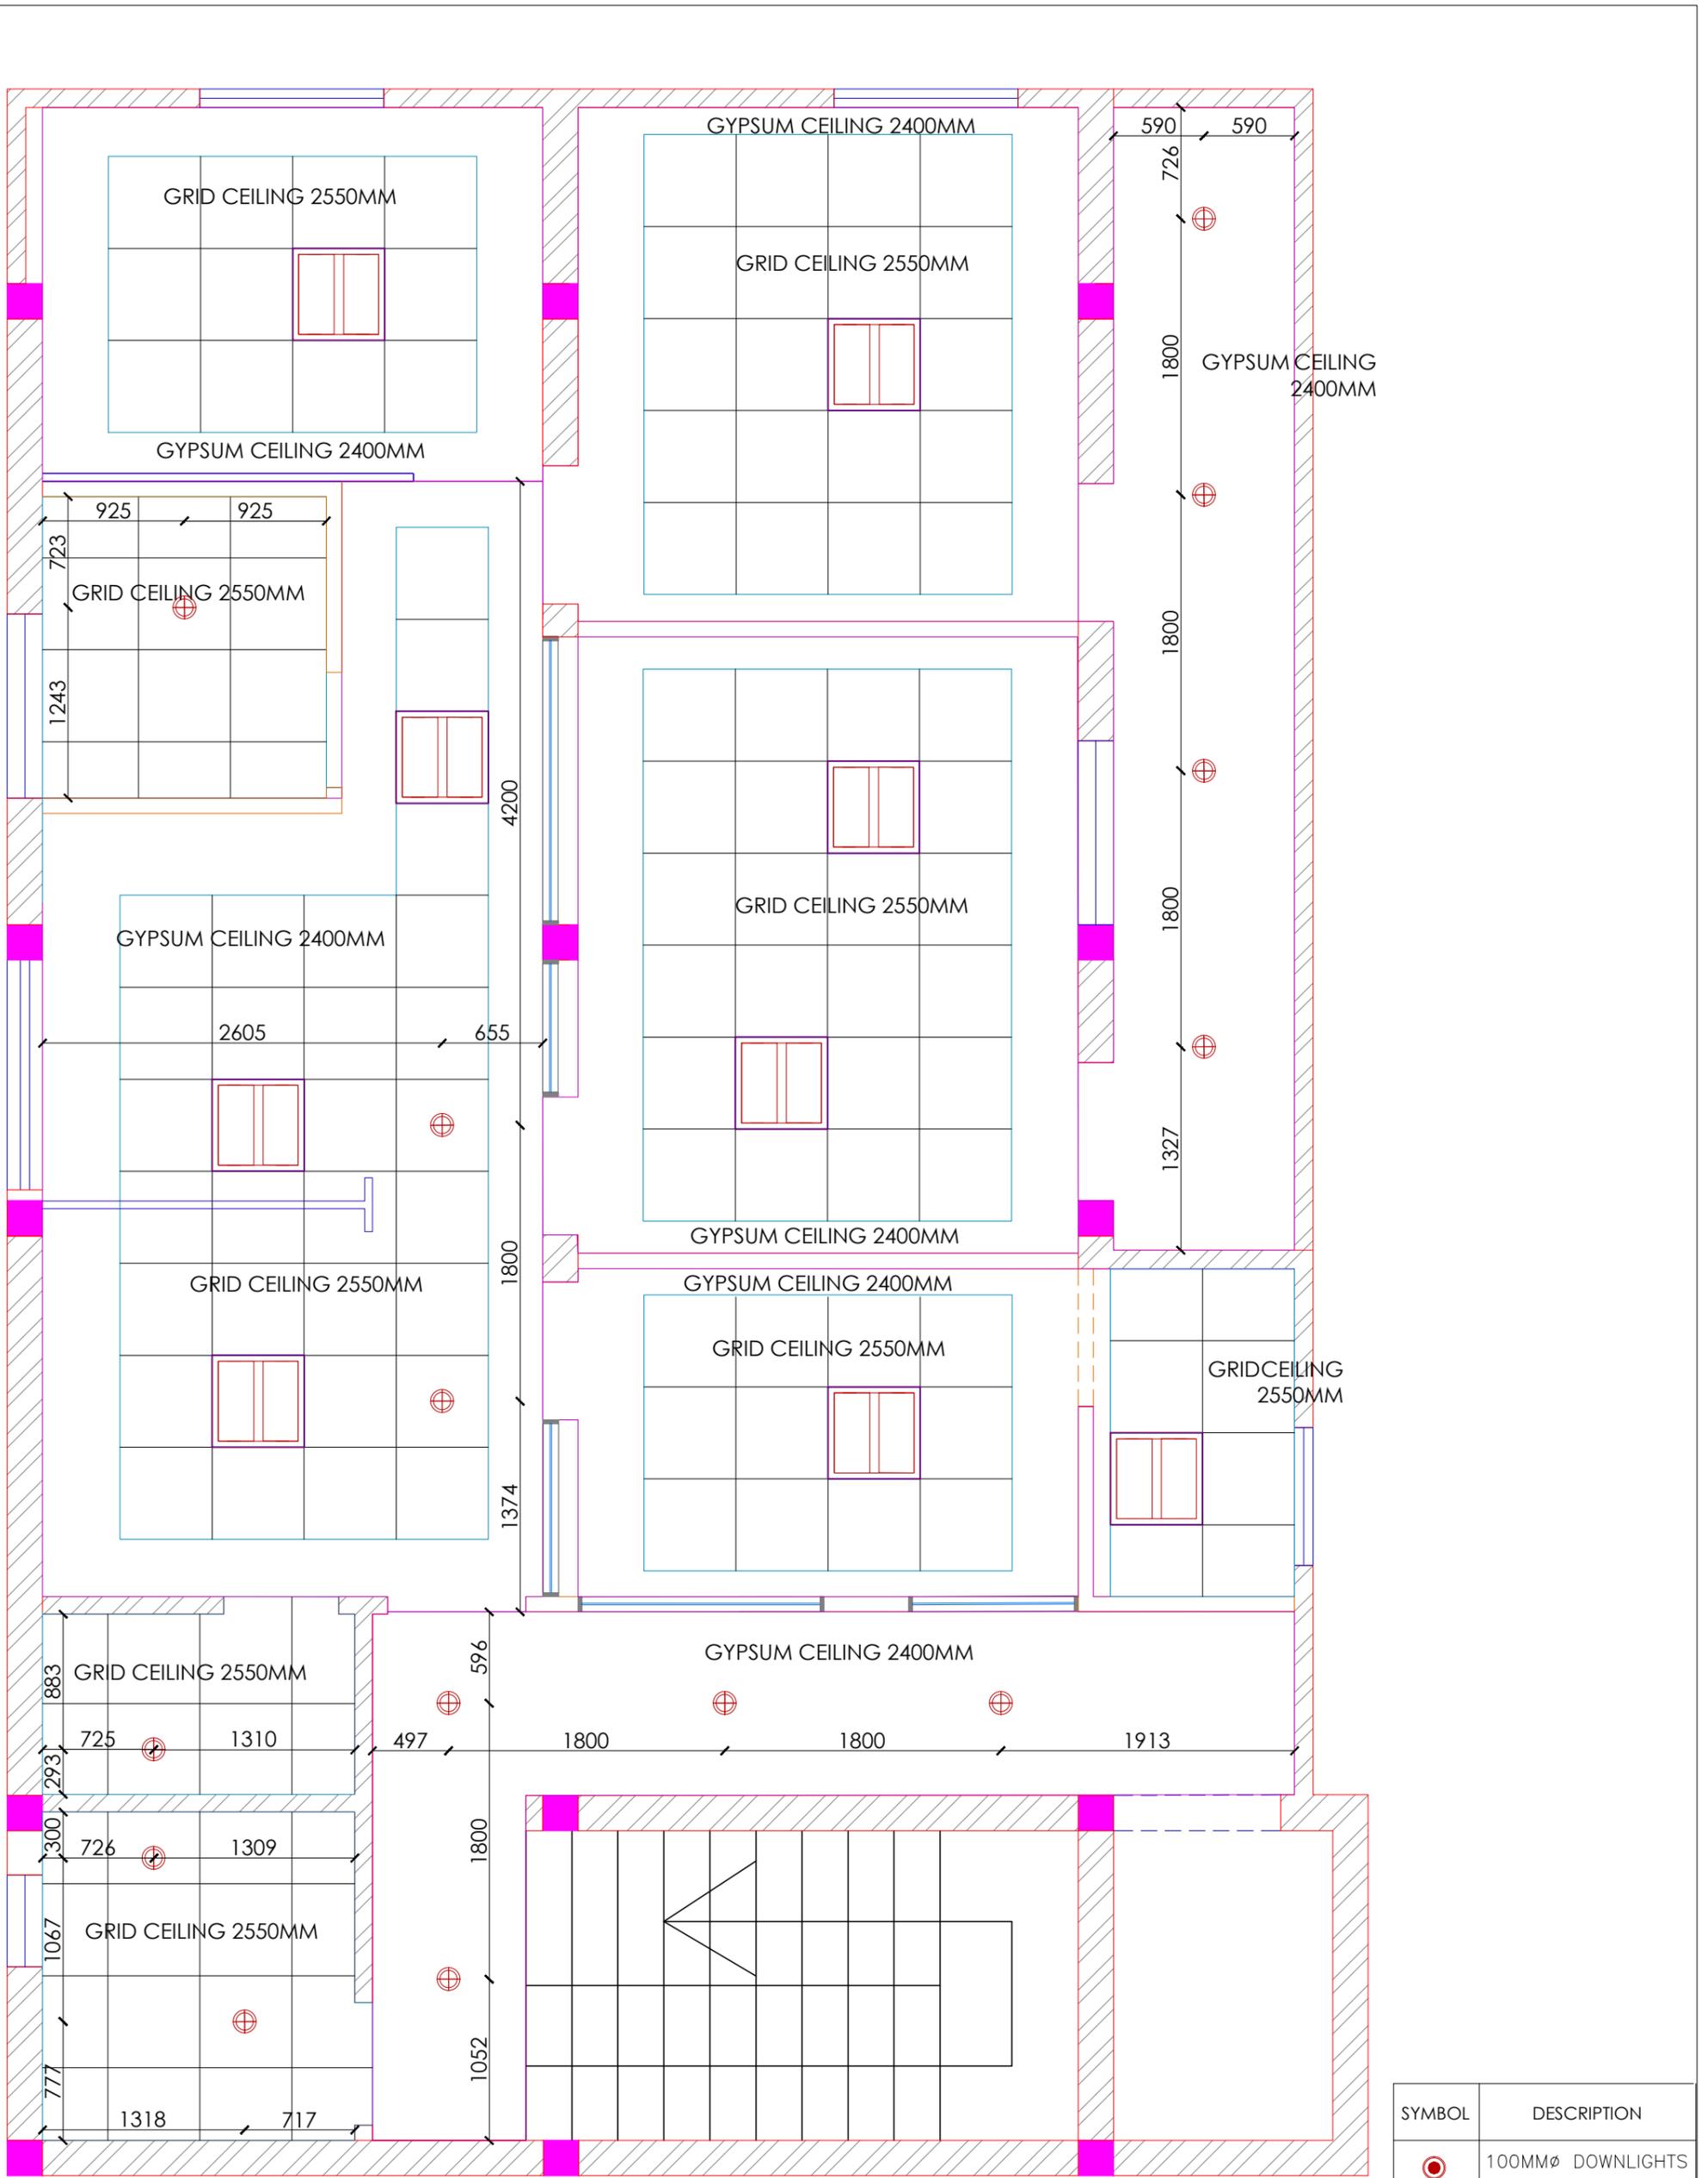

SYMBOL	DESCRIPTION
	100MMØ DOWNLIGHTS
	2'X2' LIGHTS


Client	BPCL	Project Title	PROPOSED INTERIORS FOR BPCL TERRITORY OFFICE @ VIJAYAWADA		Drawing Title	LIGHT MARKING LAYOUT		Dwg No	BPCL_TO_TD-006
GENERAL NOTE: 1. DRAWING TO BE USED ONLY FOR THE PURPOSE RELEASED. 2. DO NOT SCALE THIS DRAWING, ONLY WRITTEN DIMENSIONS TO BE FOLLOWED. 3. ANY DISCREPANCY IN THE DRAWING SHOULD BE IMMEDIATELY BROUGHT TO THE NOTICE OF ARCHITECT.		REV	DESCRIPTION	BY	DATE	Drawn	KARTHIK		Architects No.185, 2nd Floor, 1st Main road, Nehru nagar, Kandanchavadi, Perungudi, Chennai - 600096 Tel: +91- 044 - 42125111www.designerweb.in
						Checked	VYOM		
						Approved	VYOM		
						Date	23.01.2024		
						Issued for	ISSUEDFORTENDER		

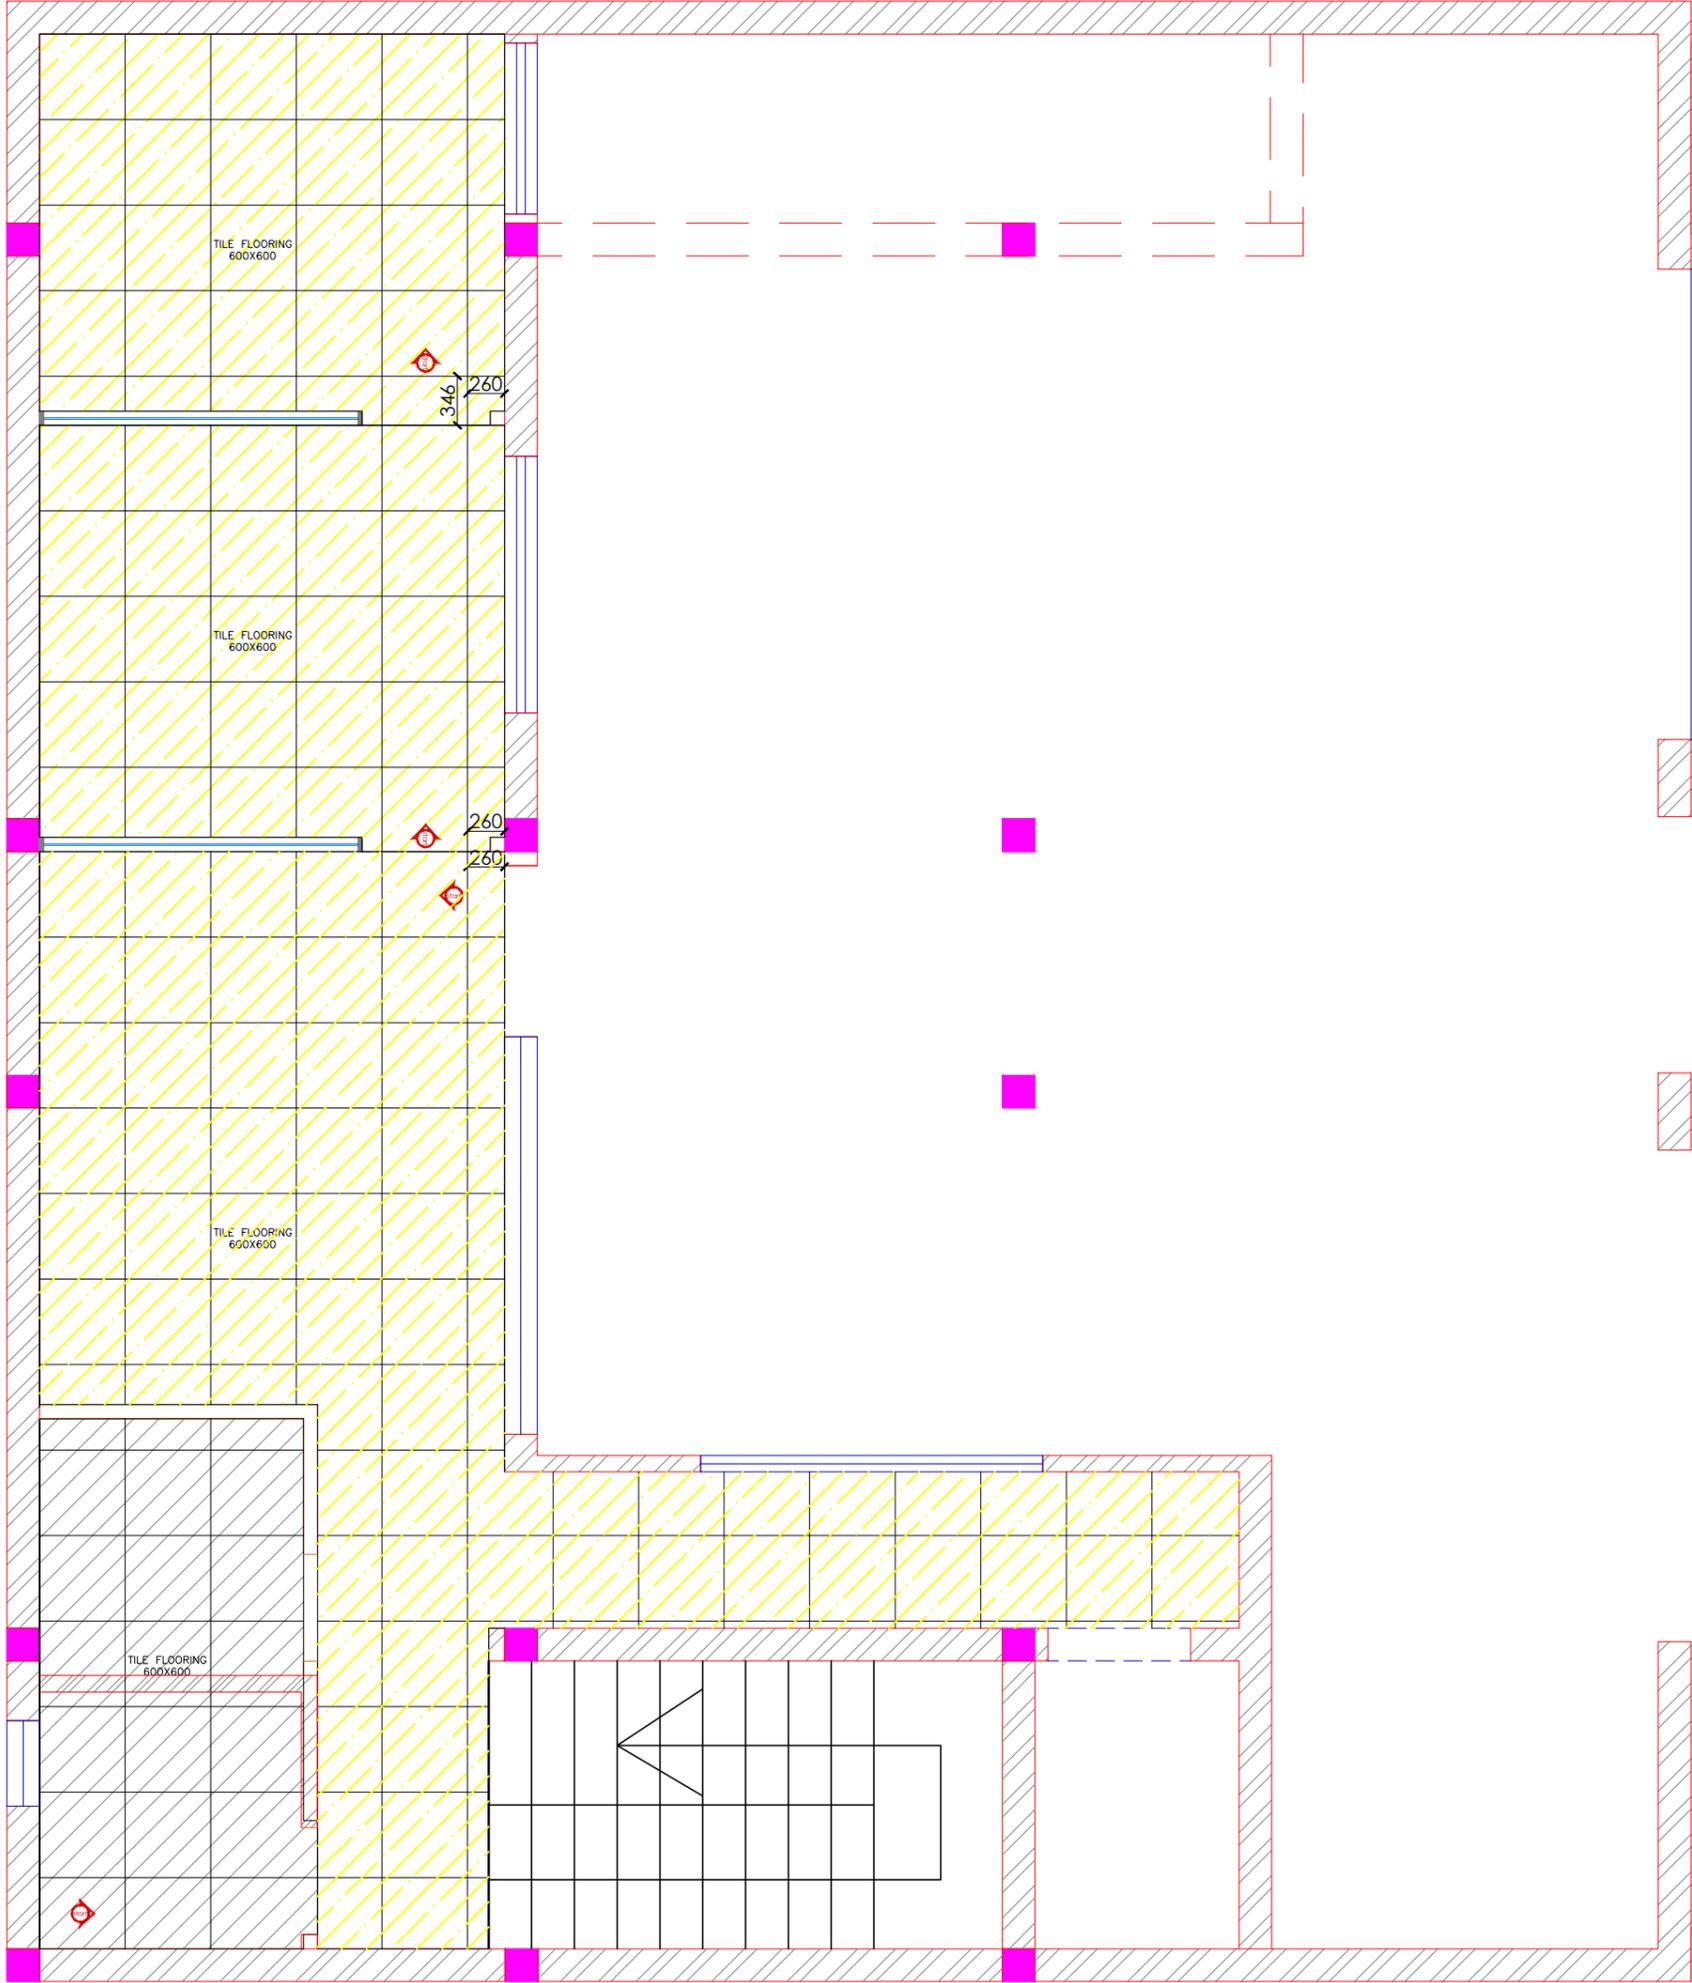

FLOORING LEGEND


	1200X600 TILE 1
	600X600 TILE 2

Client BPCL	Project Title PROPOSED INTERIORS FOR BPCL TERRITORY OFFICE @ VIJAYAWADA	Drawing Title FLOORING LAYOUT	Dwg No BPCL_TO_ID-007				
GENERAL NOTE: 1. DRAWING TO BE USED ONLY FOR THE PURPOSE RELEASED. 2. DO NOT SCALE THIS DRAWING, ONLY WRITTEN DIMENSIONS TO BE FOLLOWED. 3. ANY DISCREPANCY IN THE DRAWING SHOULD BE IMMEDIATELY BROUGHT TO THE NOTICE OF ARCHITECT.	REV	DESCRIPTION	BY	DATE	Drawn KARTHIK		 Architects New Designer Web Pvt Ltd <small>No.185, 2nd Floor, 1st Main road, Nehru nagar, Kandanchavadi, Perungudi, Chennai - 600096 Tel: +91- 044 - 4212511www.designerweb.in</small>
					Checked VYOM		
					Approved VYOM		
					Date 23.01.2024		
					Issued for ISSUEDFORTENDER		

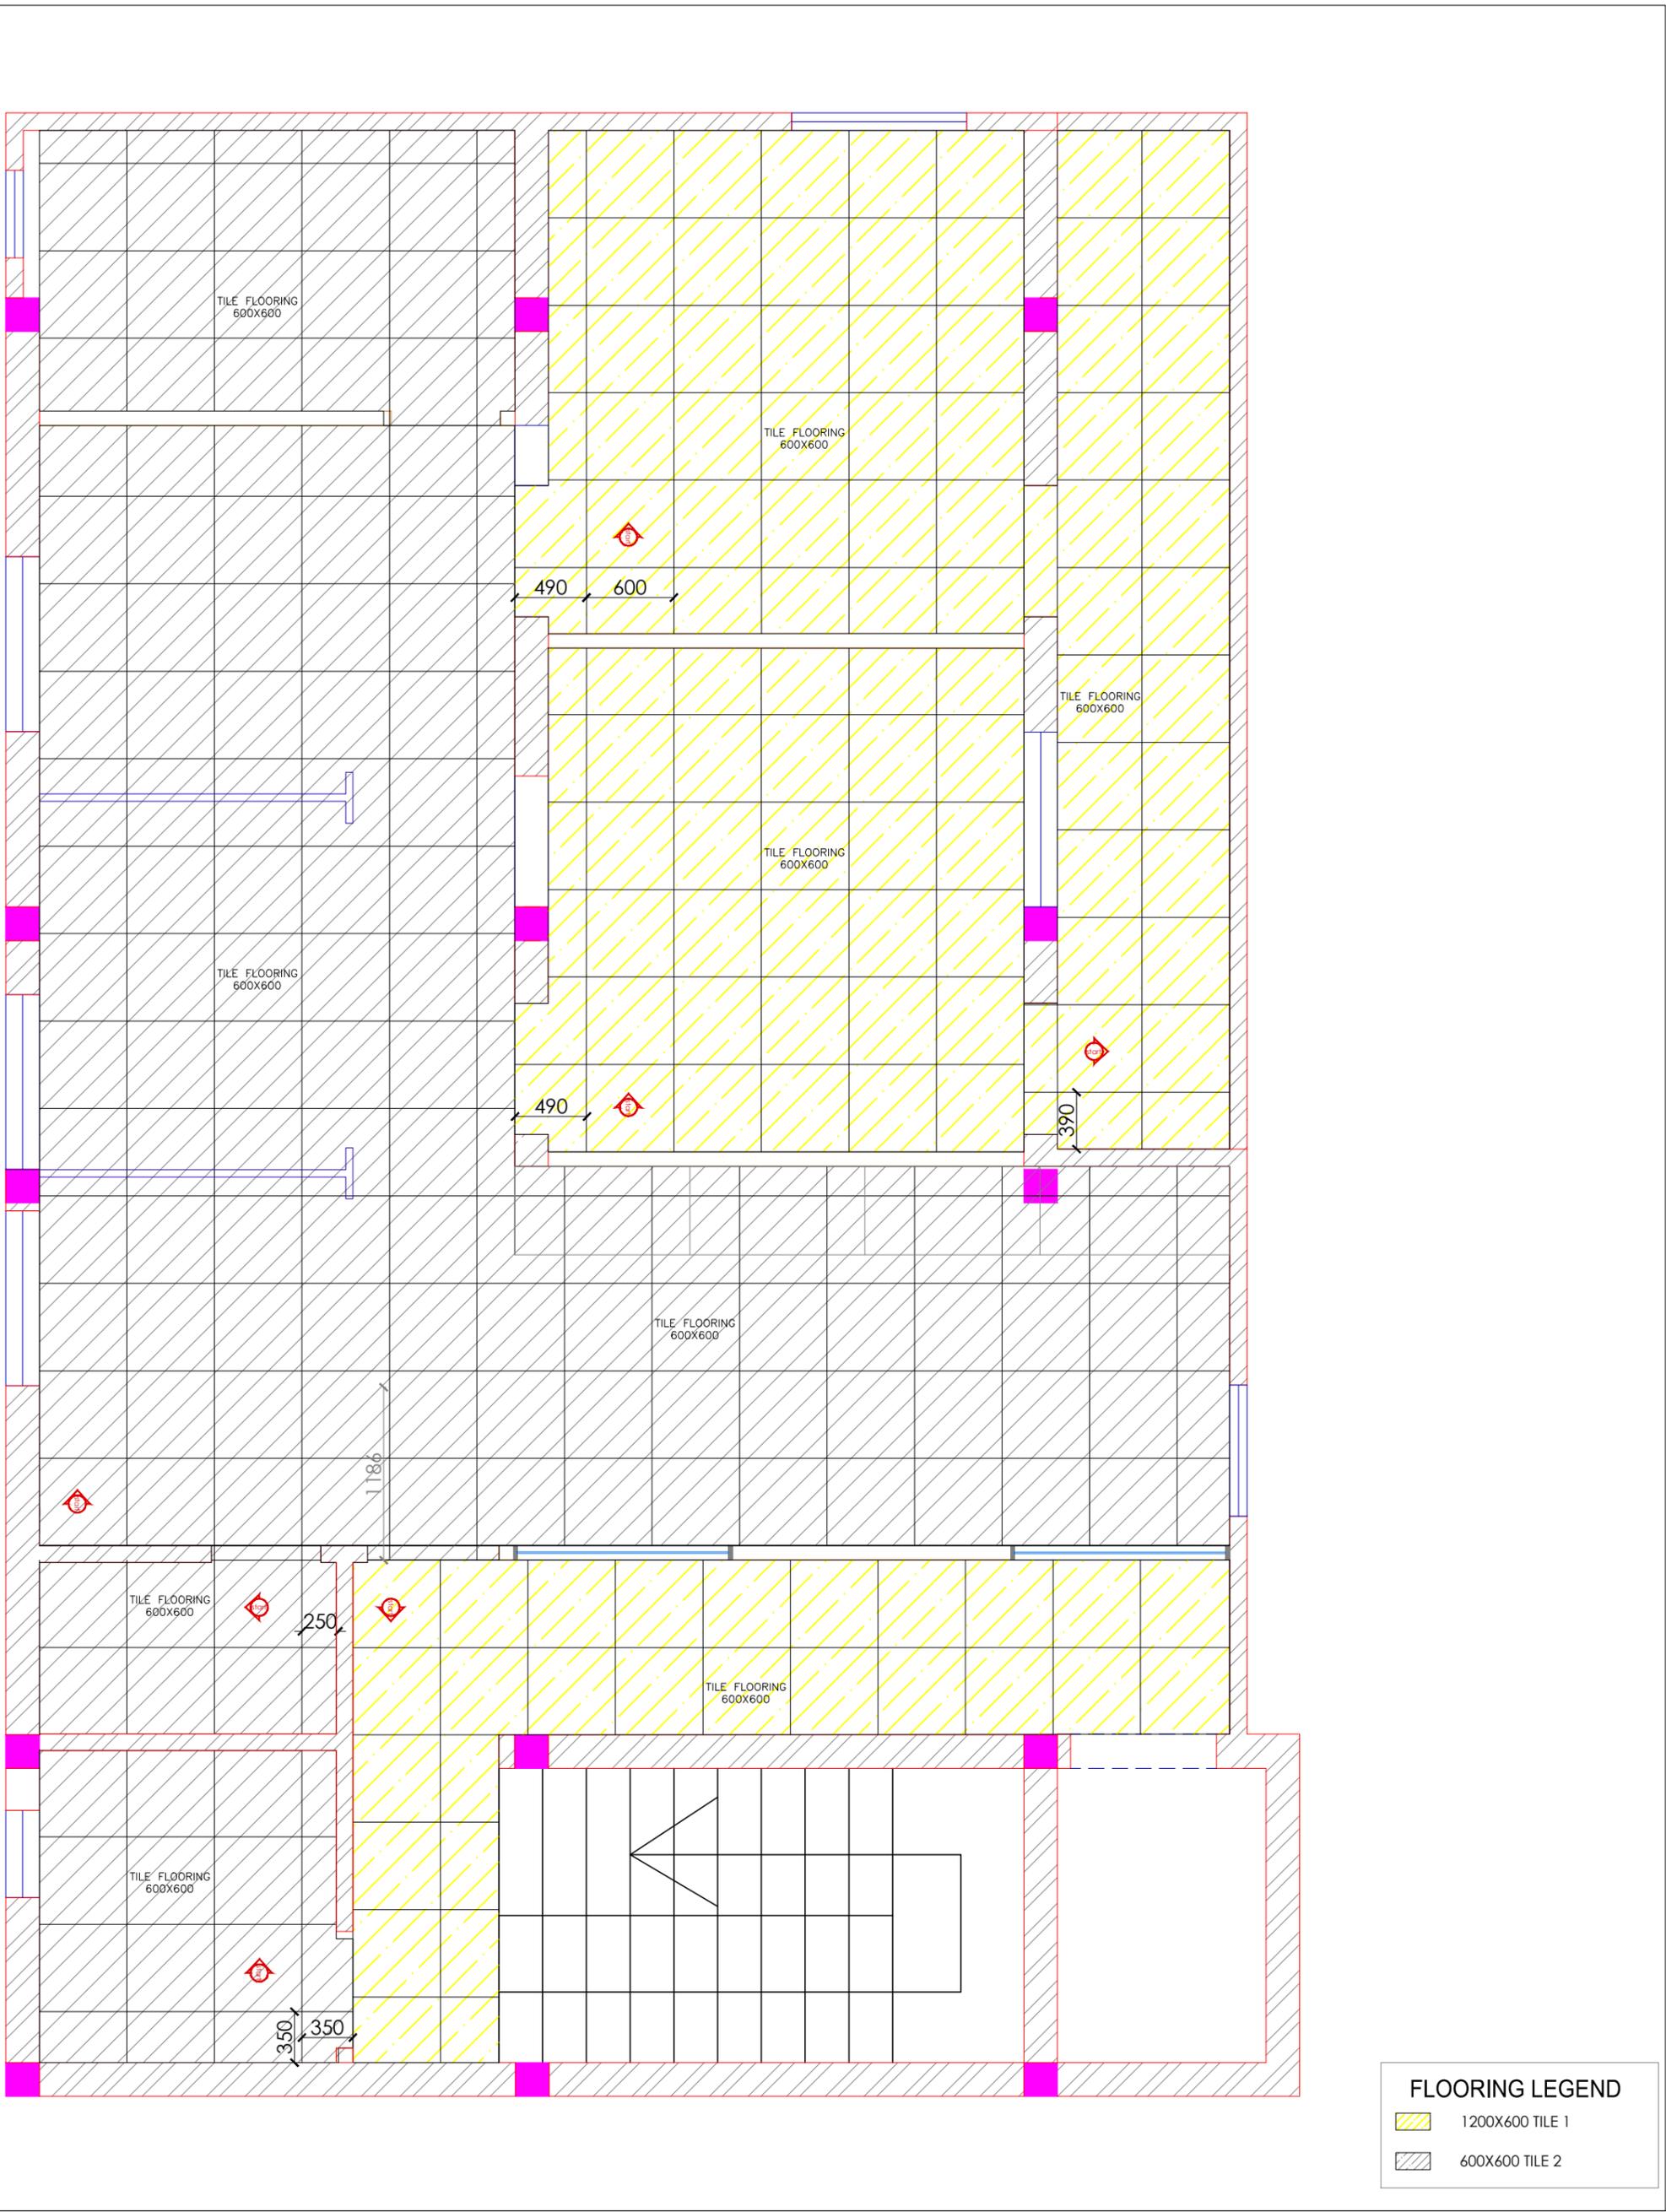


FLOORING LEGEND	
	1200X600 TILE 1
	600X600 TILE 2

Client	BPCL	Project Title	PROPOSED INTERIORS FOR BPCL TERRITORY OFFICE @ VIJAYAWADA		Drawing Title	FLOORING LAYOUT		Dwg No	BPCL_TO_ID-007
GENERAL NOTE: 1. DRAWING TO BE USED ONLY FOR THE PURPOSE RELEASED. 2. DO NOT SCALE THIS DRAWING, ONLY WRITTEN DIMENSIONS TO BE FOLLOWED. 3. ANY DISCREPANCY IN THE DRAWING SHOULD BE IMMEDIATELY BROUGHT TO THE NOTICE OF ARCHITECT.		REV	DESCRIPTION	BY	DATE	Drawn	KARTHIK		Architects New Designer Web Pvt Ltd No.185, 2nd Floor, 1st Main road, Nehru nagar, Kandanchavadi, Perungudi, Chennai - 600096 Tel: +91- 044 - 4212511www.designerweb.in
						Checked	VYOM		
						Approved	VYOM		
						Date	23.01.2024		
						Issued for	ISSUEDFORTENDER		

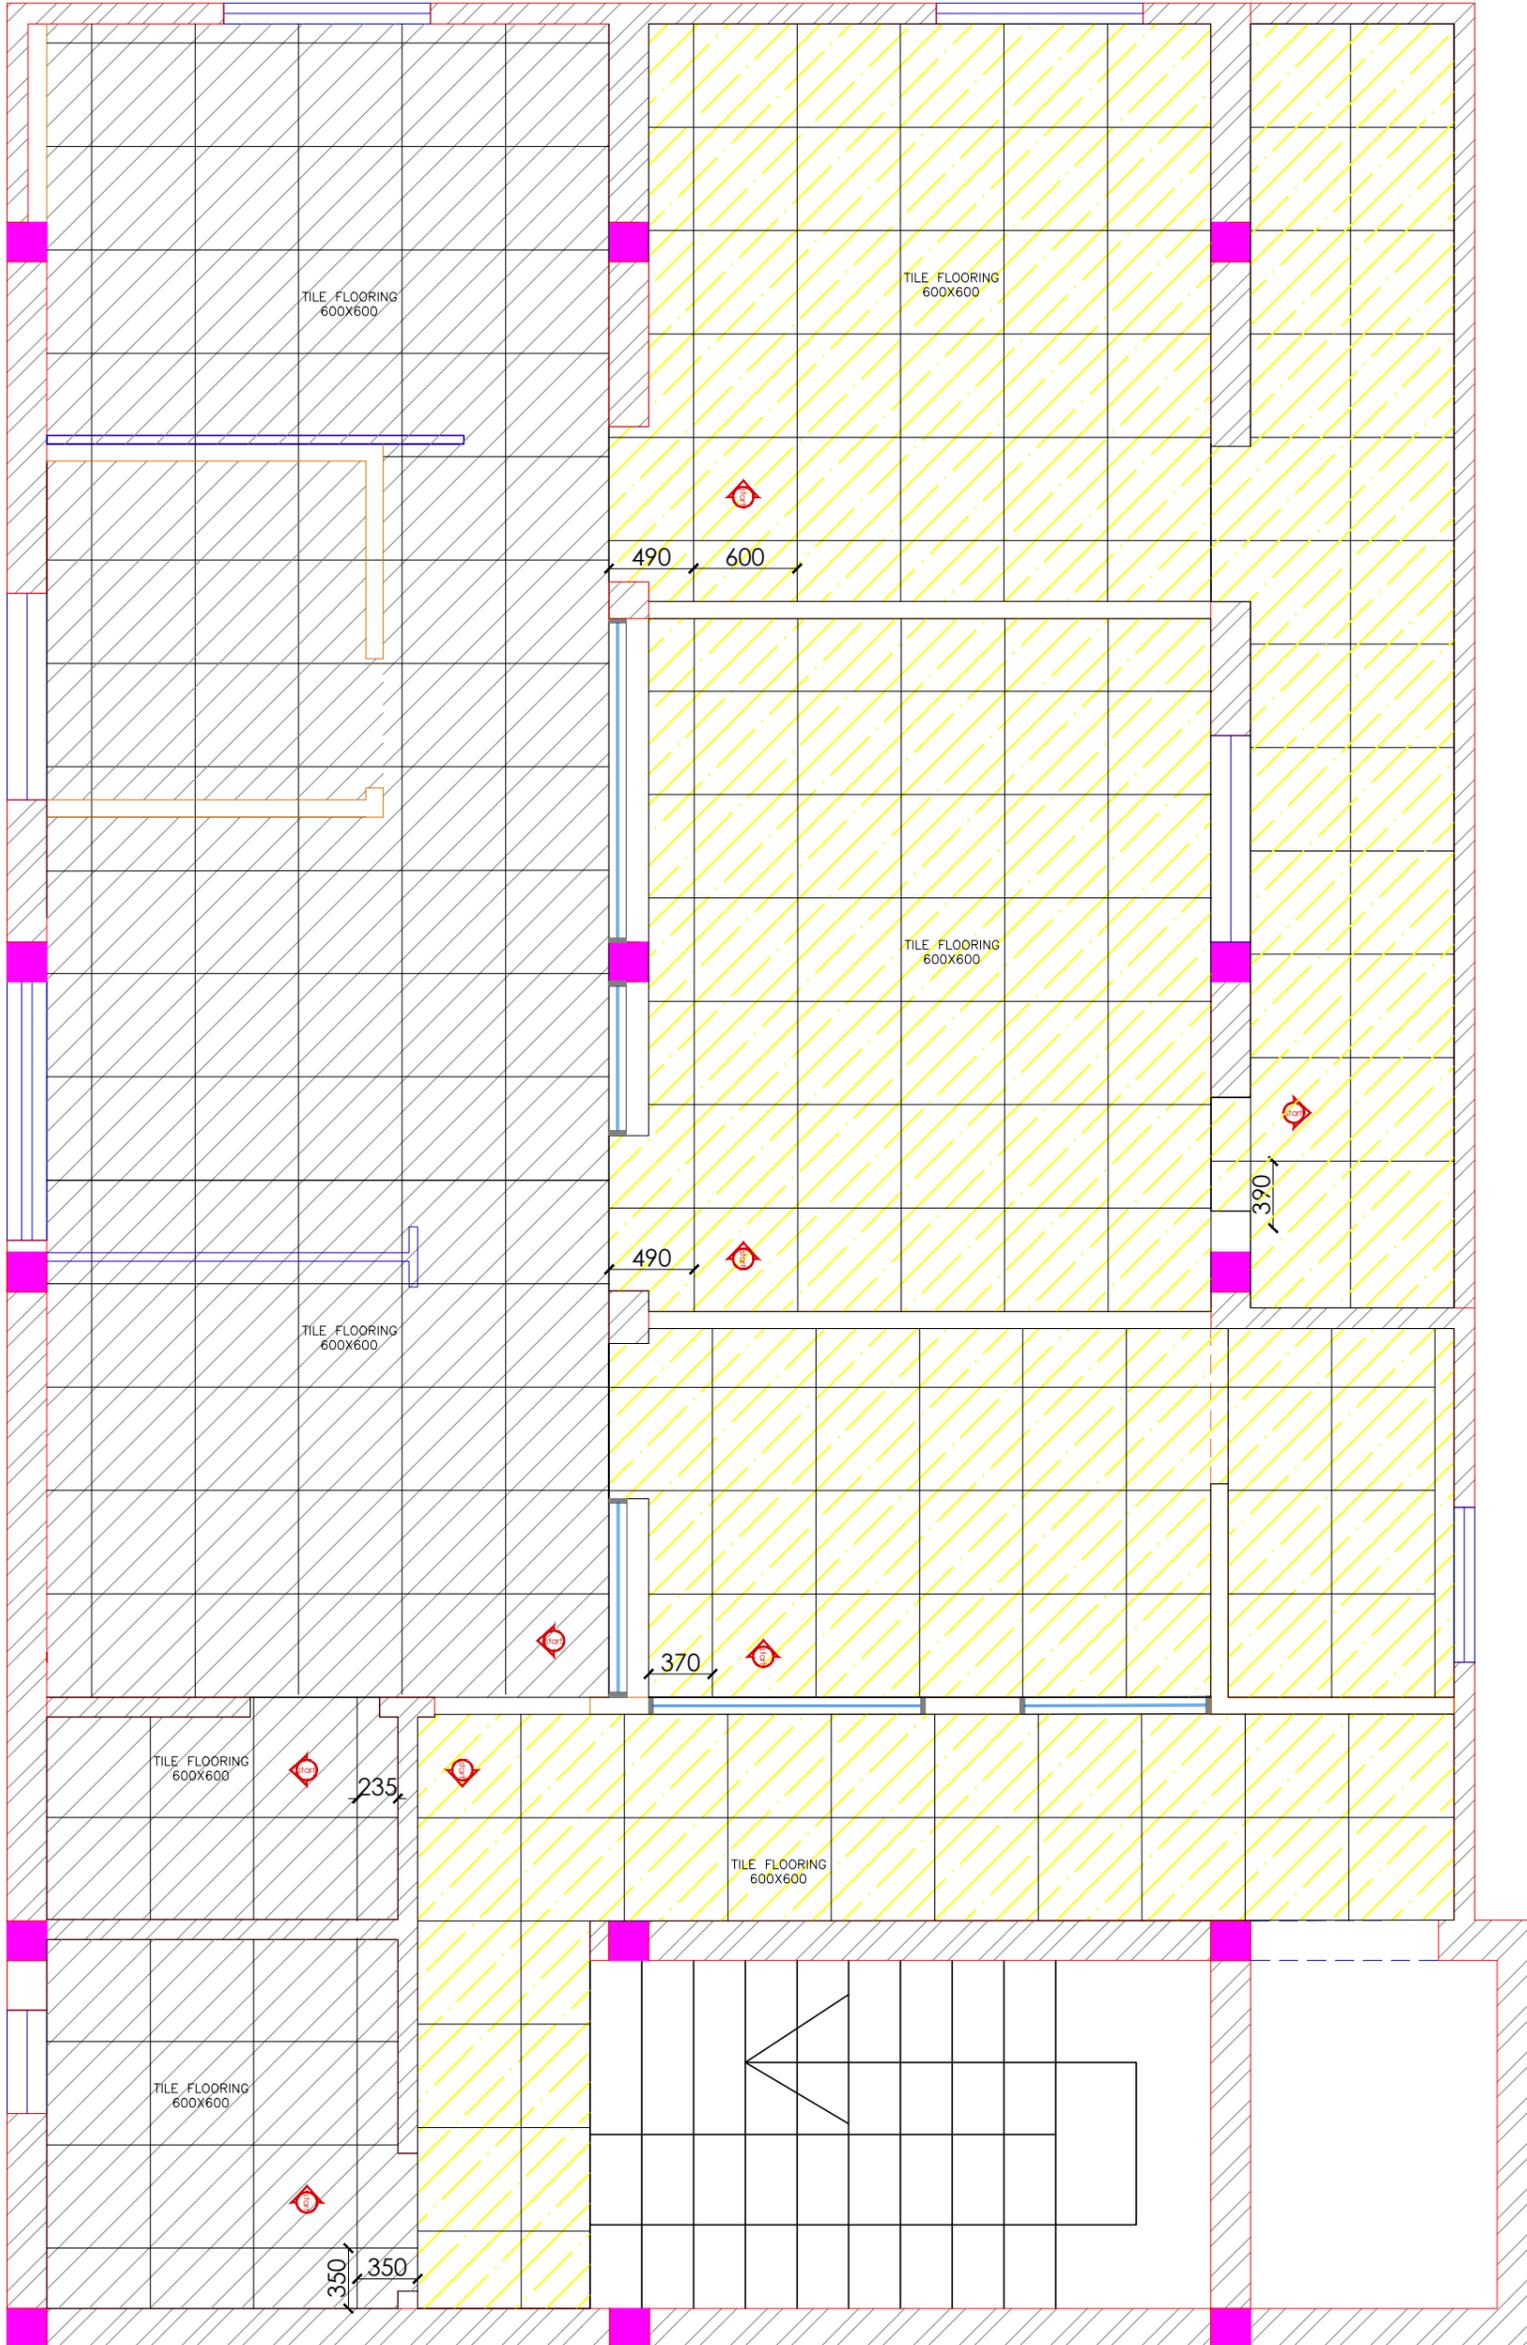

FLOORING LEGEND	
	1200X600 TILE 1
	600X600 TILE 2

Client	BPCL	Project Title	PROPOSED INTERIORS FOR BPCL TERRITORY OFFICE @ VIJAYAWADA		Drawing Title	FLOORING LAYOUT		Dwg No	BPCL_TO_ID-007
GENERAL NOTE: 1. DRAWING TO BE USED ONLY FOR THE PURPOSE RELEASED. 2. DO NOT SCALE THIS DRAWING, ONLY WRITTEN DIMENSIONS TO BE FOLLOWED. 3. ANY DISCREPANCY IN THE DRAWING SHOULD BE IMMEDIATELY BROUGHT TO THE NOTICE OF ARCHITECT.		REV	DESCRIPTION	BY	DATE	Drawn	KARTHIK	 Architects  New Designer Web Pvt Ltd No.185, 2nd Floor, 1st Main road, Nehru nagar, Kandanchavadi, Perungudi, Chennai - 600096 Tel: +91- 044 - 42125111www.designerweb.in	
						Checked	VYOM		
						Approved	VYOM		
						Date	23.01.2024		
						Issued for	ISSUEDFORTENDER		

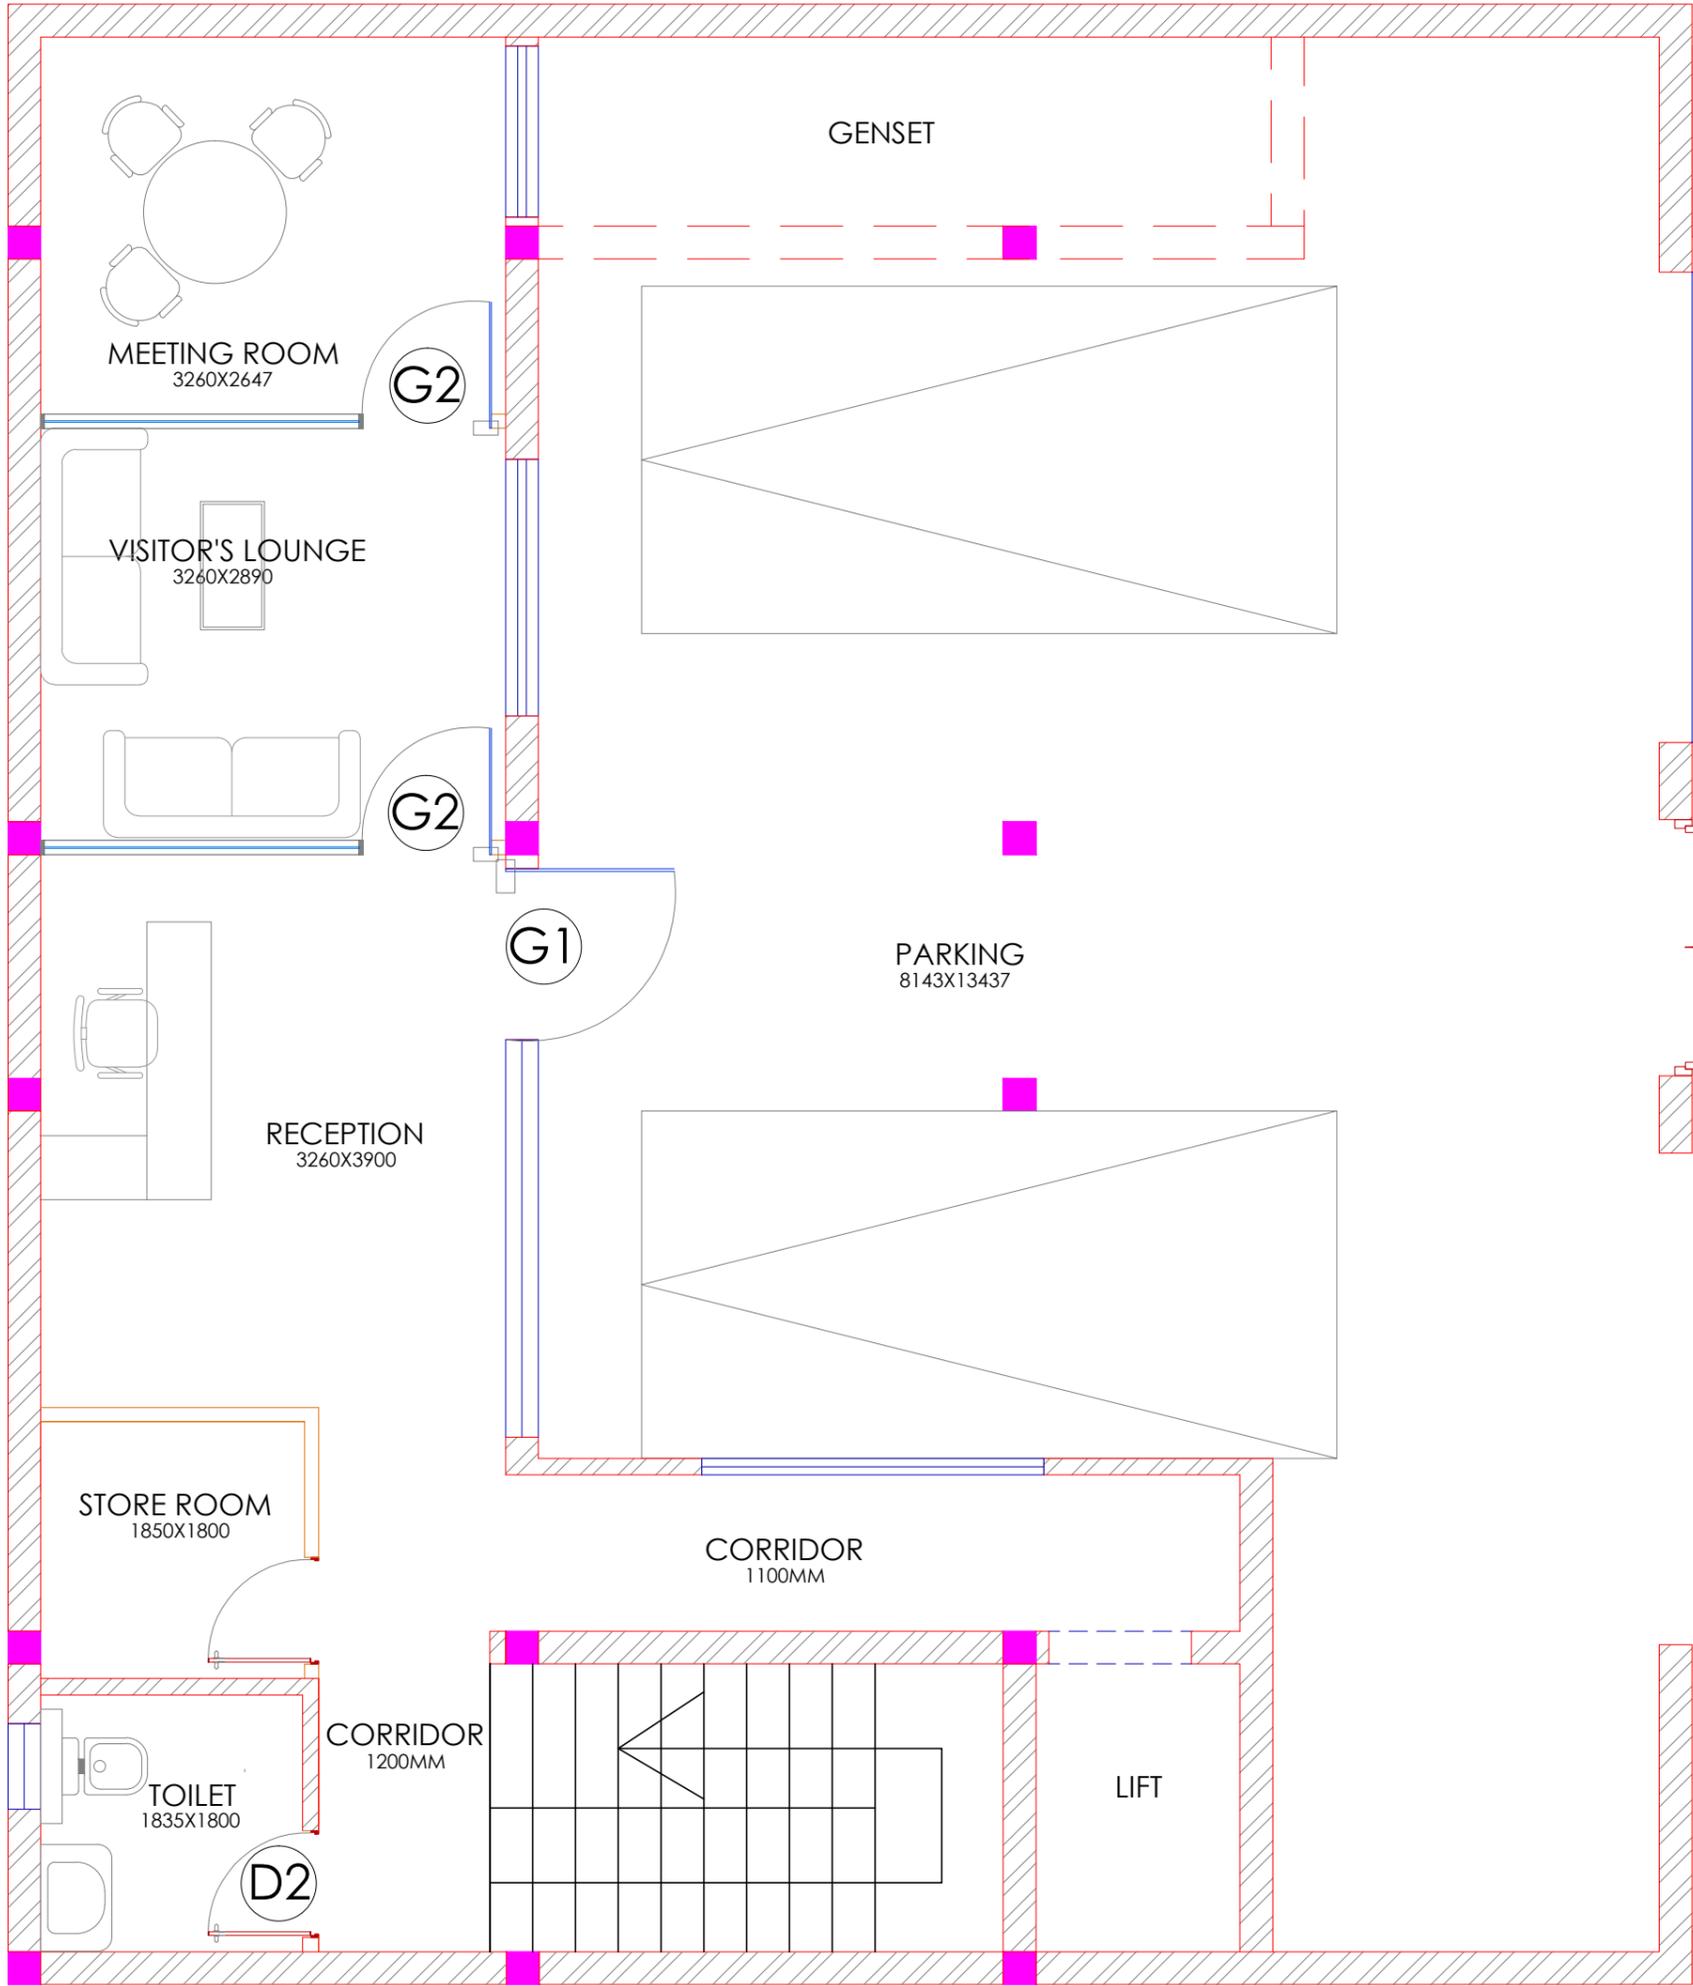


GROUND FLOOR PLAN

LEGEND

TAG	DESCRIPTION	SIZE	NOS
G1	GLASS DOOR	1200X2100	01
G2	GLASS DOOR	900X2100	09
D1	FLUSH DOOR	900X2100	04
D2	FLUSH DOOR	750X2100	07

Client	BPCL	Project Title	PROPOSED INTERIORS FOR BPCL TERRITORY OFFICE @ VIJAYAWADA	Drawing Title	DOOR SCHEDULE	Dwg No	BPCL_TO_TD-008
GENERAL NOTE: 1. DRAWING TO BE USED ONLY FOR THE PURPOSE RELEASED. 2. DO NOT SCALE THIS DRAWING, ONLY WRITTEN DIMENSIONS TO BE FOLLOWED. 3. ANY DISCREPANCY IN THE DRAWING SHOULD BE IMMEDIATELY BROUGHT TO THE NOTICE OF ARCHITECT.		REV	DESCRIPTION	BY	DATE	Drawn	KARTHIK
						Checked	VYOM
						Approved	VYOM
						Date	23.01.2024
						Issued for	ISSUEDFORTENDER
						New Designer Web Pvt Ltd No.185, 2nd Floor, 1st Main road, Nehru nagar, Kandanchavadi, Perungudi, Chennai - 600096 Tel: +91- 044 - 4212511www.designerweb.in	

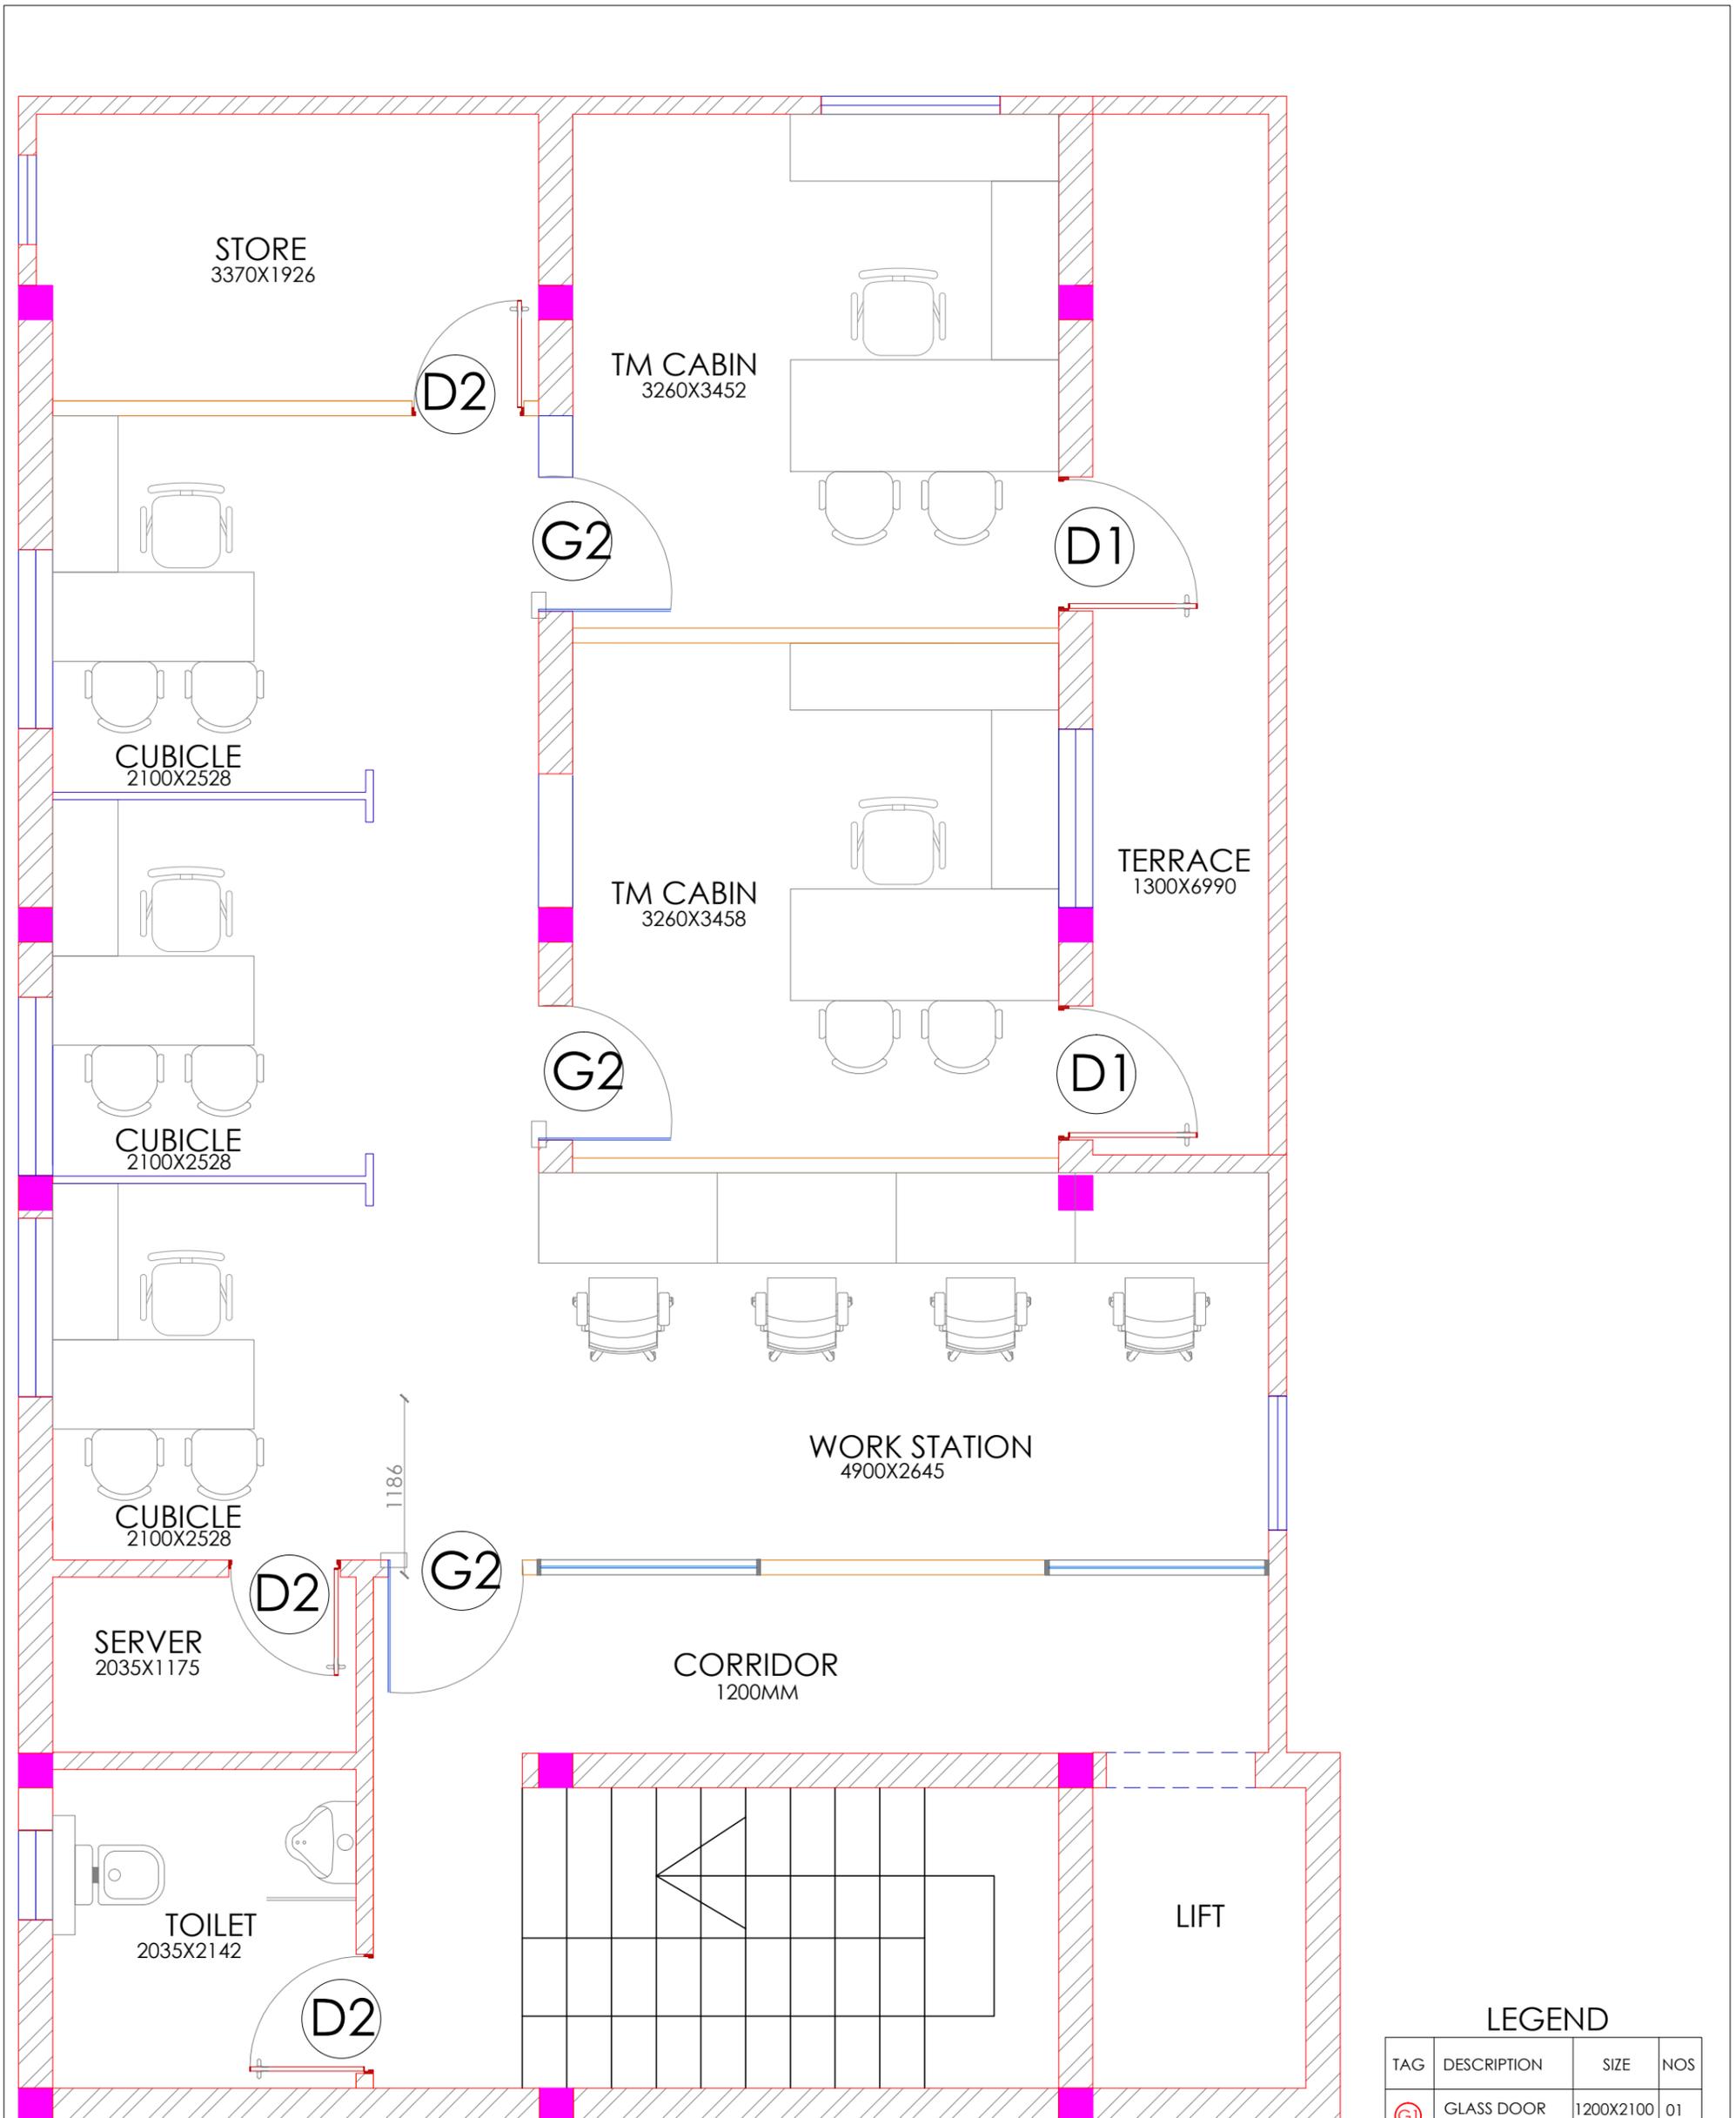

FIRST FLOOR PLAN

LEGEND


TAG	DESCRIPTION	SIZE	NOS
G1	GLASS DOOR	1200X2100	01
G2	GLASS DOOR	900X2100	09
D1	FLUSH DOOR	900X2100	04
D2	FLUSH DOOR	750X2100	07

Client	BPCL	Project Title	PROPOSED INTERIORS FOR BPCL TERRITORY OFFICE @ VIJAYAWADA	Drawing Title	DOOR SCHEDULE	Dwg No	BPCL_TO_TD-008
GENERAL NOTE:		REV	DESCRIPTION	BY	DATE	Drawn	KARTHIK
1. DRAWING TO BE USED ONLY FOR THE PURPOSE RELEASED.						Checked	VYOM
2. DO NOT SCALE THIS DRAWING, ONLY WRITTEN DIMENSIONS TO BE FOLLOWED.						Approved	VYOM
3. ANY DISCREPANCY IN THE DRAWING SHOULD BE IMMEDIATELY BROUGHT TO THE NOTICE OF ARCHITECT.						Date	23.01.2024
						Issued for	ISSUEDFORTENDER
						Scale	SCALE



Architects

New Designer Web Pvt Ltd
 No.185, 2nd Floor, 1st Main road, Nehru nagar,
 Kandanchavadi, Perungudi, Chennai - 600096
 Tel: +91- 044 - 4212511www.designerweb.in

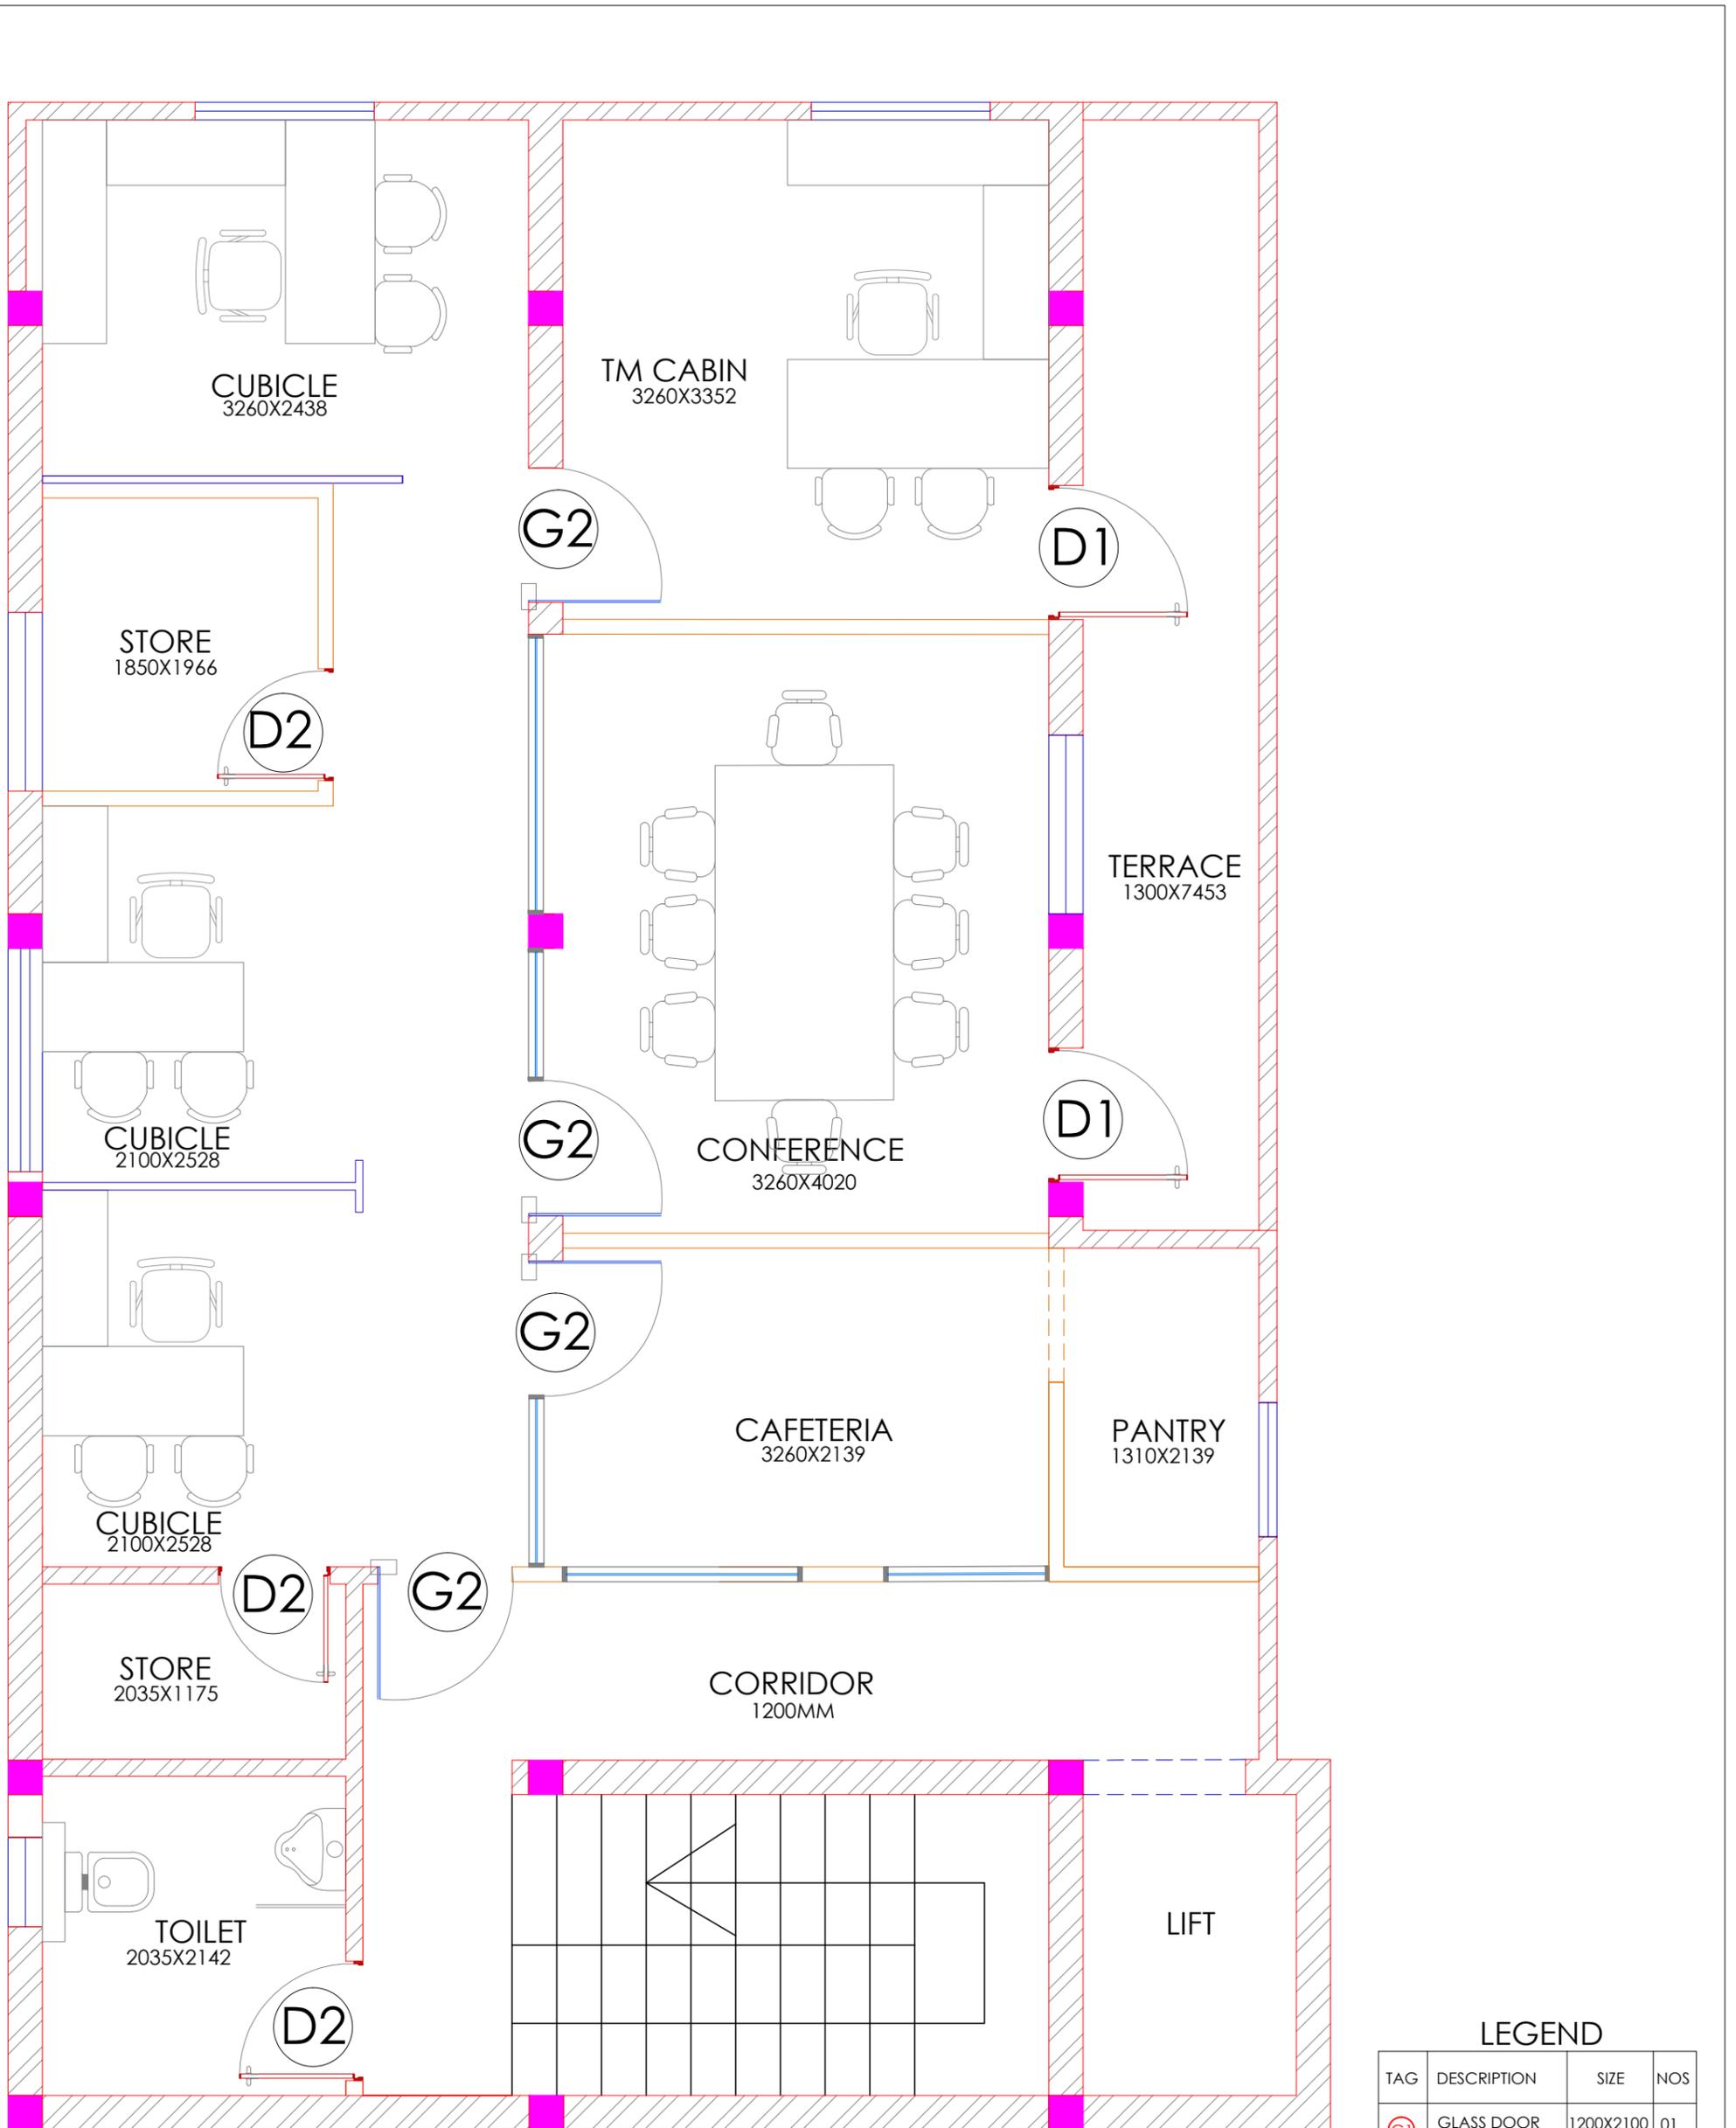


SECOND FLOOR PLAN

LEGEND

TAG	DESCRIPTION	SIZE	NOS
G1	GLASS DOOR	1200X2100	01
G2	GLASS DOOR	900X2100	09
D1	FLUSH DOOR	900X2100	04
D2	FLUSH DOOR	750X2100	07


Client	BPCL	Project Title	PROPOSED INTERIORS FOR BPCL TERRITORY OFFICE @ VIJAYAWADA	Drawing Title	DOOR SCHEDULE	Dwg No	BPCL_TO_TD-008	
GENERAL NOTE:		REV	DESCRIPTION	BY	DATE	Architects		
1. DRAWING TO BE USED ONLY FOR THE PURPOSE RELEASED.						New Designer Web Pvt Ltd		
2. DO NOT SCALE THIS DRAWING, ONLY WRITTEN DIMENSIONS TO BE FOLLOWED.						No.185, 2nd Floor, 1st Main road, Nehru nagar, Kandanchavadi, Perungudi, Chennai - 600096		
3. ANY DISCREPANCY IN THE DRAWING SHOULD BE IMMEDIATELY BROUGHT TO THE NOTICE OF ARCHITECT.						Tel: +91- 044 - 42125111www.designerweb.in		
					Drawn	KARTHIK		
					Checked	VYOM		
					Approved	VYOM		
					Date	23.01.2024		
					Issued for	ISSUEDFORTENDER	Scale	SCALE

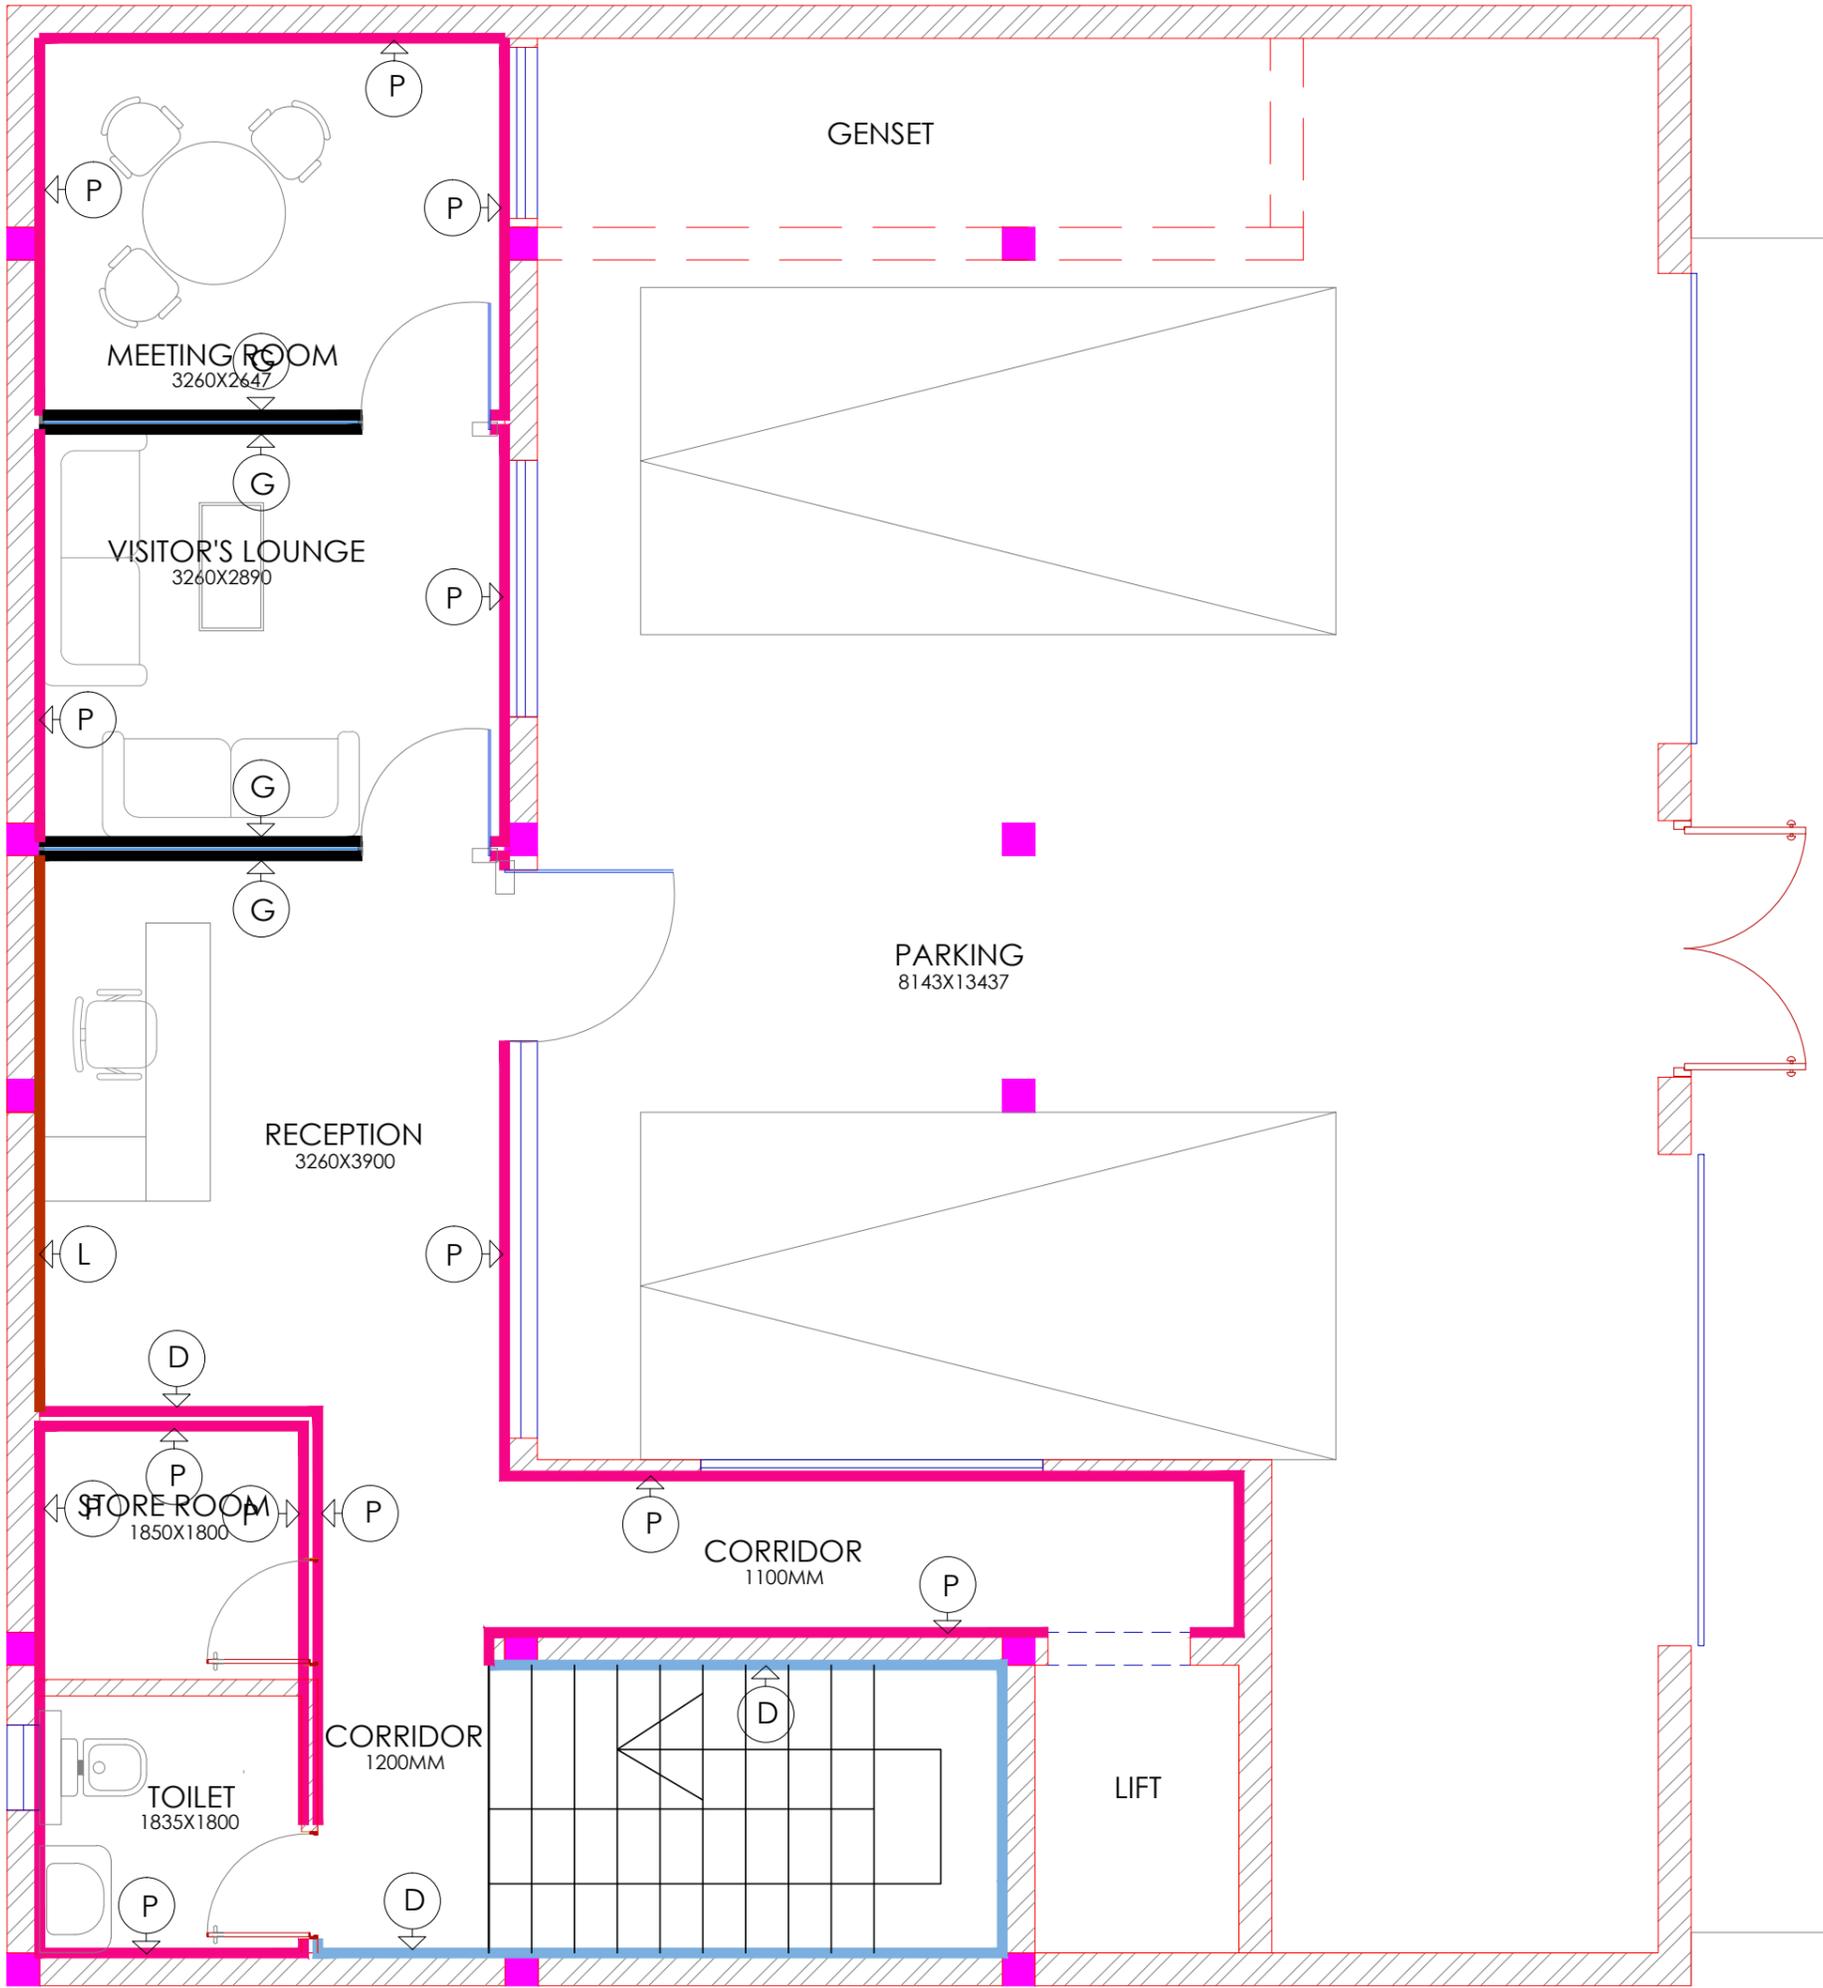

GROUND FLOOR PLAN

LEGEND		
SYMBOL	TAG	DESCRIPTION
	(P)	PAINT FINISH
	(G)	GLASS
	(L)	LAMINATE FINISH
	(D)	DINOC FINISH
	(LG)	LAQUERED GLASS
	(GR)	GRAPHIC FINISH
	(TP)	TEXTURE PAINT


Client	BPCL	Project Title	PROPOSED INTERIORS FOR BPCL TERRITORY OFFICE @ VIJAYAWADA	Drawing Title	FINISHES LAYOUT	Dwg No	BPCL_TO_TD-010
GENERAL NOTE: 1. DRAWING TO BE USED ONLY FOR THE PURPOSE RELEASED. 2. DO NOT SCALE THIS DRAWING, ONLY WRITTEN DIMENSIONS TO BE FOLLOWED. 3. ANY DISCREPANCY IN THE DRAWING SHOULD BE IMMEDIATELY BROUGHT TO THE NOTICE OF ARCHITECT.		REV	DESCRIPTION	BY	DATE	Drawn	KARTHIK
						Checked	VYOM
						Approved	VYOM
						Date	23.01.2024
						Issued for	ISSUEDFORTENDER
						Architects New Designer Web Pvt Ltd No.185, 2nd Floor, 1st Main road, Nehru nagar, Kandanchavadi, Perungudi, Chennai - 600096 Tel: +91- 044 - 4212511www.designerweb.in	

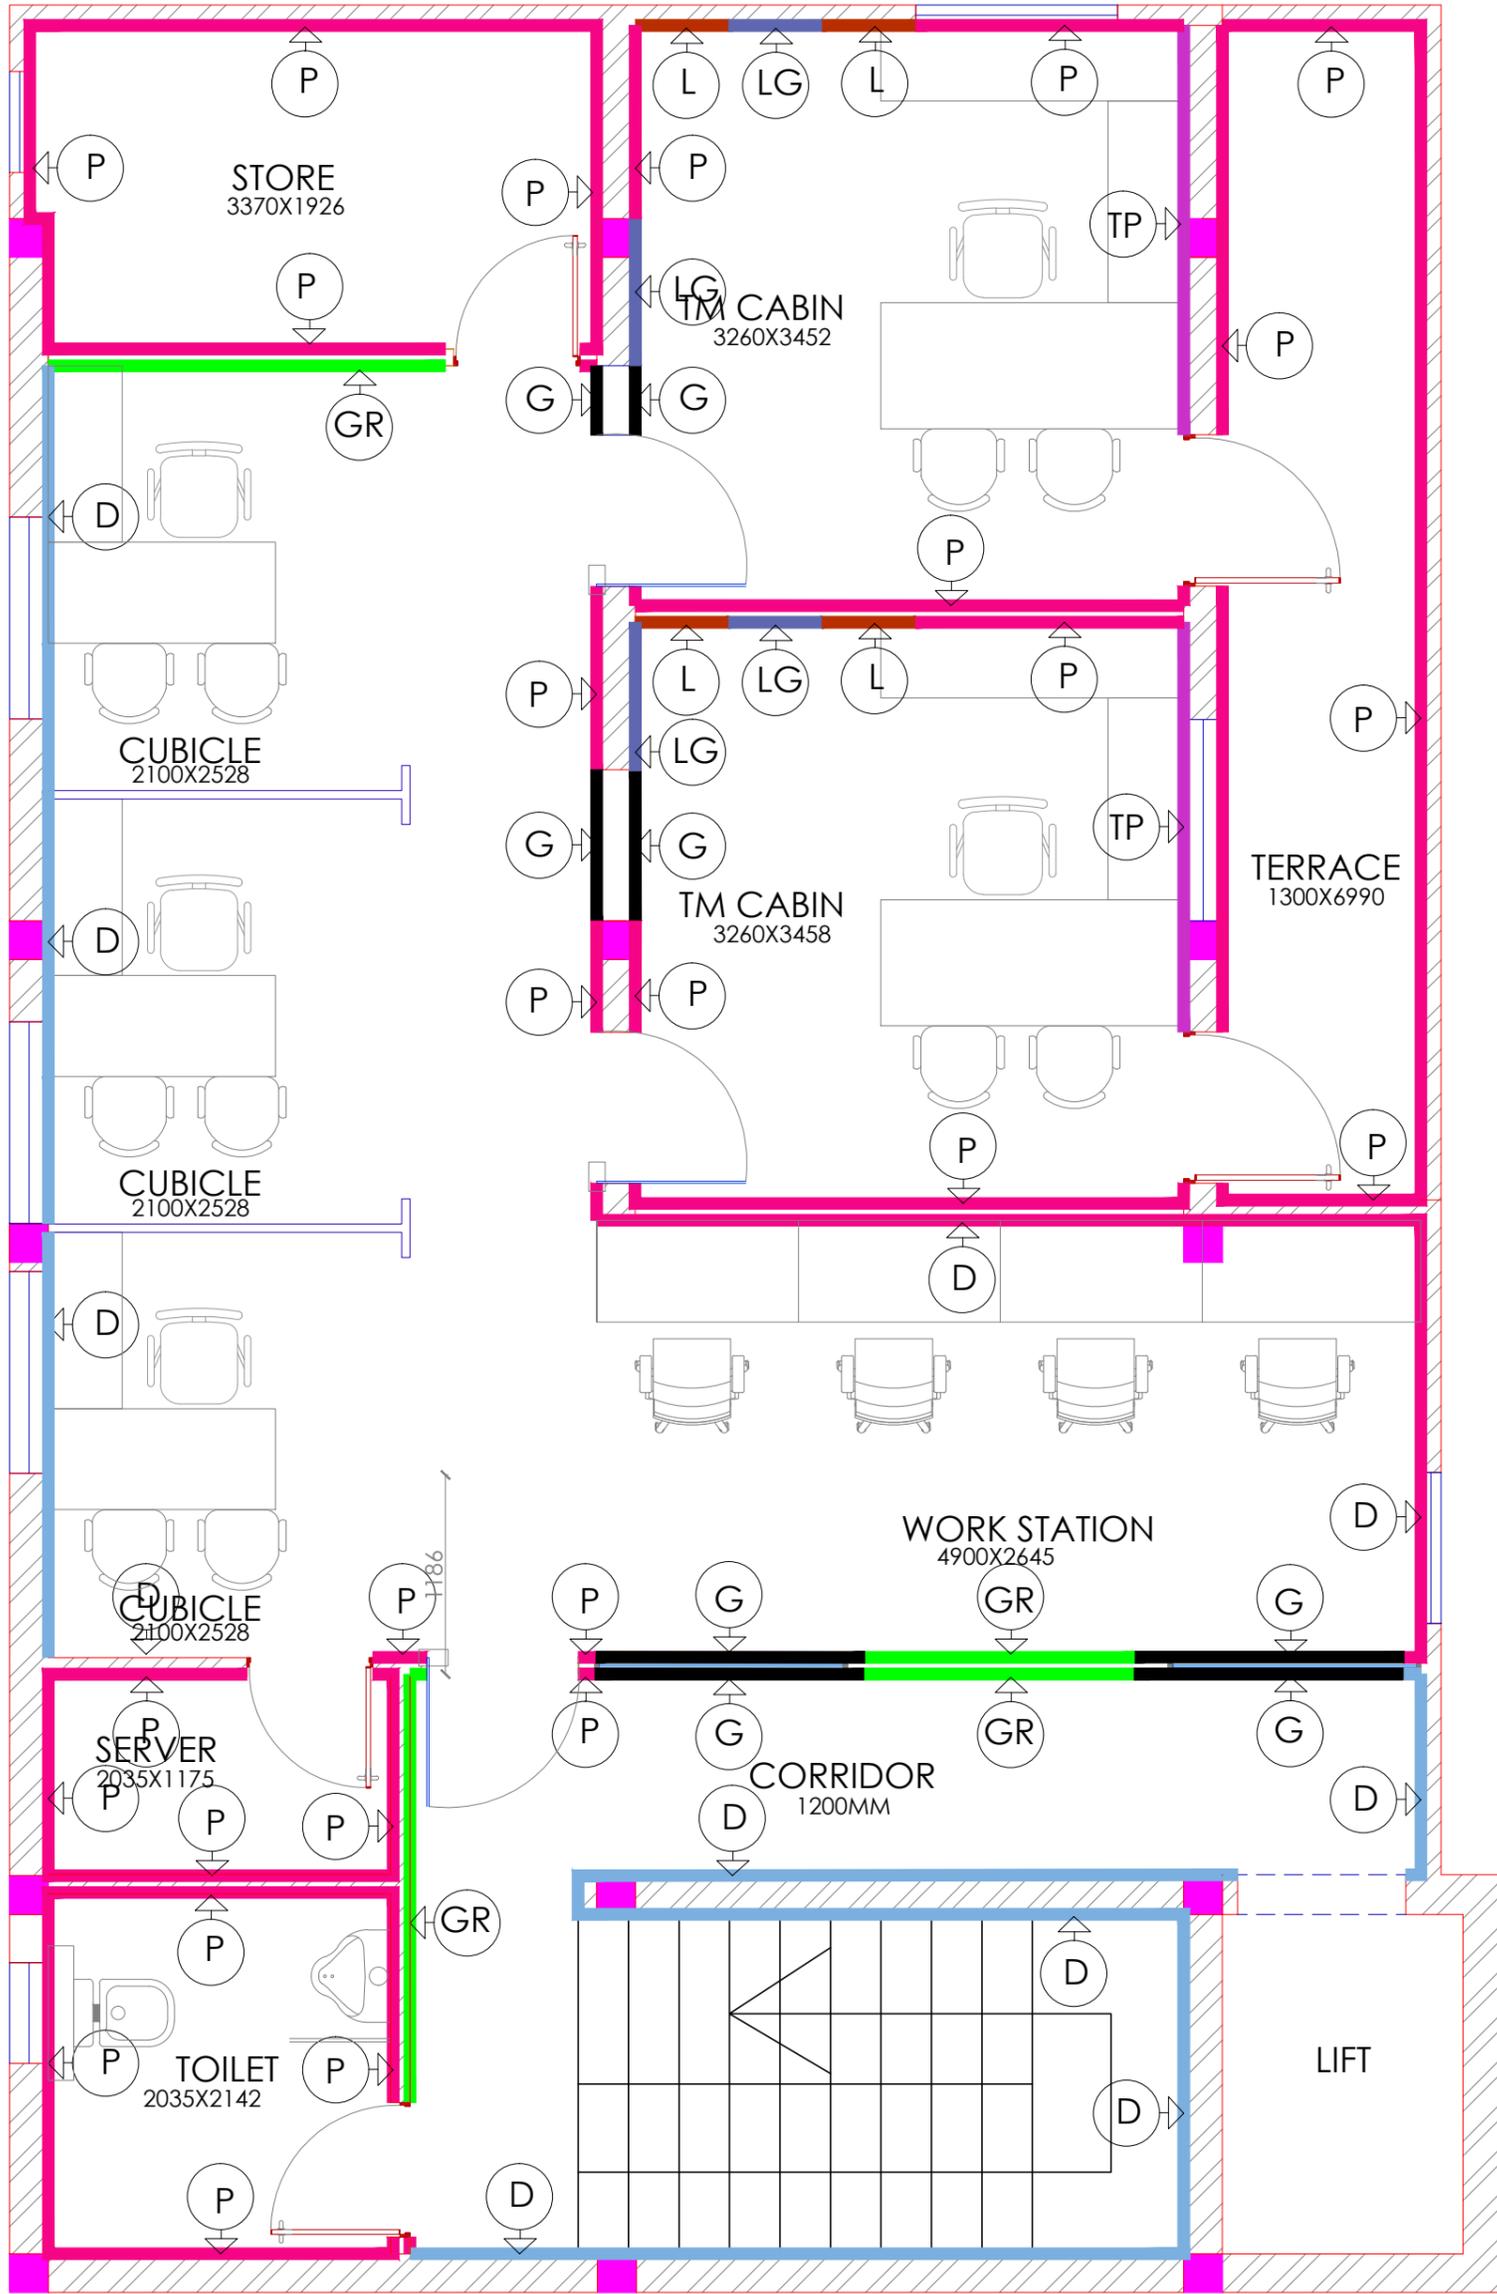

FIRST FLOOR PLAN

LEGEND		
SYMBOL	TAG	DESCRIPTION
	(P)	PAINT FINISH
	(G)	GLASS
	(L)	LAMINATE FINISH
	(D)	DINOC FINISH
	(LG)	LAQUERED GLASS
	(GR)	GRAPHIC FINISH
	(TP)	TEXTURE PAINT


Client	BPCL	Project Title	PROPOSED INTERIORS FOR BPCL TERRITORY OFFICE @ VIJAYAWADA	Drawing Title	FINISHES LAYOUT	Dwg No	BPCL_TO_ID-010
GENERAL NOTE: 1. DRAWING TO BE USED ONLY FOR THE PURPOSE RELEASED. 2. DO NOT SCALE THIS DRAWING, ONLY WRITTEN DIMENSIONS TO BE FOLLOWED. 3. ANY DISCREPANCY IN THE DRAWING SHOULD BE IMMEDIATELY BROUGHT TO THE NOTICE OF ARCHITECT.		REV	DESCRIPTION	BY	DATE	Drawn	KARTHIK
						Checked	VYOM
						Approved	VYOM
						Date	23.01.2024
						Issued for	ISSUEDFORTENDER
						Architects New Designer Web Pvt Ltd No.185, 2nd Floor, 1st Main road, Nehru nagar, Kandanchavadi, Perungudi, Chennai - 600096 Tel: +91- 044 - 42125111www.designerweb.in	

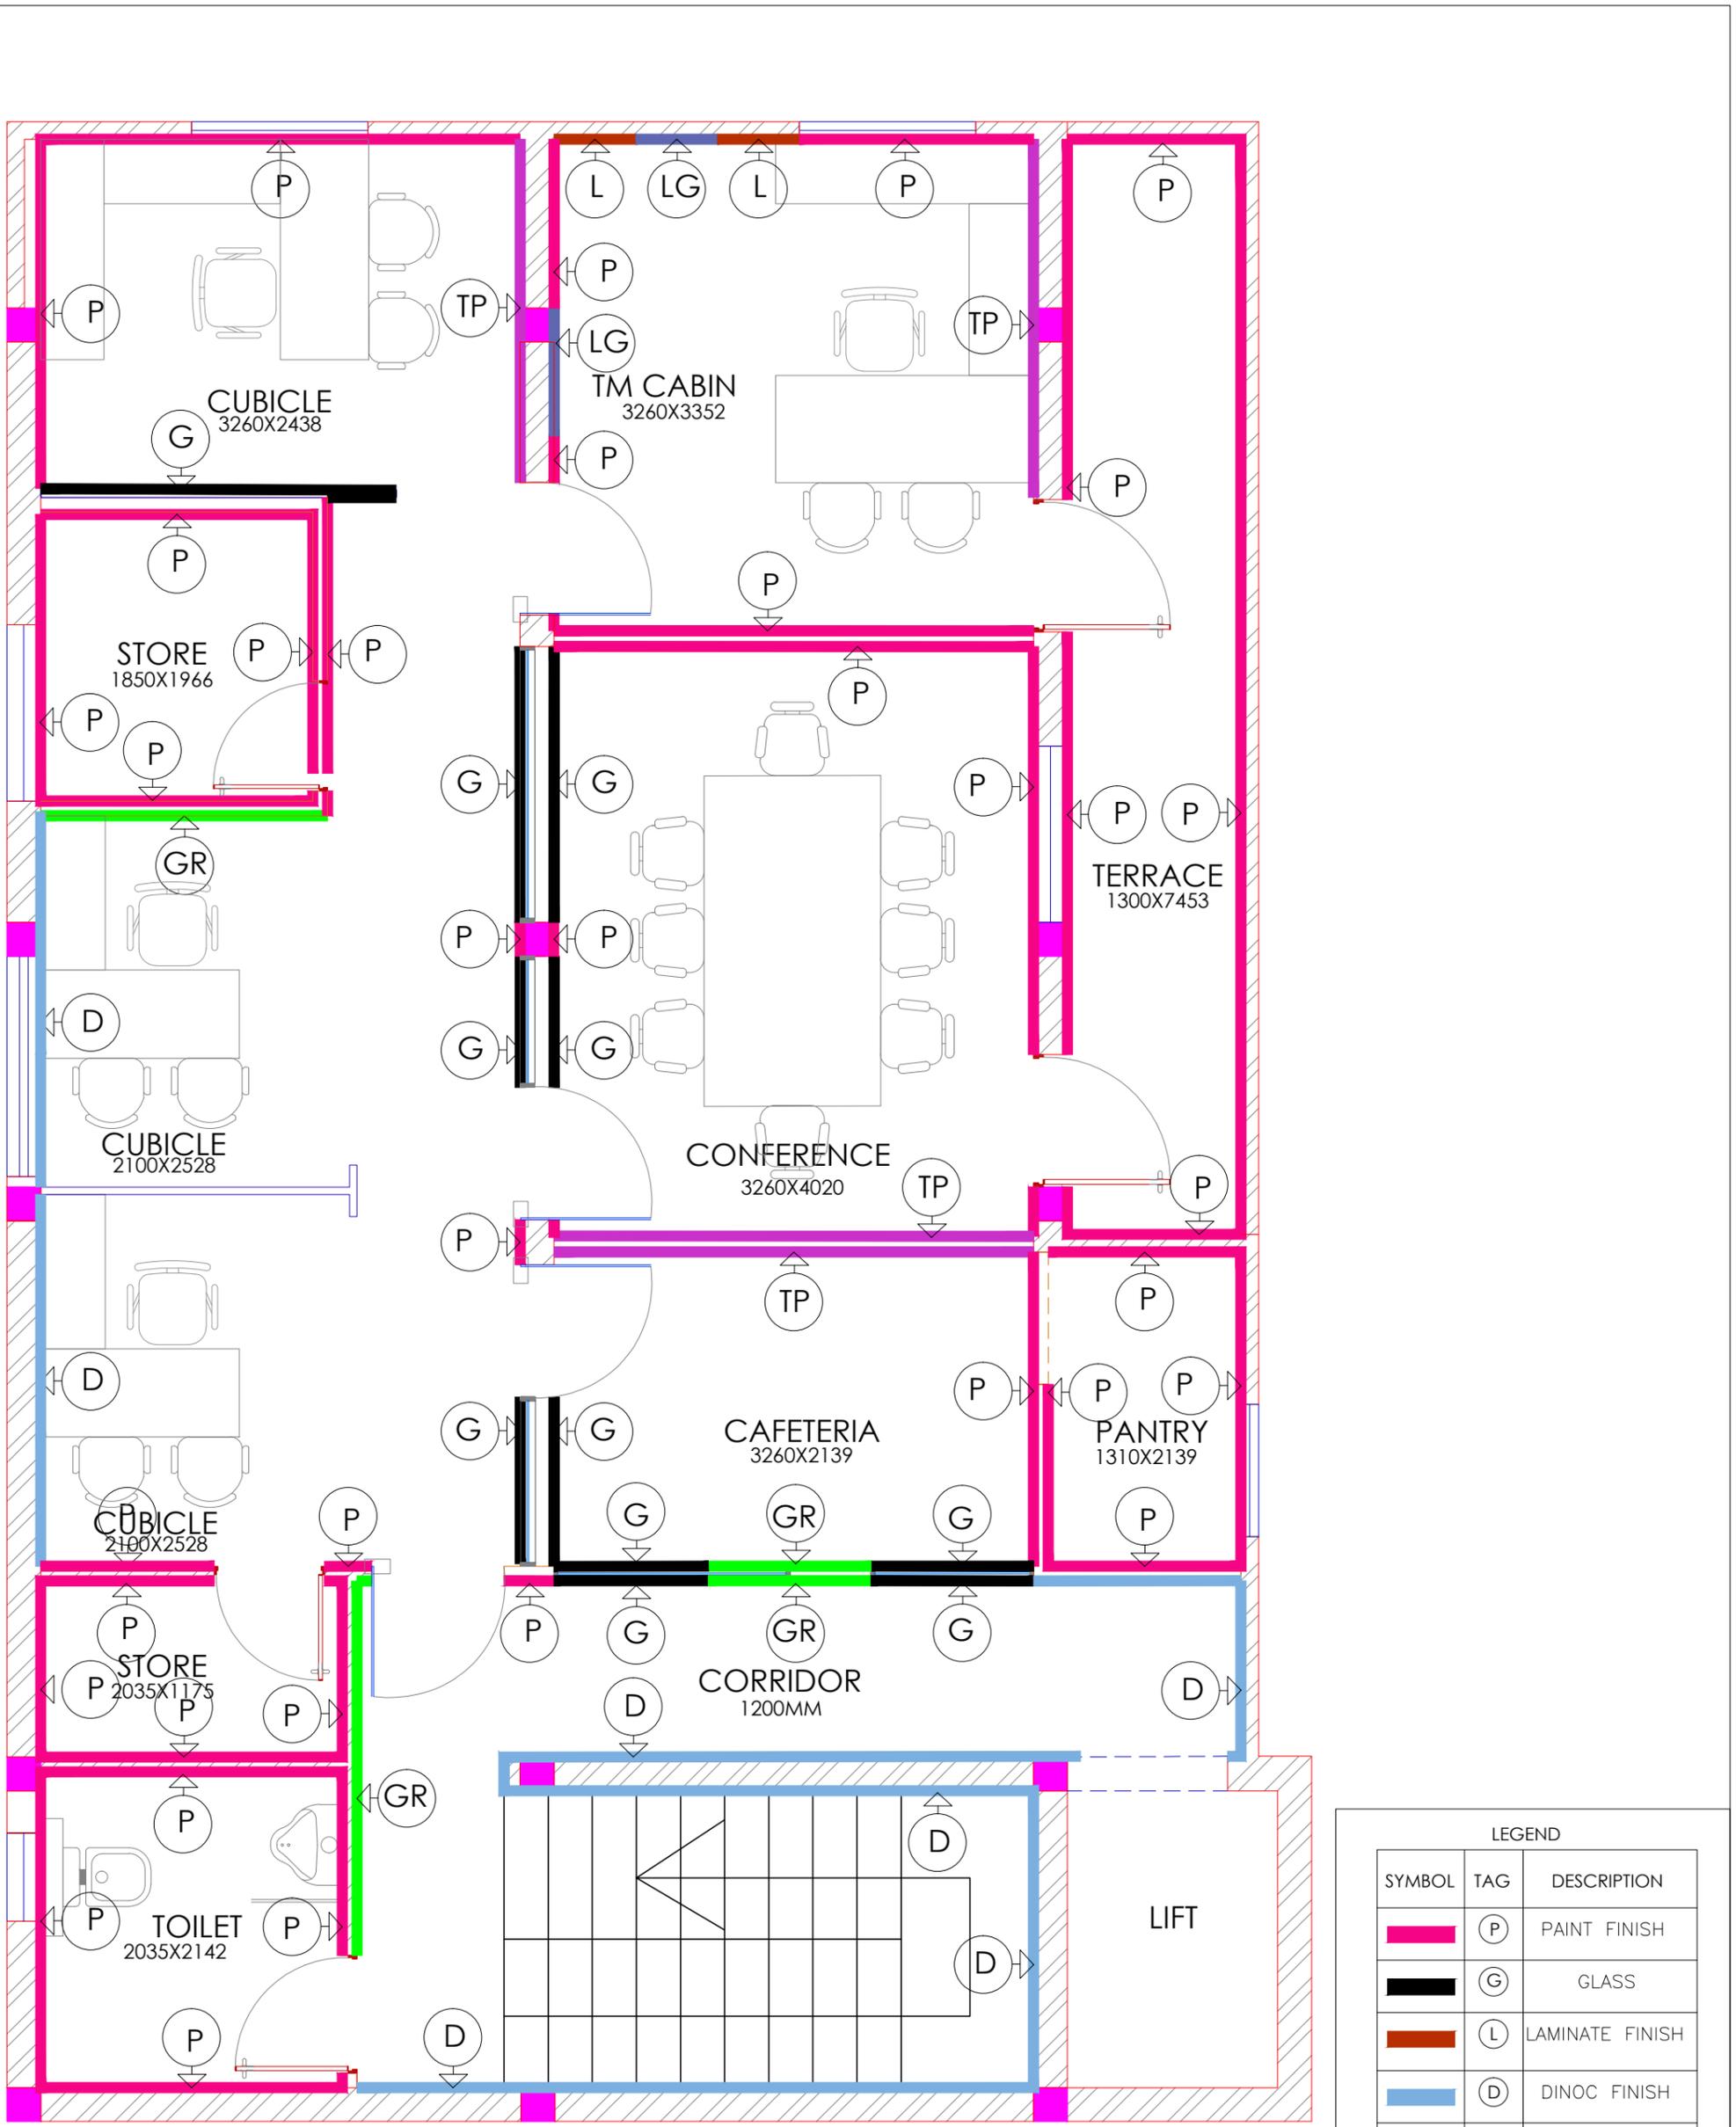

SECOND FLOOR PLAN

LEGEND		
SYMBOL	TAG	DESCRIPTION
	(P)	PAINT FINISH
	(G)	GLASS
	(L)	LAMINATE FINISH
	(D)	DINOC FINISH
	(LG)	LAQUERED GLASS
	(GR)	GRAPHIC FINISH
	(TP)	TEXTURE PAINT

Client	BPCL	Project Title	PROPOSED INTERIORS FOR BPCL TERRITORY OFFICE @ VIJAYAWADA	Drawing Title	FINISHES LAYOUT	Dwg No	BPCL_TO_ID-010
GENERAL NOTE: 1. DRAWING TO BE USED ONLY FOR THE PURPOSE RELEASED. 2. DO NOT SCALE THIS DRAWING, ONLY WRITTEN DIMENSIONS TO BE FOLLOWED. 3. ANY DISCREPANCY IN THE DRAWING SHOULD BE IMMEDIATELY BROUGHT TO THE NOTICE OF ARCHITECT.		REV	DESCRIPTION	BY	DATE	Drawn	KARTHIK
						Checked	VYOM
						Approved	VYOM
						Date	23.01.2024
						Issued for	ISSUEDFORTENDER
						Architects New Designer Web Pvt Ltd No.185, 2nd Floor, 1st Main road, Nehru nagar, Kandanchavadi, Perungudi, Chennai - 600096 Tel: +91- 044 - 42125111www.designerweb.in	

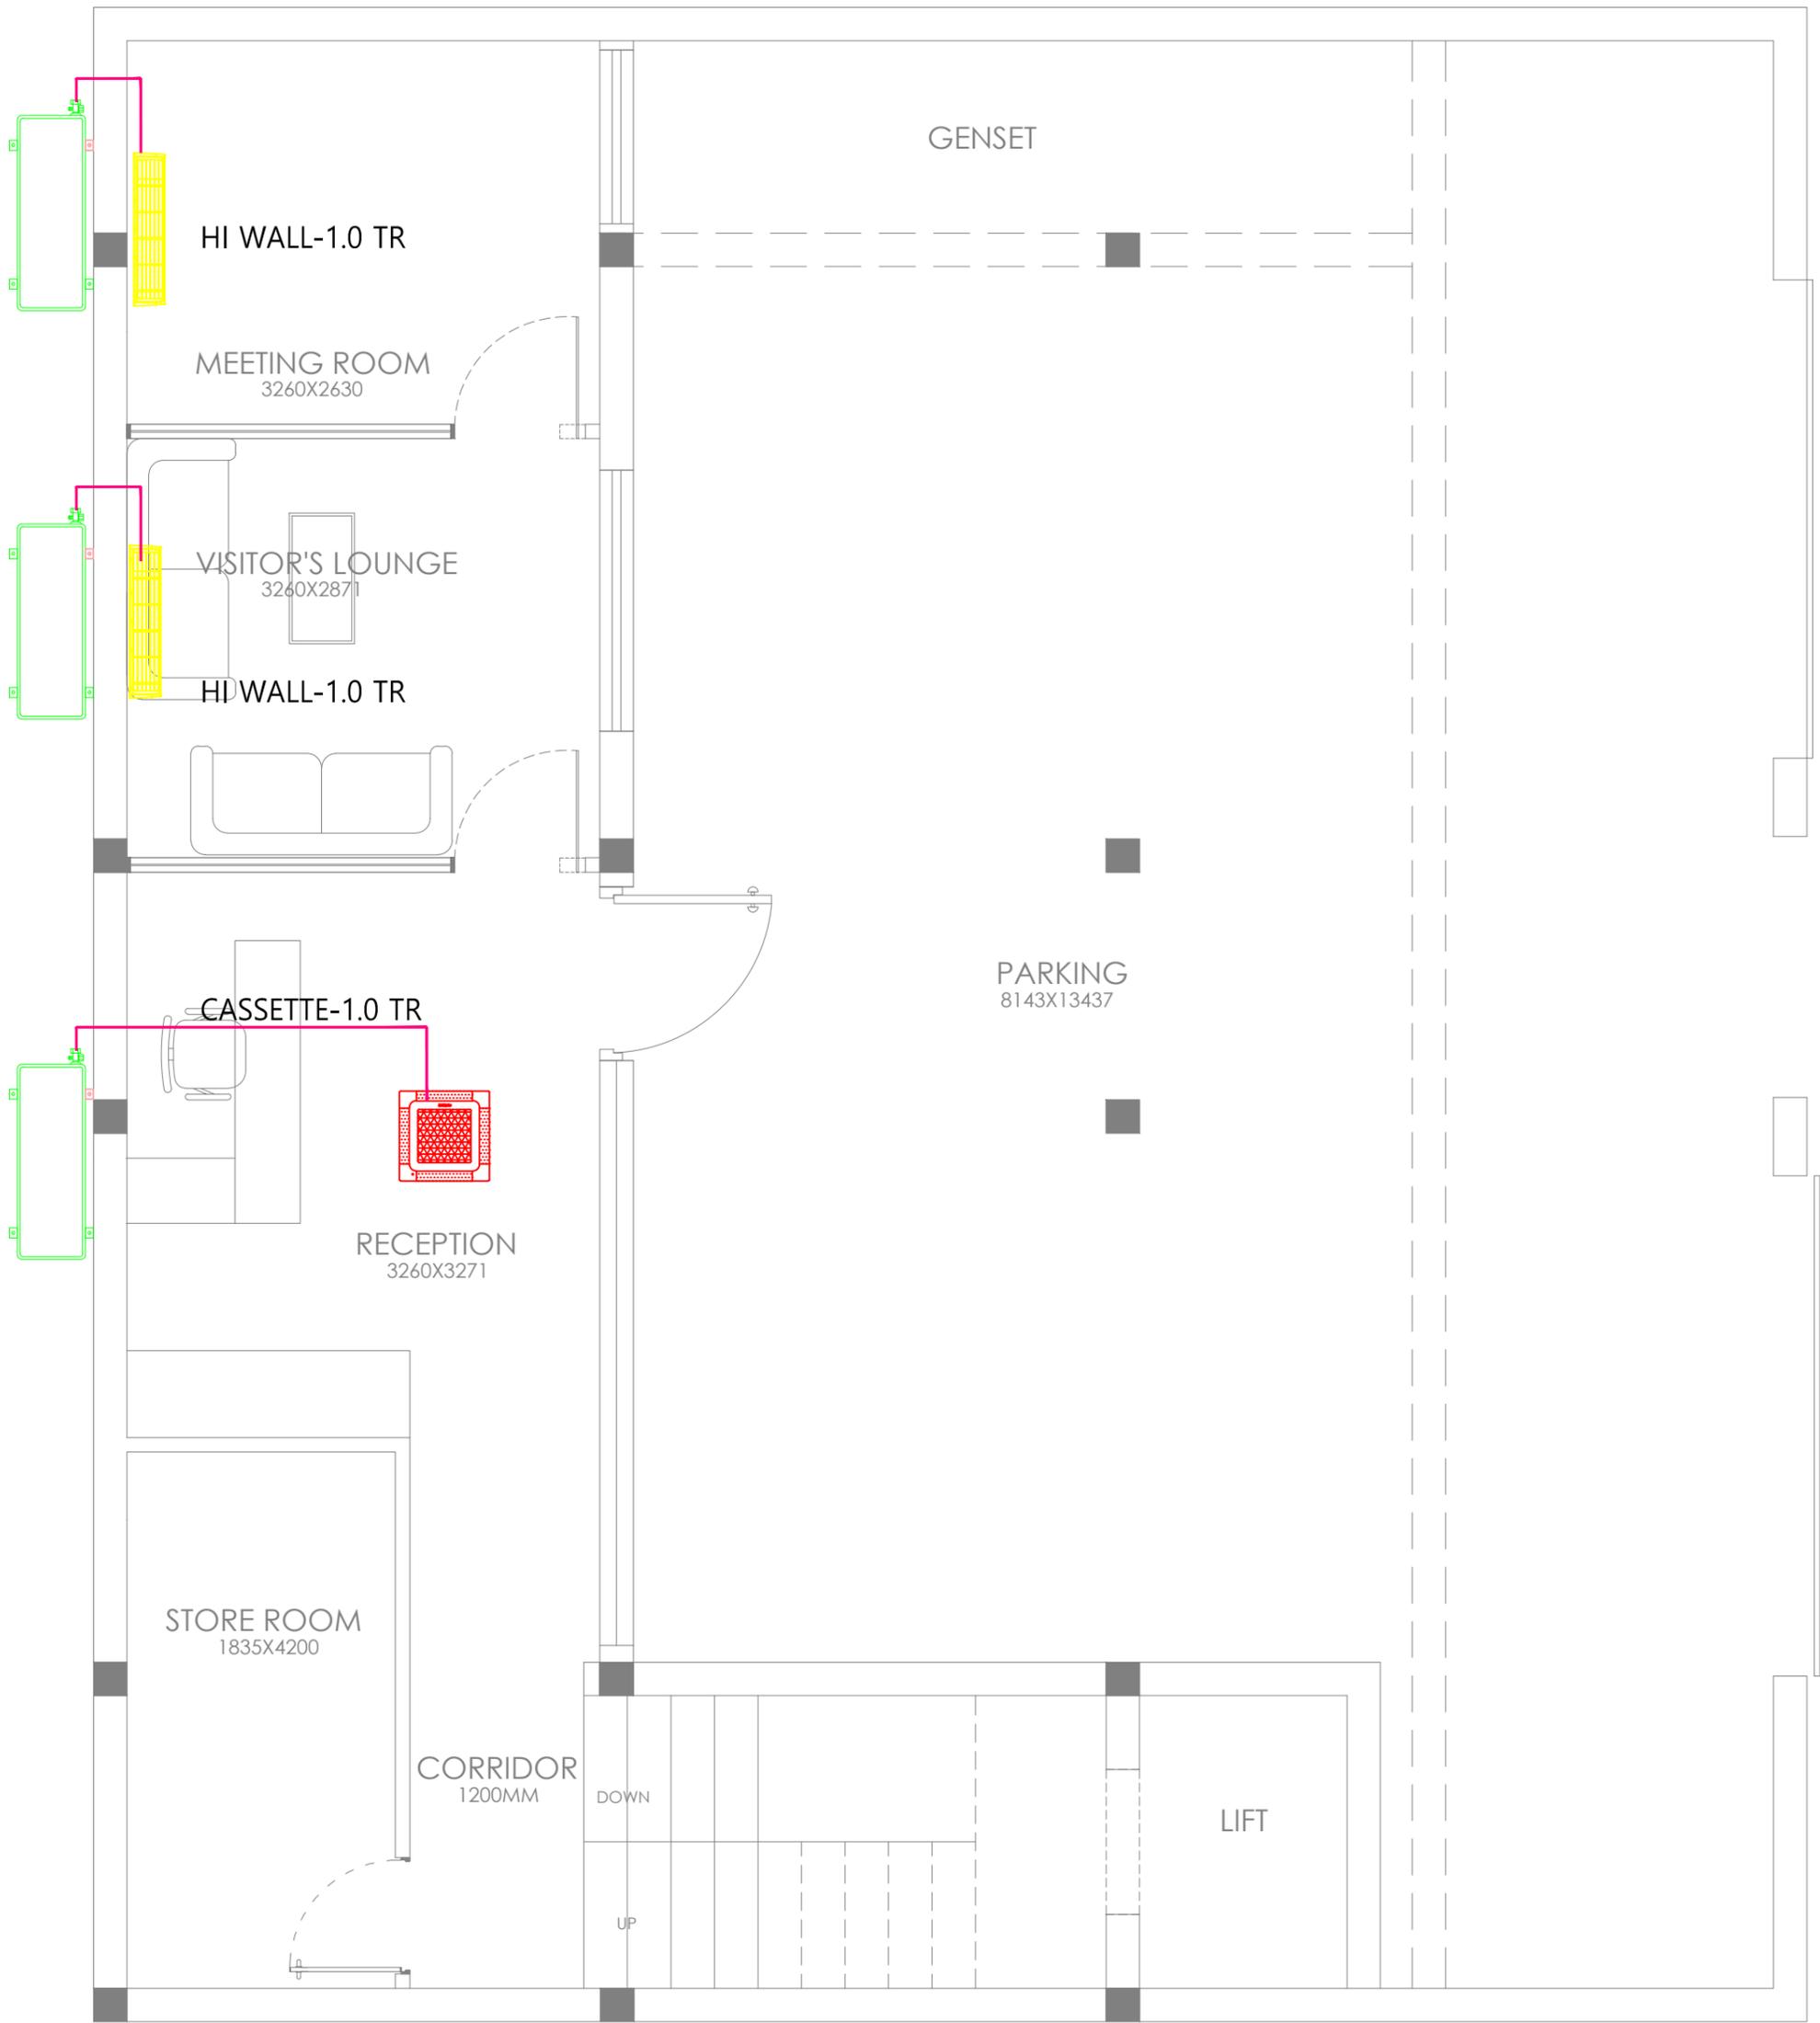


GROUND FLOOR HVAC LAYOUT

LEGEND

	CASSETTE AIR CONDITIONER
	HI WALL DX AIR CONDITIONER
	SPLIT AC ODU
	COPPER PIPE

Client BPCL	Project Title PROPOSED INTERIORS FOR BPCL TERRITORY OFFICE @ VIJAYAWADA	Drawing Title HVAC LAYOUT	Dwg No BPCL_TO_TD-010																	
GENERAL NOTE: 1. DRAWING TO BE USED ONLY FOR THE PURPOSE RELEASED. 2. DO NOT SCALE THIS DRAWING, ONLY WRITTEN DIMENSIONS TO BE FOLLOWED. 3. ANY DISCREPANCY IN THE DRAWING SHOULD BE IMMEDIATELY BROUGHT TO THE NOTICE OF ARCHITECT.		Drawn Checked Approved Date Issued for	Architects New Designer Web Pvt Ltd No.185, 2nd Floor, 1st Main road, Nehru nagar, Kandanchavadi, Perungudi, Chennai - 600096 Tel: +91- 044 - 4212511 www.designerweb.in																	
<table border="1" style="width: 100%; border-collapse: collapse;"> <thead> <tr> <th>REV</th> <th>DESCRIPTION</th> <th>BY</th> <th>DATE</th> </tr> </thead> <tbody> <tr><td> </td><td> </td><td> </td><td> </td></tr> <tr><td> </td><td> </td><td> </td><td> </td></tr> <tr><td> </td><td> </td><td> </td><td> </td></tr> </tbody> </table>		REV	DESCRIPTION	BY	DATE													<table border="1" style="width: 100%; border-collapse: collapse;"> <tr> <td style="text-align: center;"> N W E S </td> <td> Scale SCALE </td> </tr> </table>	 N W E S	Scale SCALE
REV	DESCRIPTION	BY	DATE																	
 N W E S	Scale SCALE																			

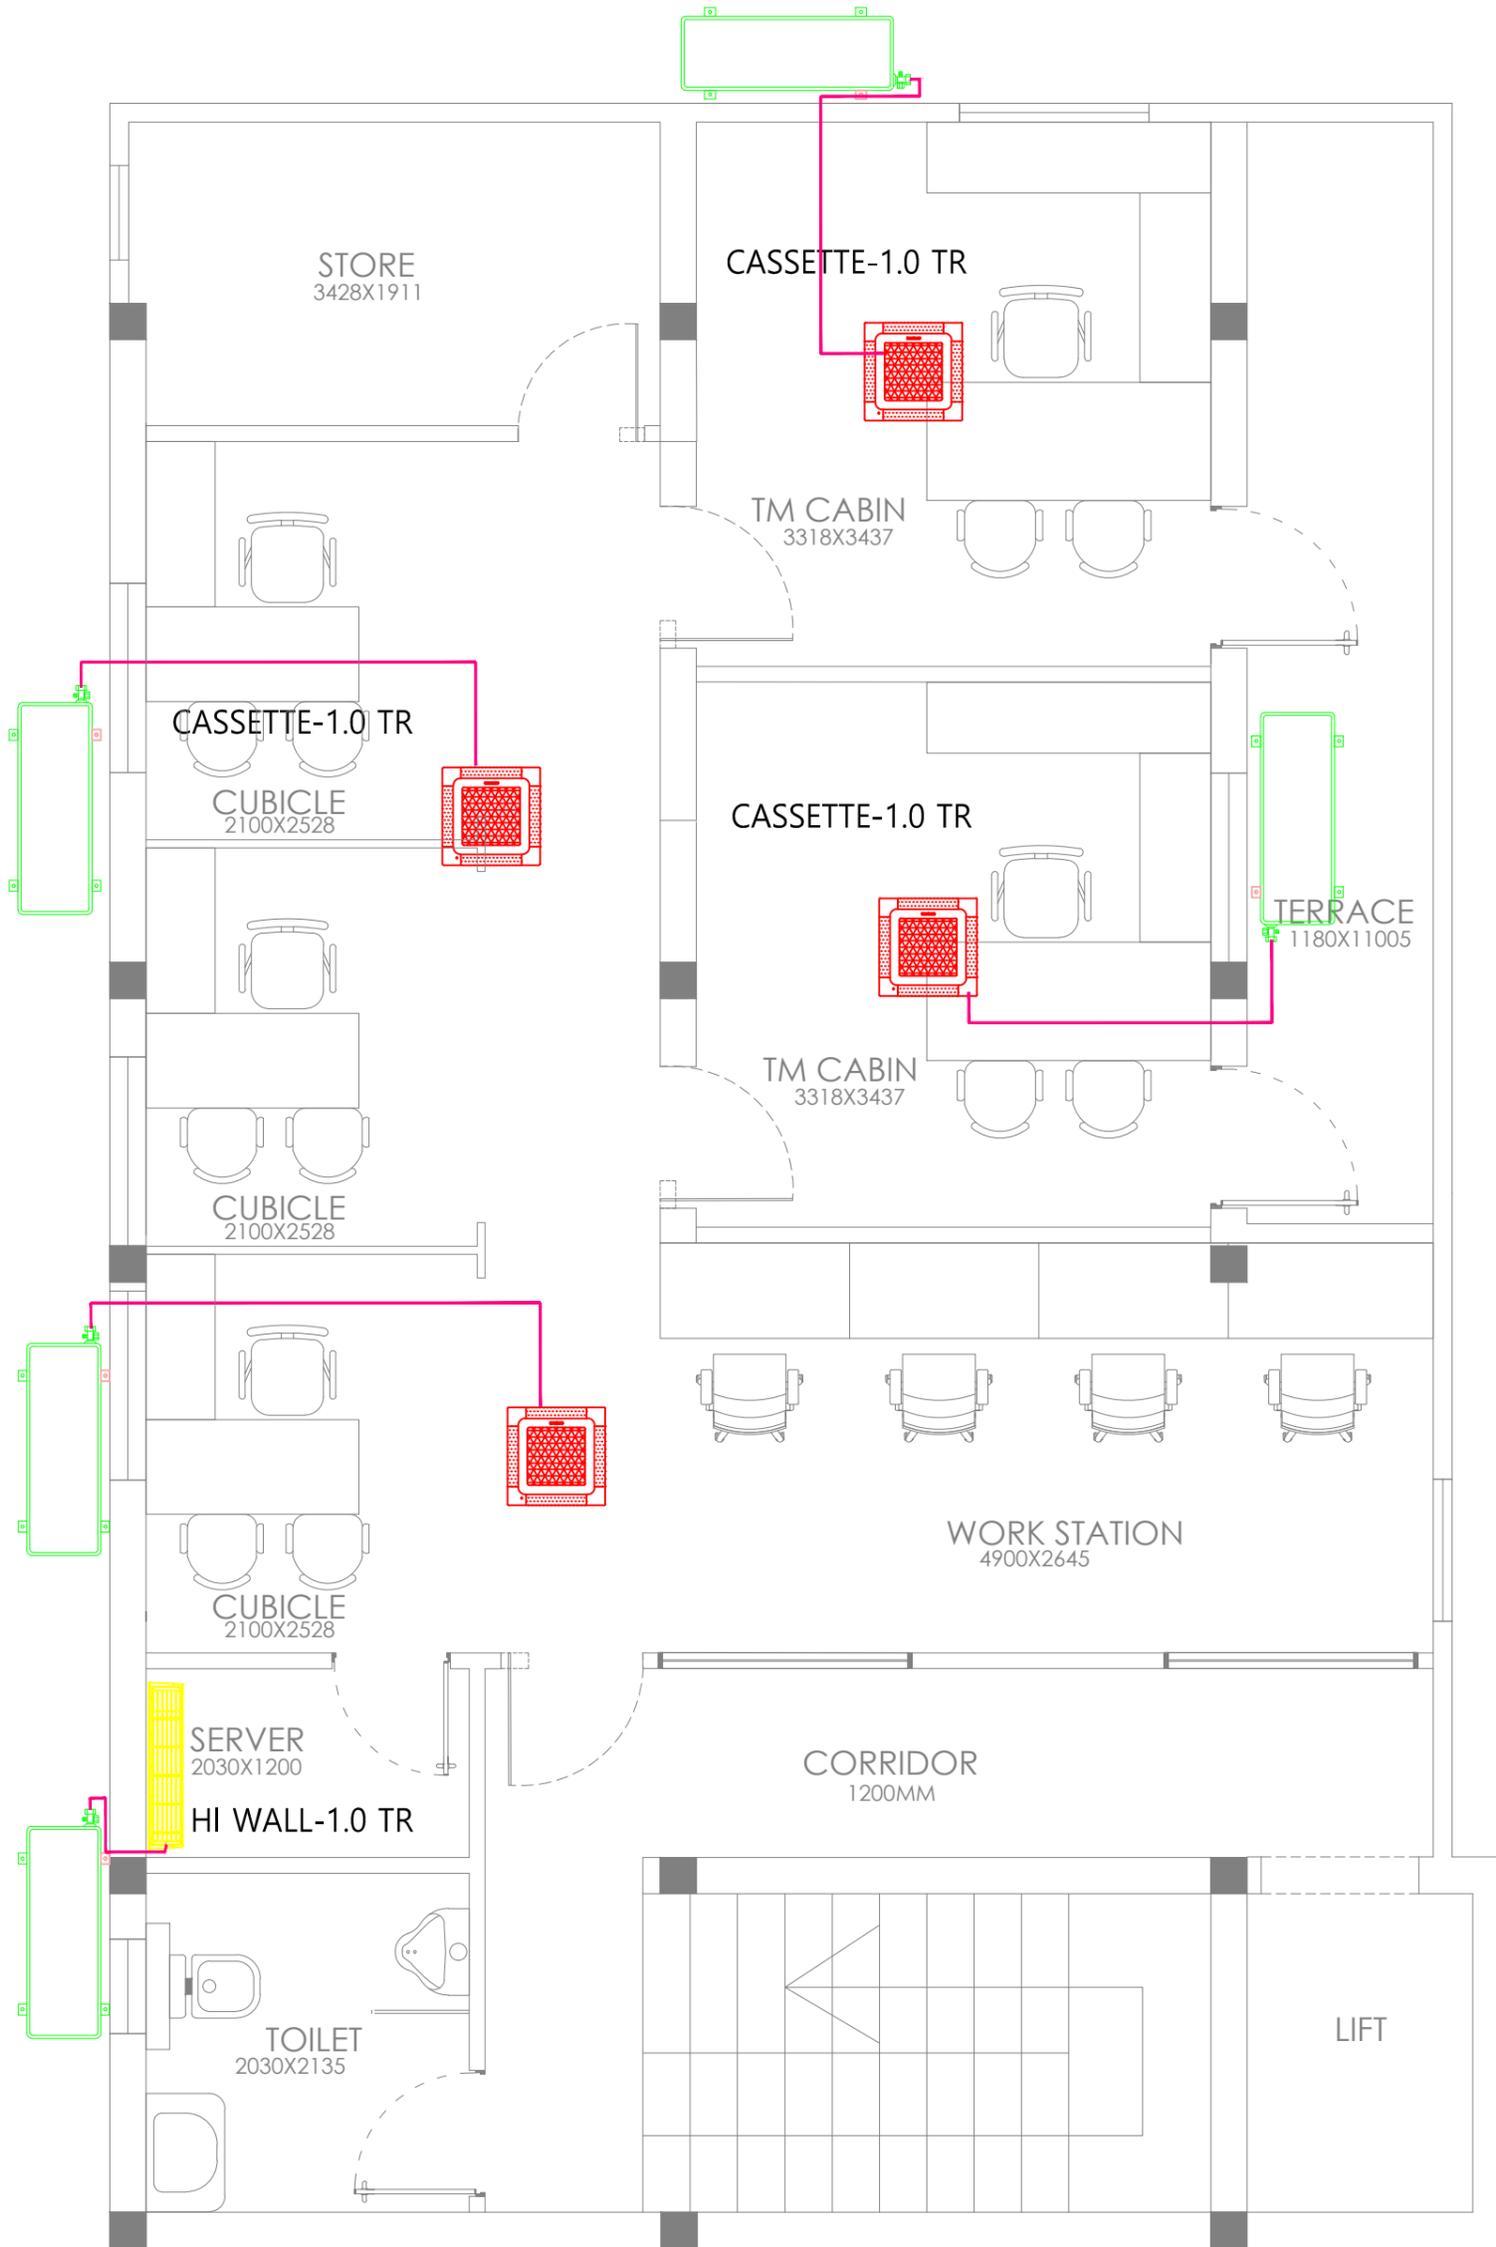


FIRST FLOOR HVAC LAYOUT

LEGEND

	CASSETTE AIR CONDITIONER
	HI WALL DX AIR CONDITIONER
	SPLIT AC ODU
	COPPER PIPE

Client	BPCL	Project Title	PROPOSED INTERIORS FOR BPCL TERRITORY OFFICE @ VIJAYAWADA		Drawing Title	HVAC LAYOUT		Dwg No	BPCL_TO_TD-010
GENERAL NOTE:		REV	DESCRIPTION	BY	DATE	Drawn			Architects  New Designer Web Pvt Ltd No.185, 2nd Floor, 1st Main road, Nehru nagar, Kandanchavadi, Perungudi, Chennai - 600096 Tel: +91- 044 - 4212511 www.designerweb.in
1. DRAWING TO BE USED ONLY FOR THE PURPOSE RELEASED.						Checked			
2. DO NOT SCALE THIS DRAWING, ONLY WRITTEN DIMENSIONS TO BE FOLLOWED.						Approved			
3. ANY DISCREPANCY IN THE DRAWING SHOULD BE IMMEDIATELY BROUGHT TO THE NOTICE OF ARCHITECT.						Date			
						Issued for	Scale		

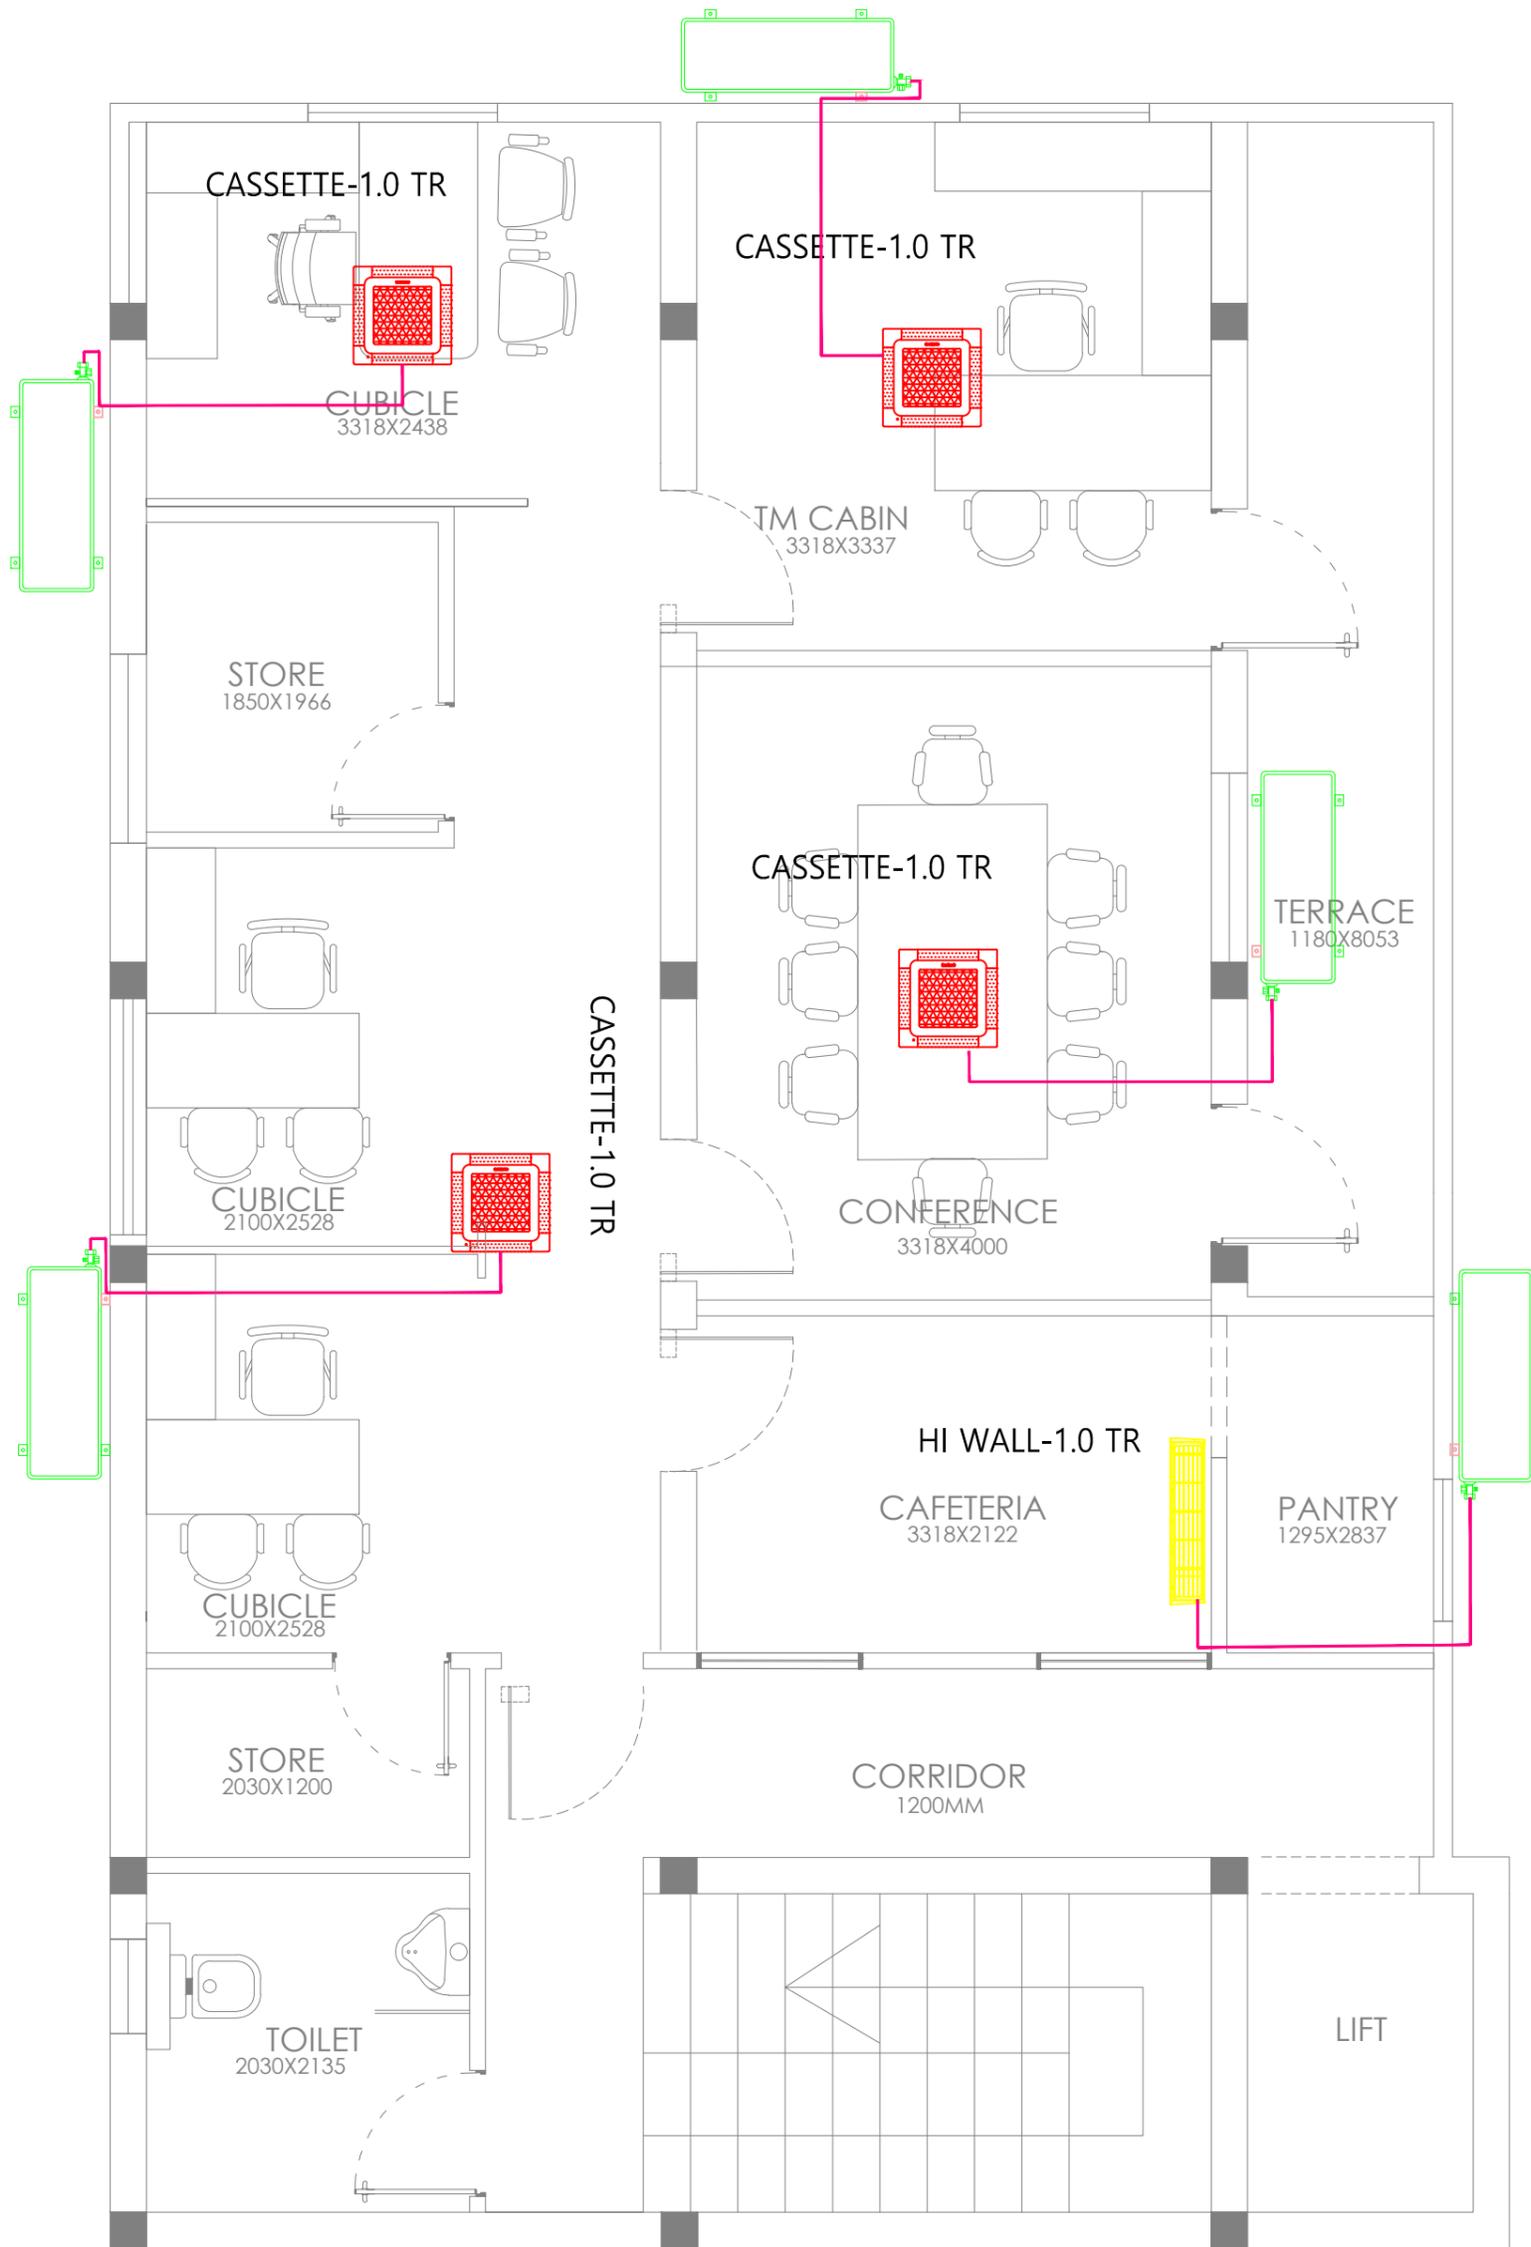


SECOND FLOOR HVAC LAYOUT

LEGEND

	CASSETTE AIR CONDITIONER
	HI WALL DX AIR CONDITIONER
	SPLIT AC ODU
	COPPER PIPE

Client	BPCL	Project Title	PROPOSED INTERIORS FOR BPCL TERRITORY OFFICE @ VIJAYAWADA		Drawing Title	HVAC LAYOUT		Dwg No	BPCL_TO_TD-010
GENERAL NOTE:		REV	DESCRIPTION	BY	DATE	Drawn			Architects  New Designer Web Pvt Ltd No.185, 2nd Floor, 1st Main road, Nehru nagar, Kandanchavadi, Perungudi, Chennai - 600096 Tel: +91- 044 - 4212511 www.designerweb.in
1. DRAWING TO BE USED ONLY FOR THE PURPOSE RELEASED.						Checked			
2. DO NOT SCALE THIS DRAWING, ONLY WRITTEN DIMENSIONS TO BE FOLLOWED.						Approved			
3. ANY DISCREPANCY IN THE DRAWING SHOULD BE IMMEDIATELY BROUGHT TO THE NOTICE OF ARCHITECT.						Date			
						Issued for	Scale		

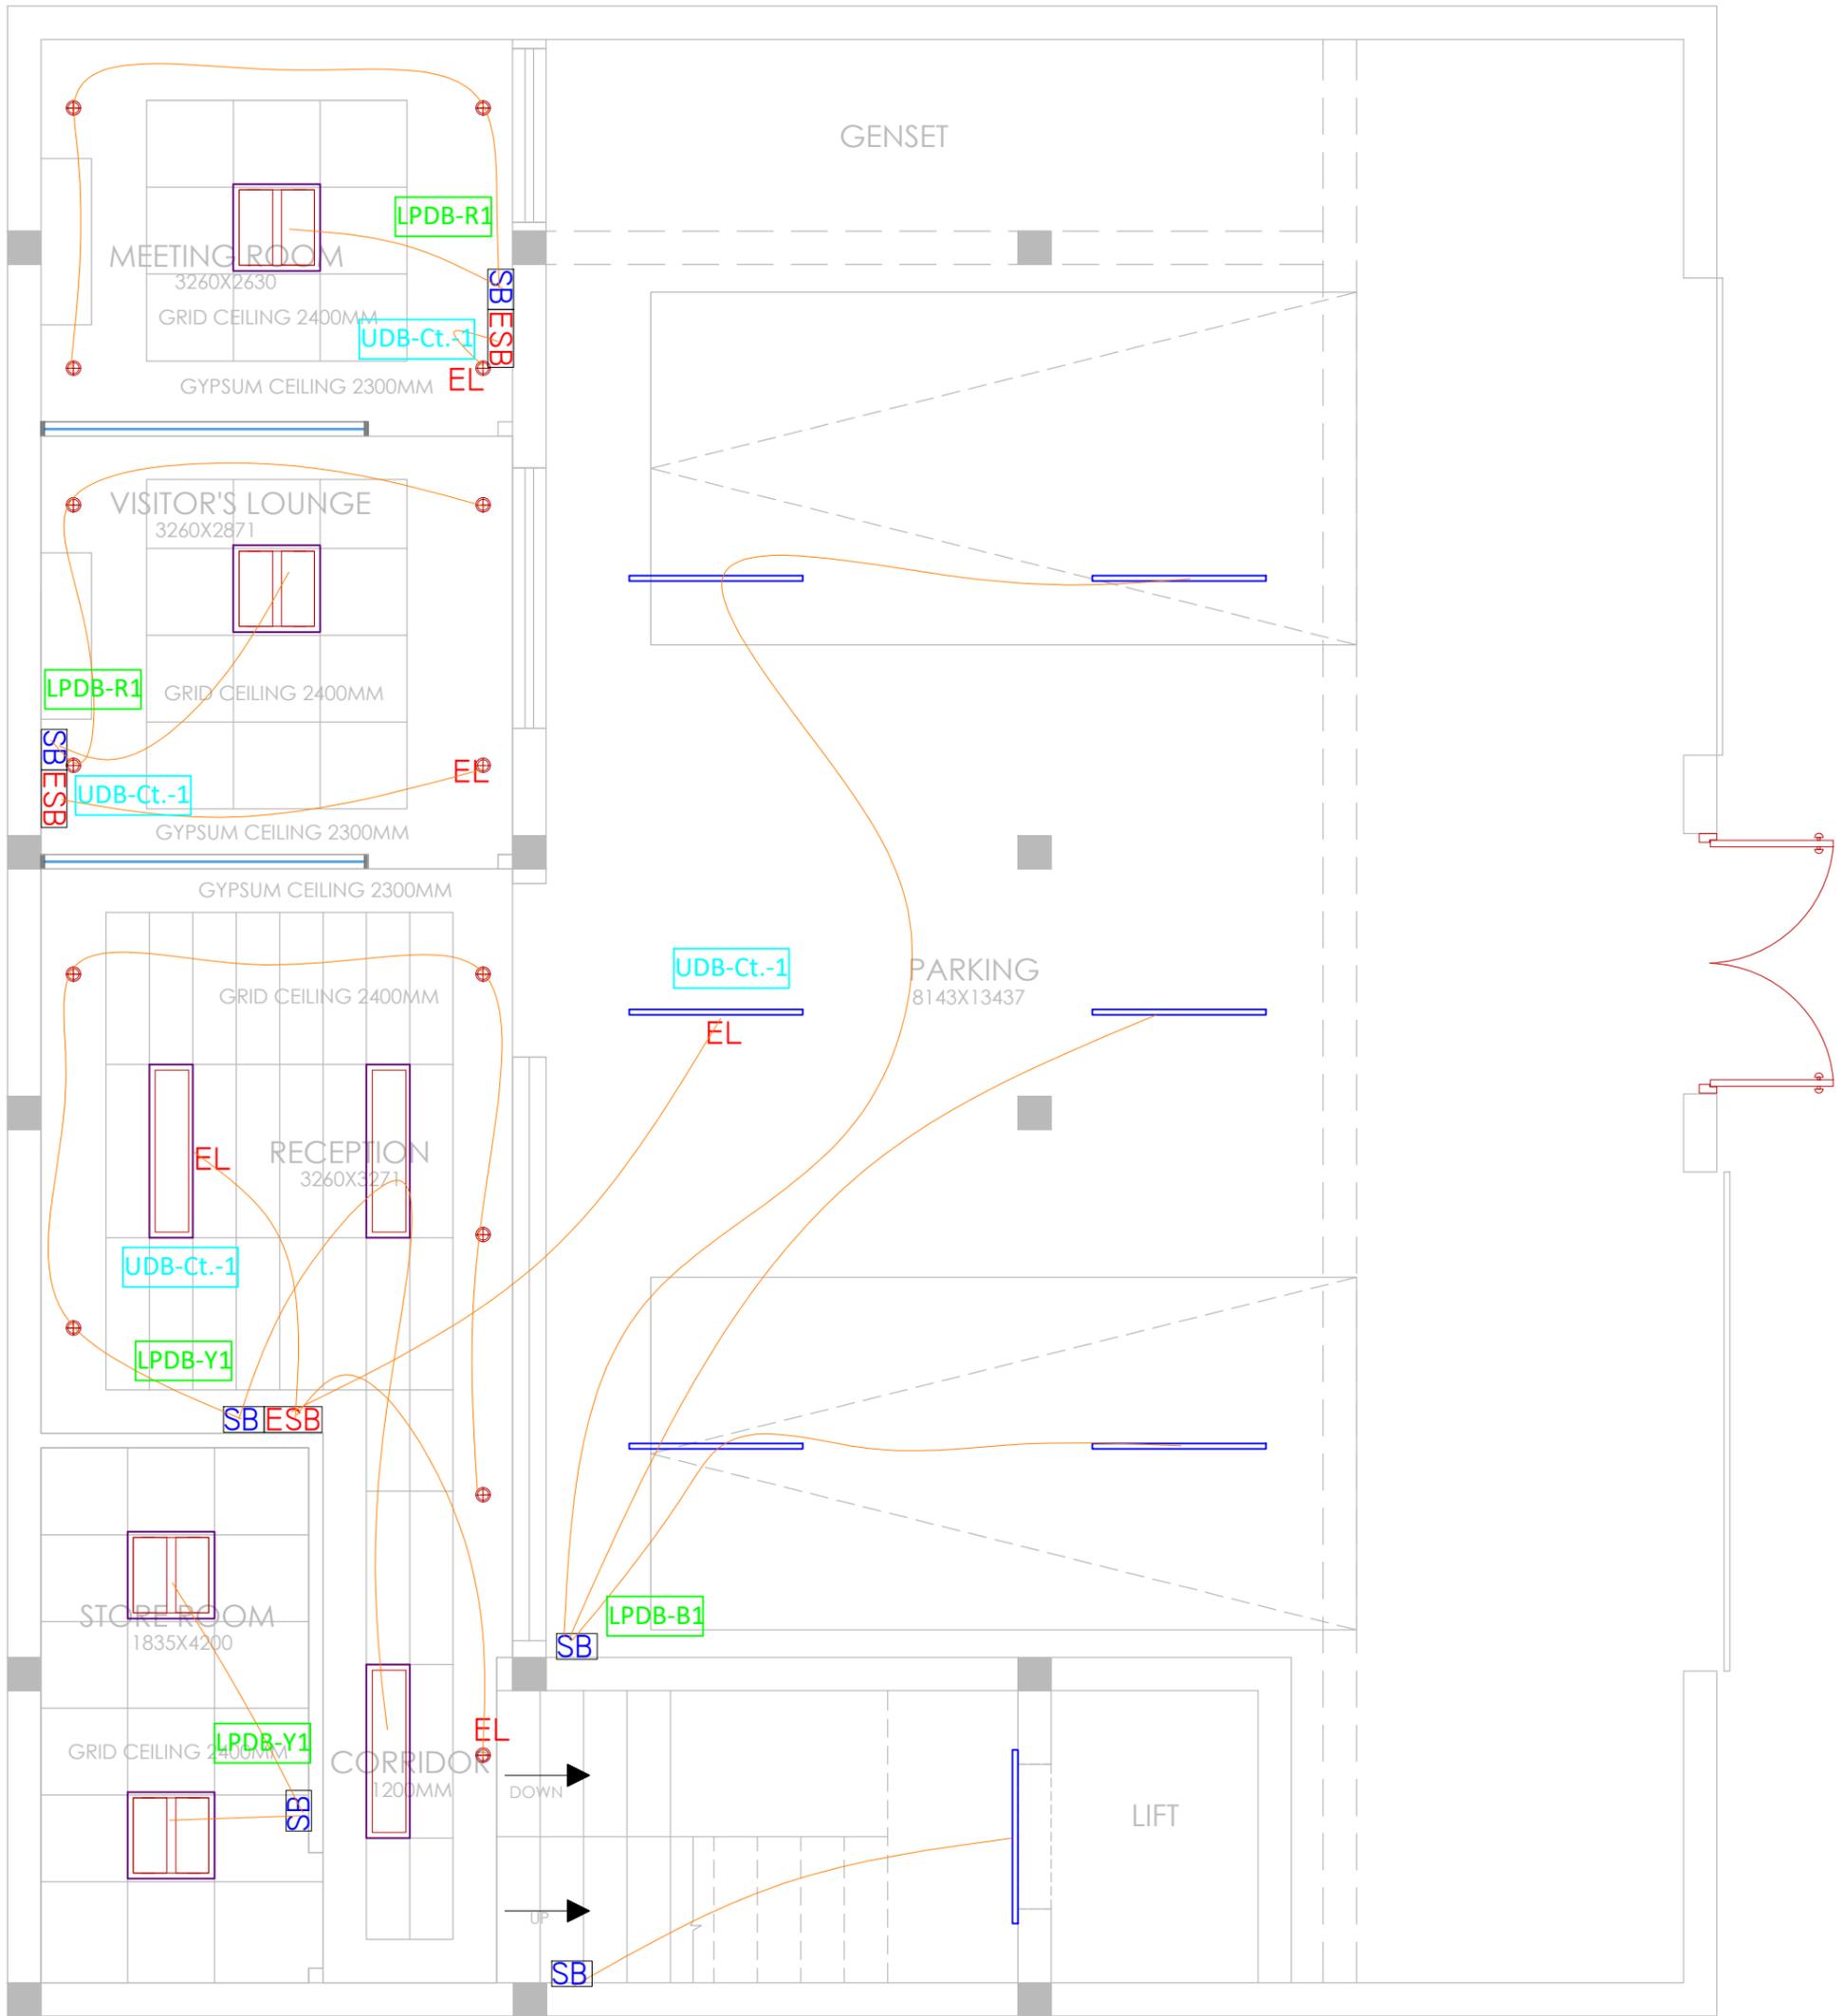


GROUND FLOOR

	LED 2X2 LIGHT FITTING
	LED DOWN LIGHT FITTING
	LED 4X2 LIGHT FITTING
	LIGHTING SWITCH BOX
	EMERGENCY LIGHTING SWITCH BOX
	EMERGENCY LIGHT FITTING
	LED 4EET PATTI LIGHT FITTING
	EXHAUST FAN


Client	BPCL	Project Title	PROPOSED INTERIORS FOR BPCL TERRITORY OFFICE @ VIJAYAWADA		Drawing Title	ELECTRICAL LOOPING LAYOUT	Dwg No	BPCL_TO_TD-011
GENERAL NOTE:		REV	DESCRIPTION	BY	DATE	Drawn		Architects New Designer Web Pvt Ltd No.185, 2nd Floor, 1st Main road, Nehru nagar, Kandanchavadi, Perungudi, Chennai - 600096 Tel: +91- 044 - 42125111www.designerweb.in
1. DRAWING TO BE USED ONLY FOR THE PURPOSE RELEASED.						Checked		
2. DO NOT SCALE THIS DRAWING, ONLY WRITTEN DIMENSIONS TO BE FOLLOWED.						Approved		
3. ANY DISCREPANCY IN THE DRAWING SHOULD BE IMMEDIATELY BROUGHT TO THE NOTICE OF ARCHITECT.						Date		
						Issued for		

	LED 2X2 LIGHT FITTING
	LED DOWN LIGHT FITTING
	LED 4X2 LIGHT FITTING
	LIGHTING SWITCH BOX
	EMERGENCY LIGHTING SWITCH BOX
	EMERGENCY LIGHT FITTING
	LED 4EET PATTI LIGHT FITTING
	EXHAUST FAN

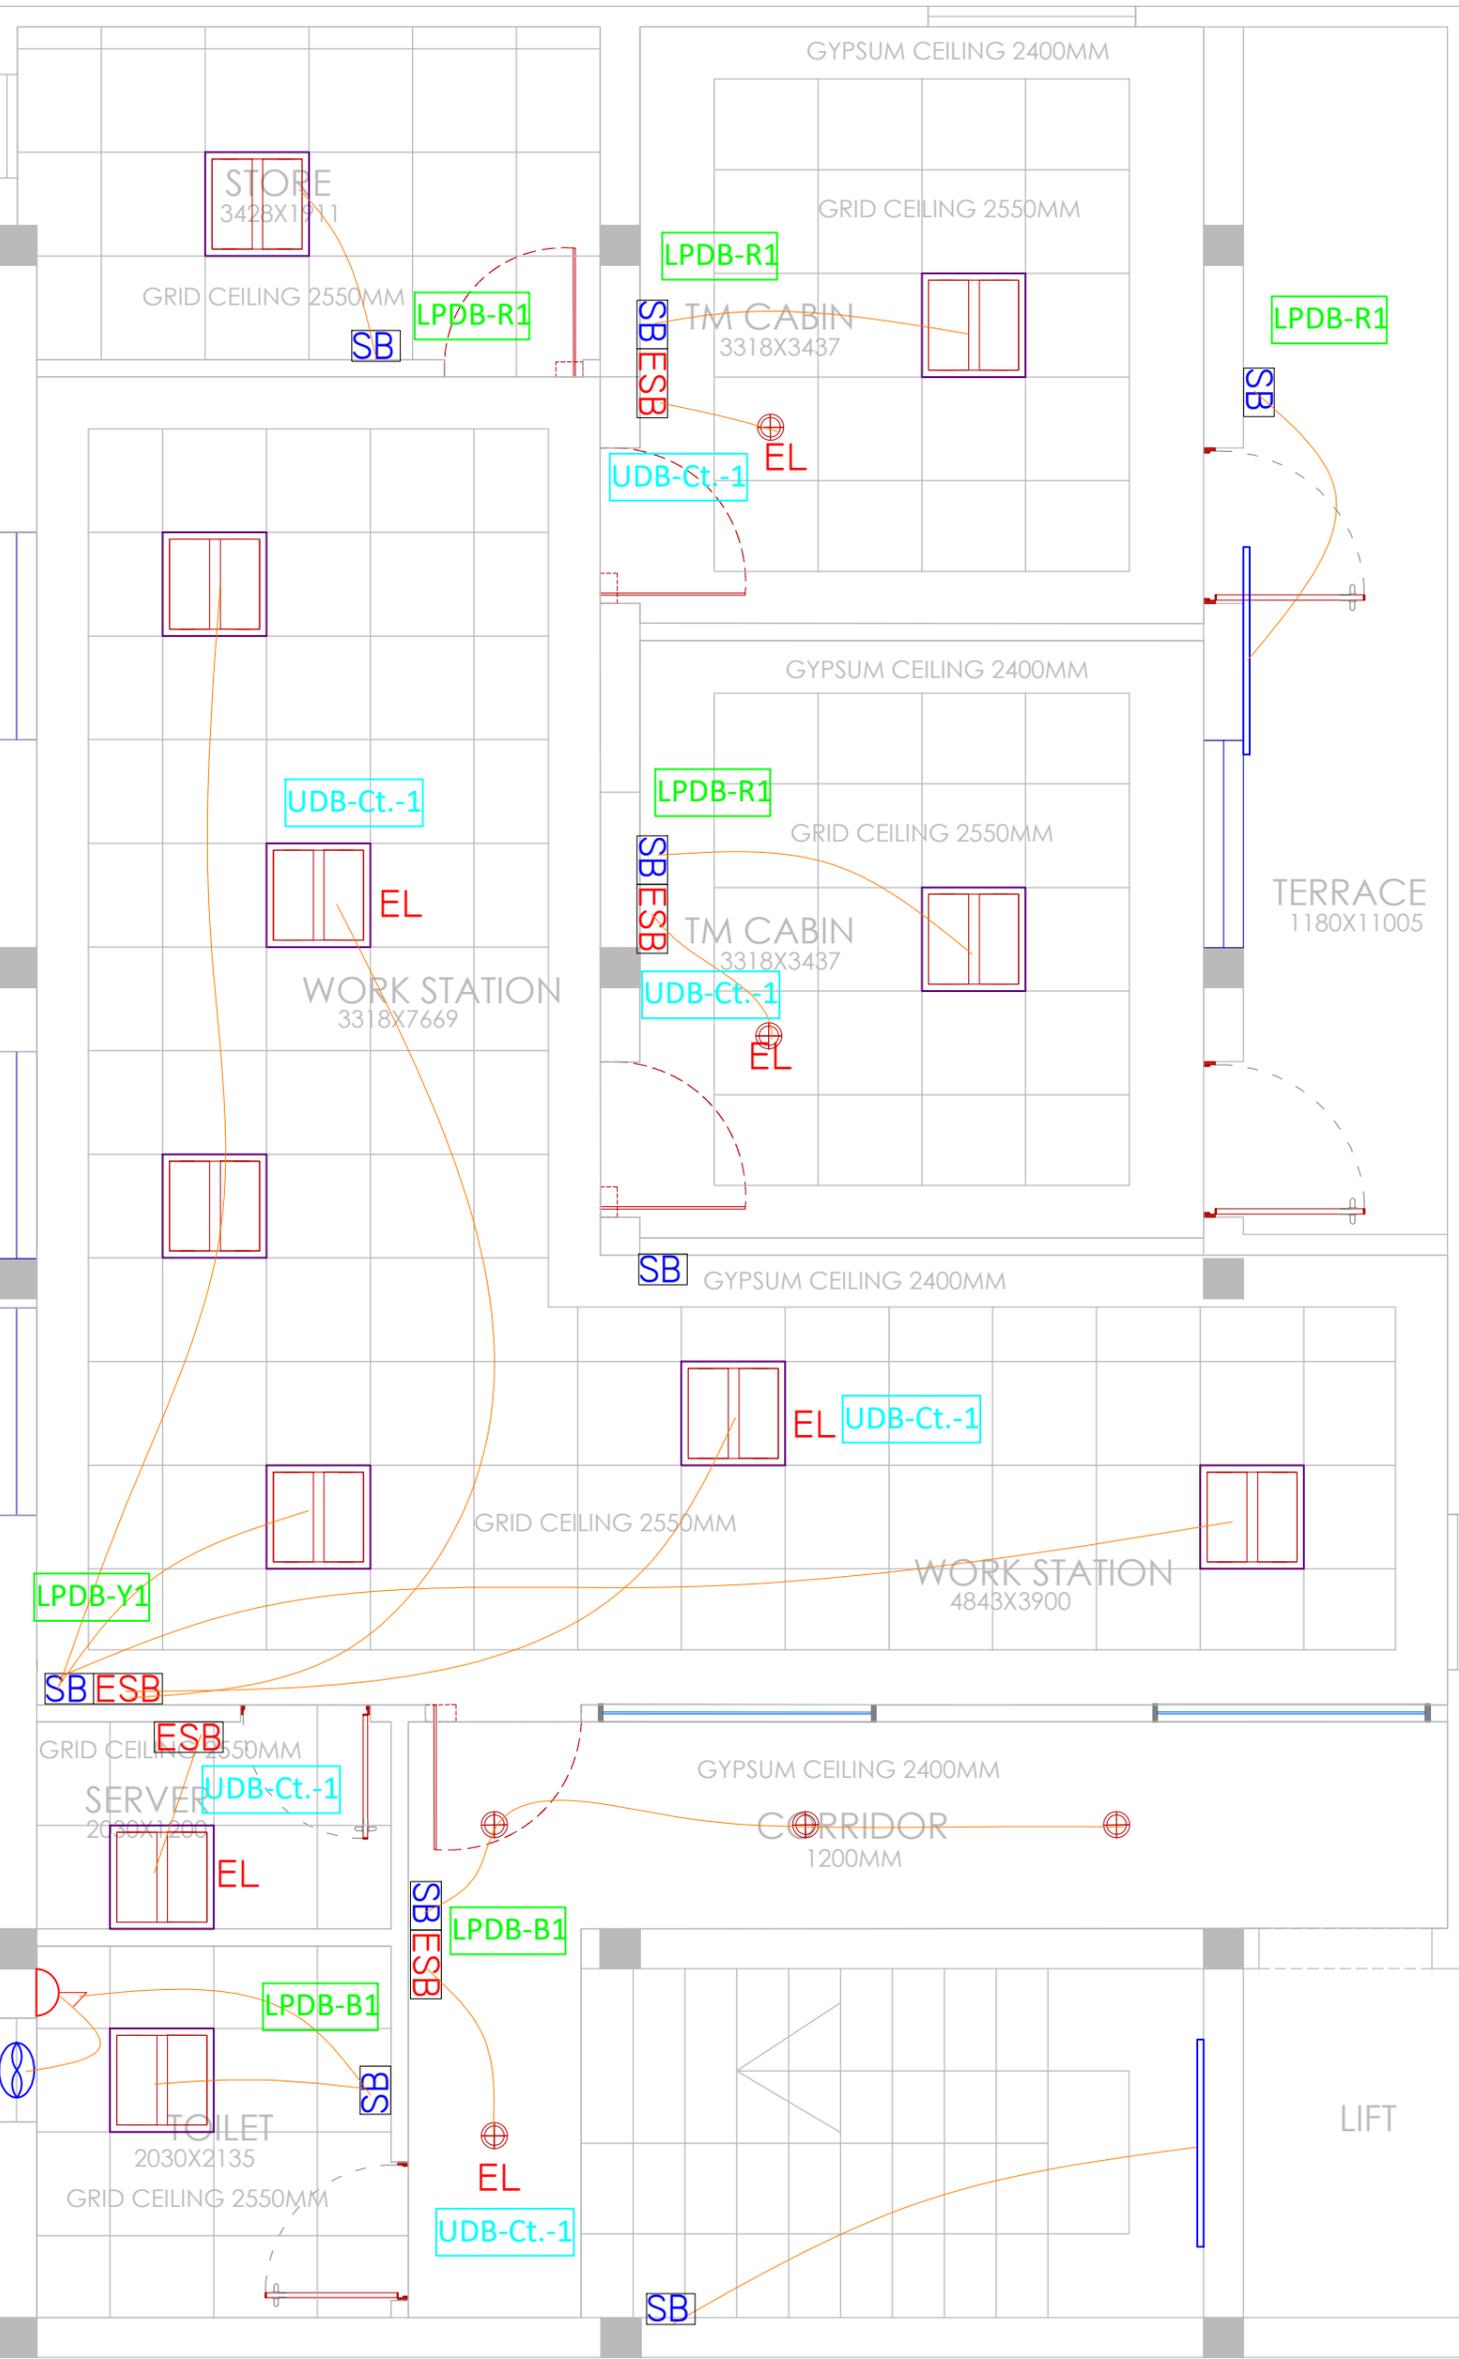

FIRST FLOOR


Client	BPCL	Project Title	PROPOSED INTERIORS FOR BPCL TERRITORY OFFICE @ VIJAYAWADA	Drawing Title	ELECTRICAL LOOPING LAYOUT	Dwg No	BPCL_TO_TD-011
GENERAL NOTE:		REV	DESCRIPTION	BY	DATE	Architects	
1. DRAWING TO BE USED ONLY FOR THE PURPOSE RELEASED.						New Designer Web Pvt Ltd No.185, 2nd Floor, 1st Main road, Nehru nagar, Kandanchavadi, Perungudi, Chennai - 600096 Tel: +91- 044 - 4212511 www.designerweb.in	
2. DO NOT SCALE THIS DRAWING, ONLY WRITTEN DIMENSIONS TO BE FOLLOWED.							
3. ANY DISCREPANCY IN THE DRAWING SHOULD BE IMMEDIATELY BROUGHT TO THE NOTICE OF ARCHITECT.							
				Drawn			SCALE
				Checked			
				Approved			
				Date			
				Issued for			

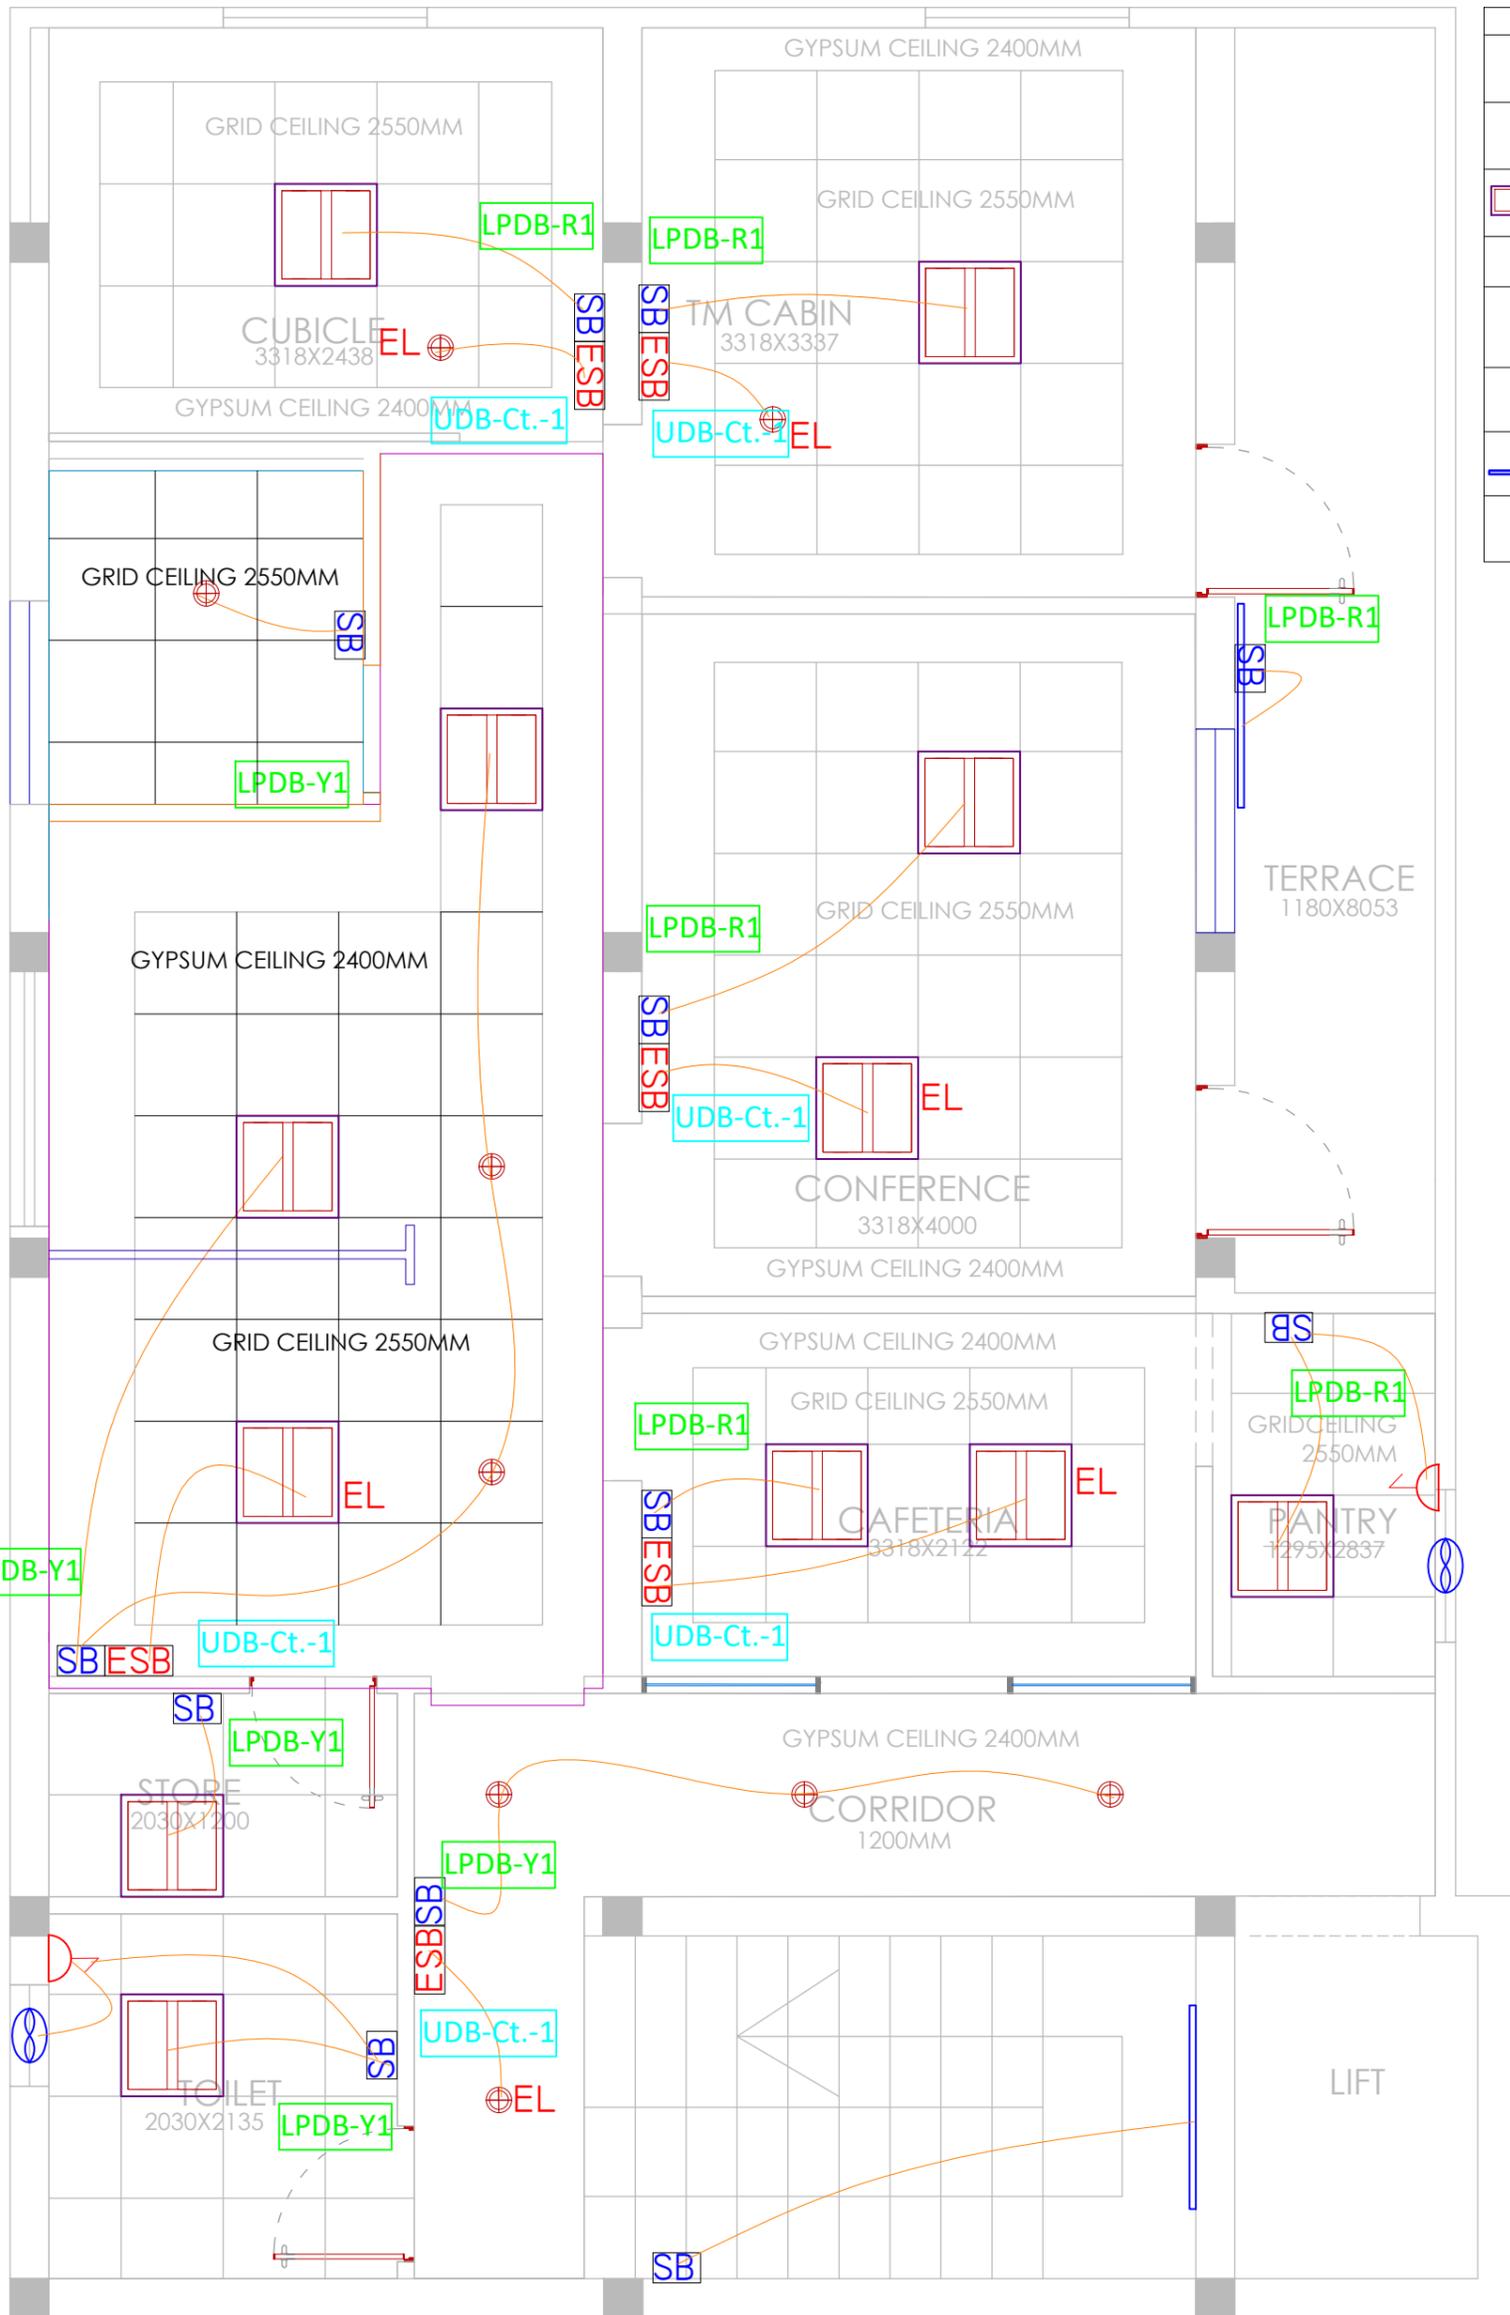

	LED 2X2 LIGHT FITTING
	LED DOWN LIGHT FITTING
	LED 4X2 LIGHT FITTING
	LIGHTING SWITCH BOX
	EMERGENCY LIGHTING SWITCH BOX
	EMERGENCY LIGHT FITTING
	LED 4EET PATTI LIGHT FITTING
	EXHAUST FAN

SECOND FLOOR

Client	BPCL	Project Title	PROPOSED INTERIORS FOR BPCL TERRITORY OFFICE @ VIJAYAWADA	Drawing Title	ELECTRICAL LOOPING LAYOUT	Dwg No	BPCL_TO_TD-011
GENERAL NOTE:		REV	DESCRIPTION	BY	DATE	Architects	
1. DRAWING TO BE USED ONLY FOR THE PURPOSE RELEASED.						 New Designer Web Pvt Ltd No.185, 2nd Floor, 1st Main road, Nehru nagar, Kandanchavadi, Perungudi, Chennai - 600096 Tel: +91- 044 - 4212511 www.designerweb.in	
2. DO NOT SCALE THIS DRAWING, ONLY WRITTEN DIMENSIONS TO BE FOLLOWED.							
3. ANY DISCREPANCY IN THE DRAWING SHOULD BE IMMEDIATELY BROUGHT TO THE NOTICE OF ARCHITECT.							
				Drawn		Scale	SCALE
				Checked			
				Approved			
				Date			
				Issued for			

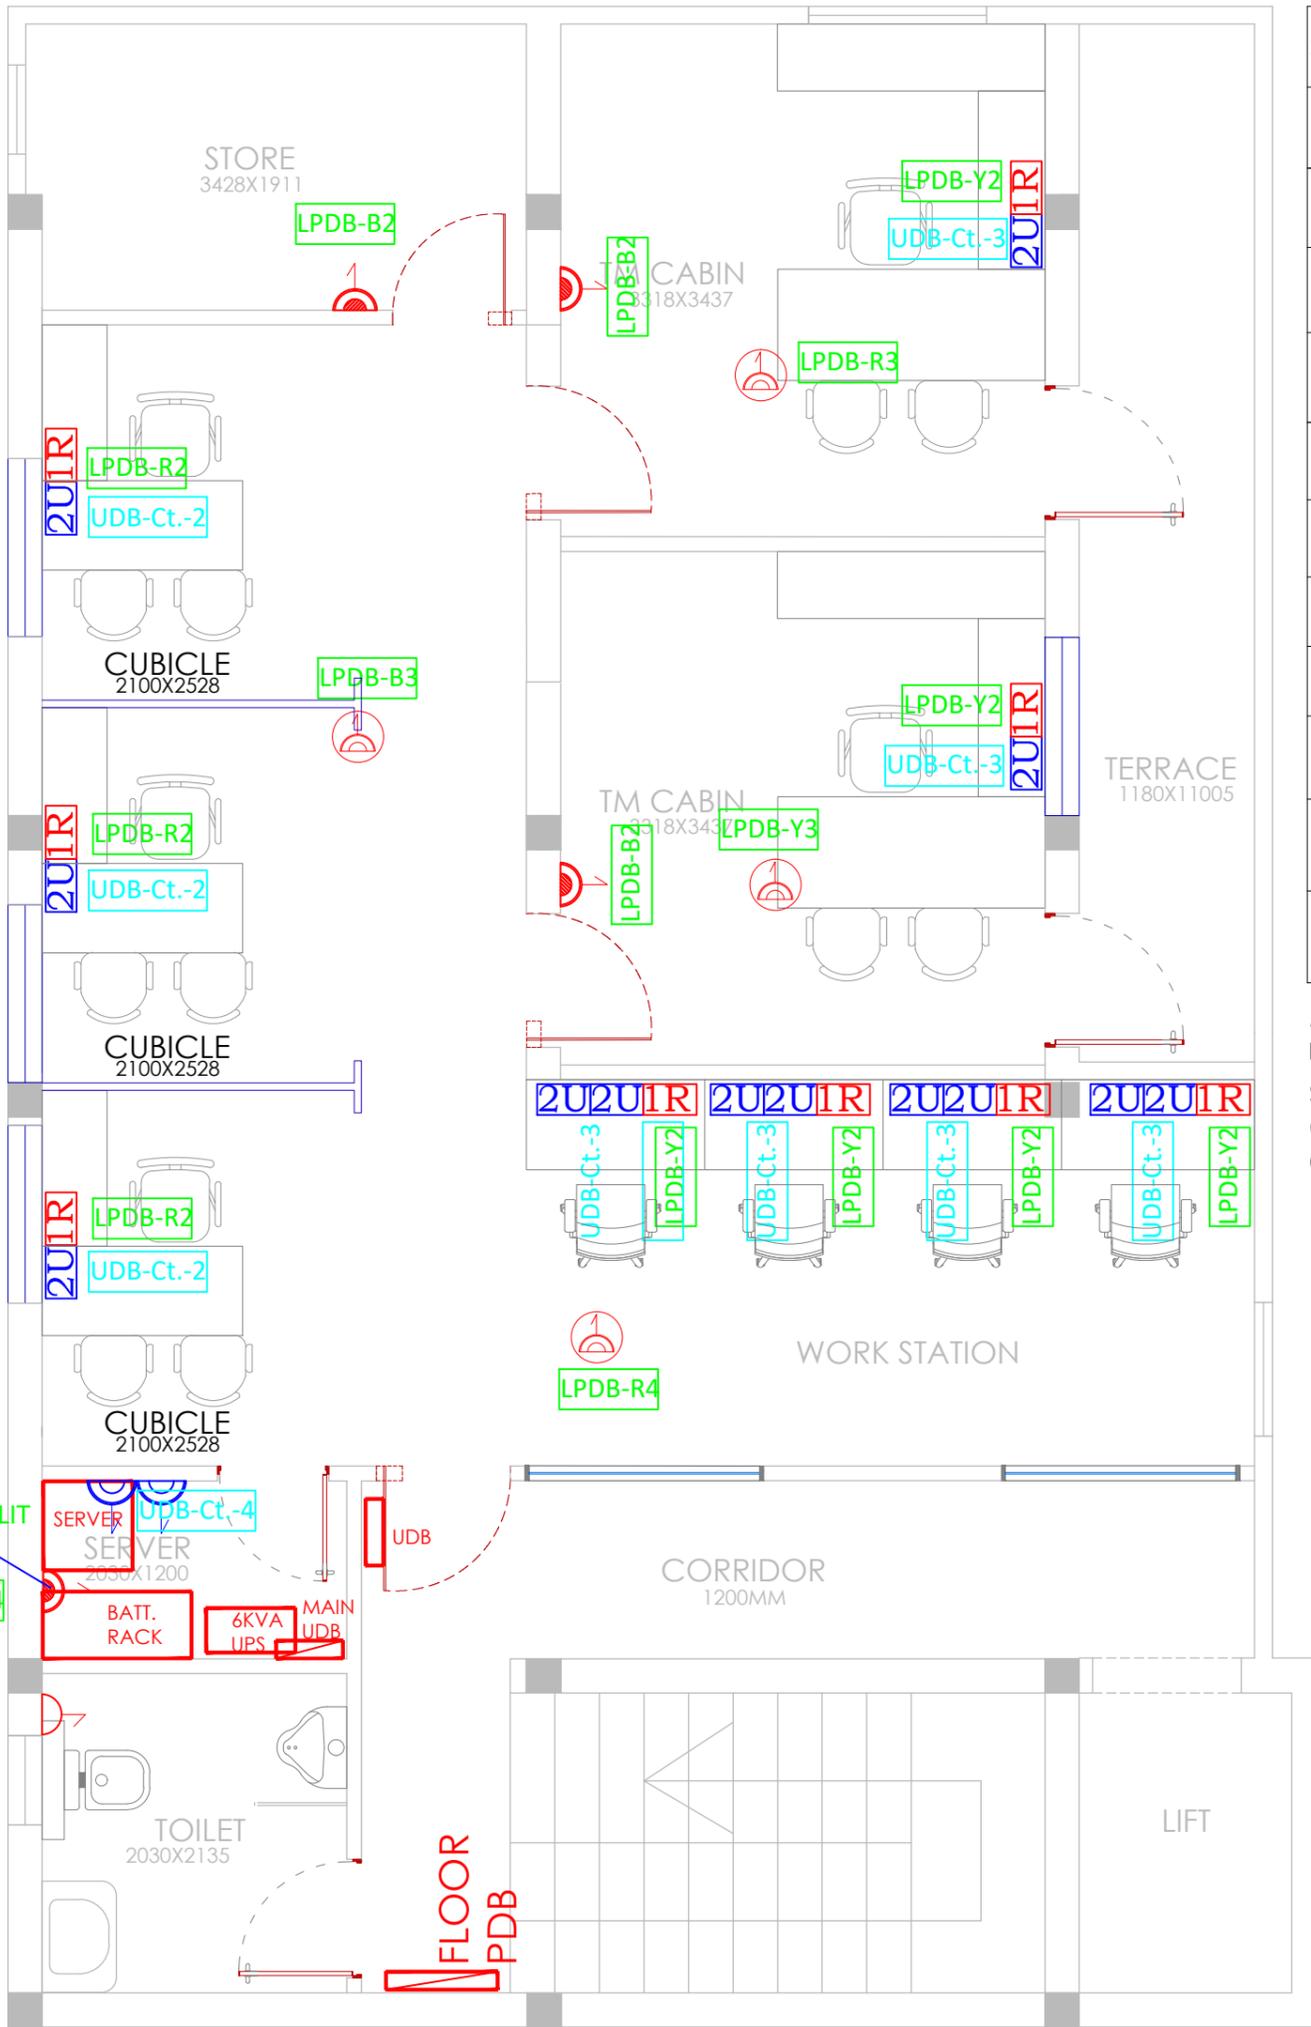

FIRST FLOOR


SYMBOL	DESCRIPTION
	2X13A INTERNATIONAL SOCKET WITH INO 16A SWITCH FOR UPS POWER
	IX5A SOCKET WITH INO 16A SWITCH FOR UPS POWER
	IX6/16A SOCKET WITH INO 16A SWITCH FOR UPS POWER
	3X13A INTERNATIONAL SOCKET WITH INO 16A SWITCH FOR UPS POWER
	2X13A INTERNATIONAL SOCKET WITH 2NOS 16A SWITCH FOR RAW POWER
	IX13A INTERNATIONAL SOCKET WITH INO 16A SWITCH FOR RAW POWER
	IX6/16A SOCKET WITH INO 16A SWITCH FOR RAW POWER
	5A SOCKET WITH INO 5A SWITCH FOR RAW POWER
	IX6/16A SOCKET WITH INO 16A SWITCH FOR RAW POWER AT CEILING
	20A METAL CALD SOCKET WITH 20A DP MCB FOR SPLIT A/C

ALL UTILITY/CLEANING RAW POWER SOCKETS SHOULD BE 300MM HT FROM FFL

SOCKETS FOR OTHER SERVICES LIKE A/C, FAS, PAS, CCTV ETC., TO BE PROVIDE AS PER THE LOCATION CONFIRMED BY THE VENDOR AT SITE CONDITION.

FOR SPLIT A/C
LPDB-Y4

Client	BPCL	Project Title	PROPOSED INTERIORS FOR BPCL TERRITORY OFFICE @ VIJAYAWADA		Drawing Title	ELECTRICAL SOCKET LAYOUT		Dwg No	BPCL_TO_TD-012
GENERAL NOTE:		REV	DESCRIPTION	BY	DATE	Drawn		Architects New Designer Web Pvt Ltd No.185, 2nd Floor, 1st Main road, Nehru nagar, Kandanchavadi, Perungudi, Chennai - 600096 Tel: +91- 044 - 42125111www.designerweb.in	
1. DRAWING TO BE USED ONLY FOR THE PURPOSE RELEASED.						Checked			
2. DO NOT SCALE THIS DRAWING, ONLY WRITTEN DIMENSIONS TO BE FOLLOWED.						Approved			
3. ANY DISCREPANCY IN THE DRAWING SHOULD BE IMMEDIATELY BROUGHT TO THE NOTICE OF ARCHITECT.						Date			
						Issued for	Scale		SCALE

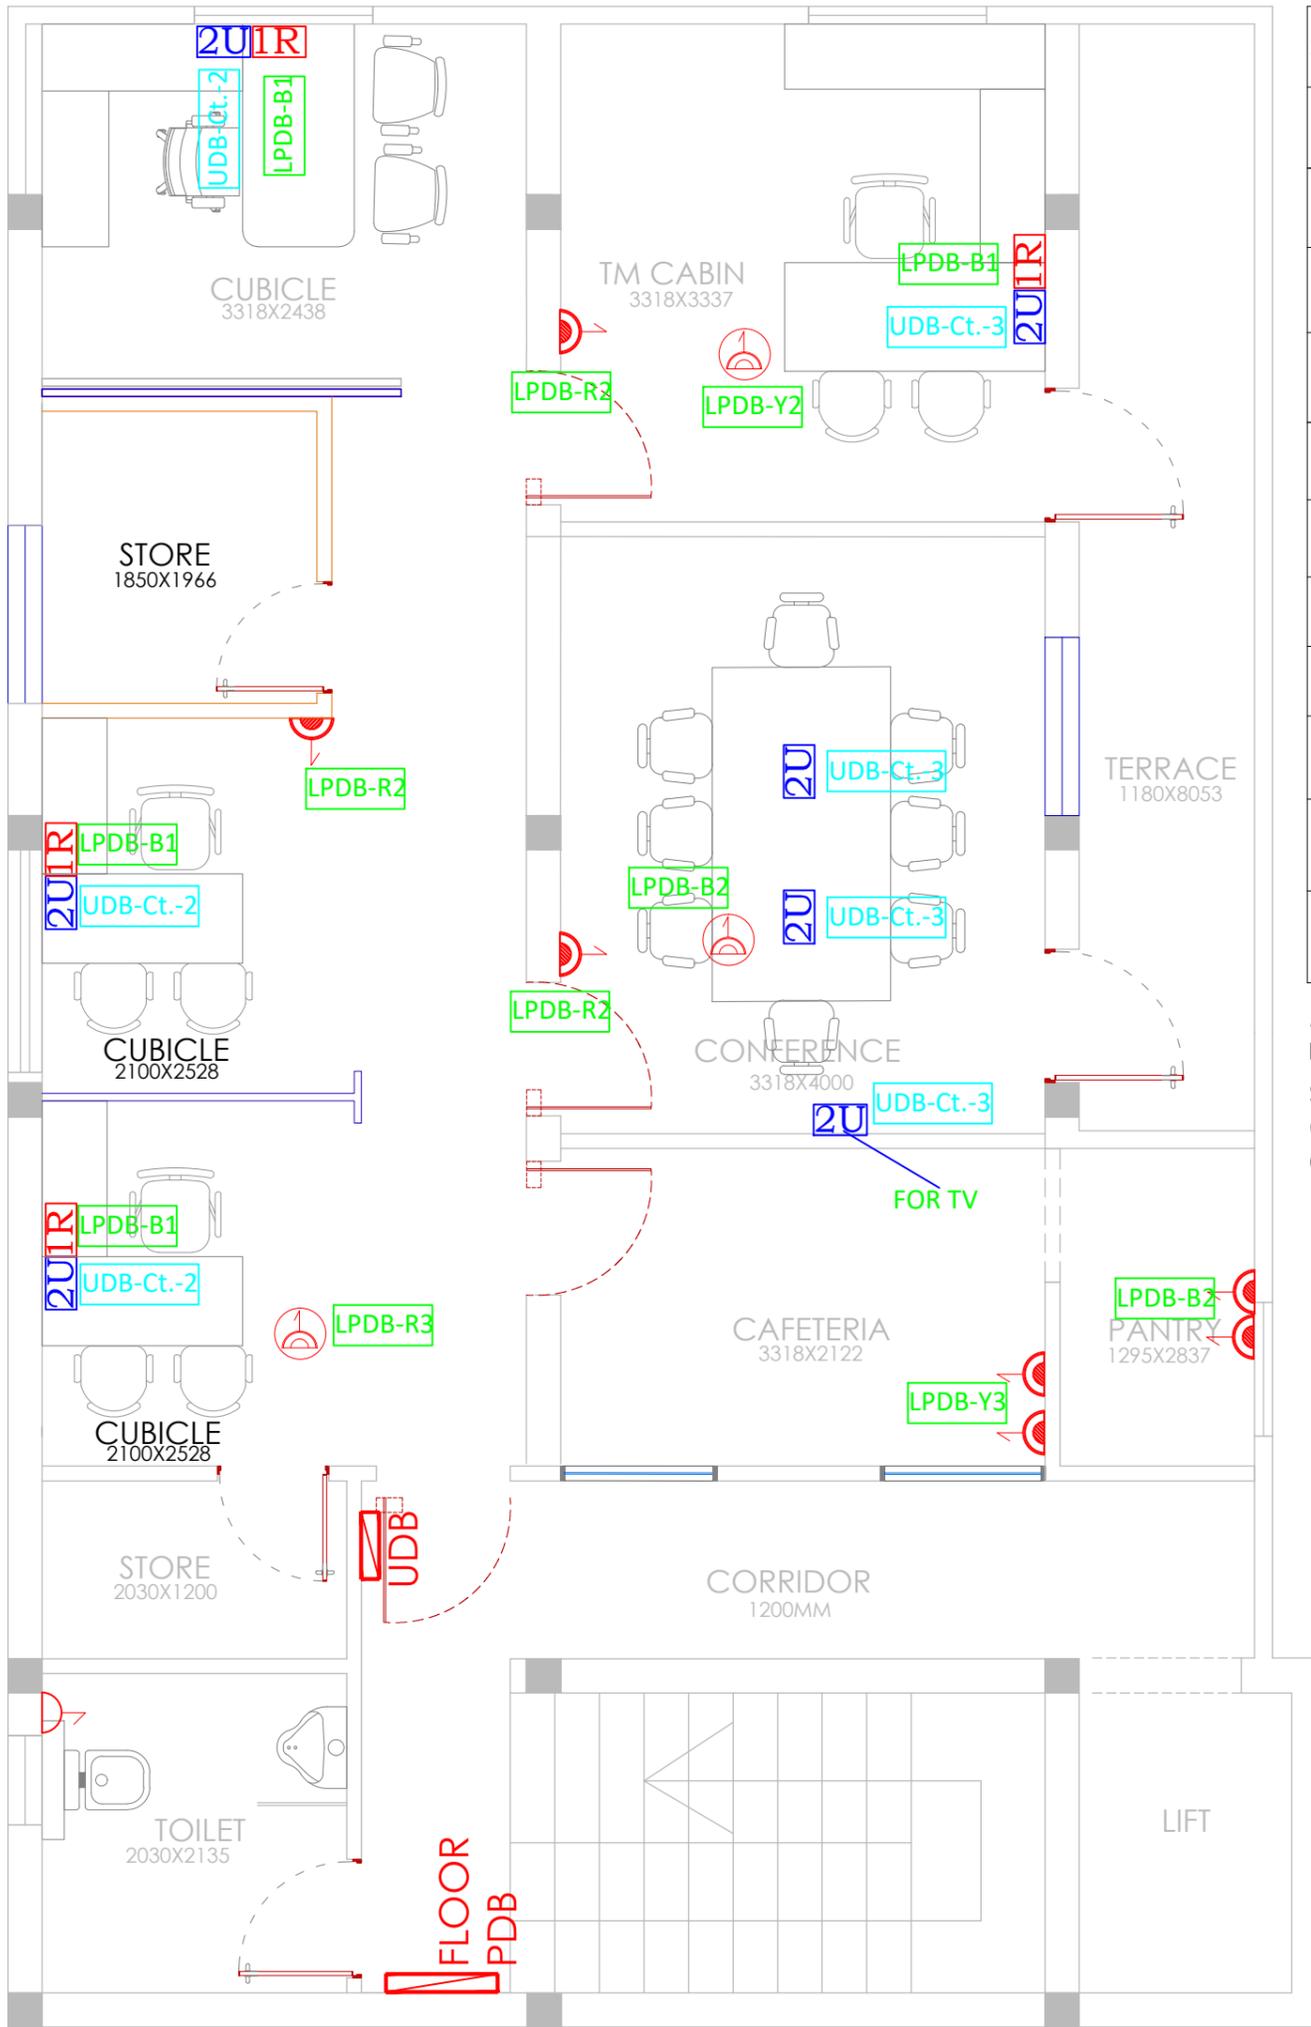


SECOND FLOOR

SYMBOL	DESCRIPTION
	2X13A INTERNATIONAL SOCKET WITH INO 16A SWITCH FOR UPS POWER
	IX5A SOCKET WITH INO 16A SWITCH FOR UPS POWER
	IX6/16A SOCKET WITH INO 16A SWITCH FOR UPS POWER
	3X13A INTERNATIONAL SOCKET WITH INO 16A SWITCH FOR UPS POWER
	2X13A INTERNATIONAL SOCKET WITH 2NOS 16A SWITCH FOR RAW POWER
	IX13A INTERNATIONAL SOCKET WITH INO 16A SWITCH FOR RAW POWER
	IX6/16A SOCKET WITH INO 16A SWITCH FOR RAW POWER
	5A SOCKET WITH INO 5A SWITCH FOR RAW POWER
	IX6/16A SOCKET WITH INO 16A SWITCH FOR RAW POWER AT CEILING
	20A METAL CALD SOCKET WITH 20A DP MCB FOR SPLIT A/C

ALL UTILITY/CLEANING RAW POWER SOCKETS SHOULD BE 300MM HT FROM FFL

SOCKETS FOR OTHER SERVICES LIKE A/C, FAS, PAS, CCTV ETC., TO BE PROVIDE AS PER THE LOCATION CONFIRMED BY THE VENDOR AT SITE CONDITION.

Client	BPCL	Project Title	PROPOSED INTERIORS FOR BPCL TERRITORY OFFICE @ VIJAYAWADA		Drawing Title	ELECTRICAL SOCKET LAYOUT	Dwg No	BPCL_TO_TD-012
GENERAL NOTE:		REV	DESCRIPTION	BY	DATE	Drawn		Architects New Designer Web Pvt Ltd No.185, 2nd Floor, 1st Main road, Nehru nagar, Kandanchavadi, Perungudi, Chennai - 600096 Tel: +91- 044 - 42125111www.designerweb.in
1. DRAWING TO BE USED ONLY FOR THE PURPOSE RELEASED.						Checked		
2. DO NOT SCALE THIS DRAWING, ONLY WRITTEN DIMENSIONS TO BE FOLLOWED.						Approved		
3. ANY DISCREPANCY IN THE DRAWING SHOULD BE IMMEDIATELY BROUGHT TO THE NOTICE OF ARCHITECT.						Date		
						Issued for		
						Scale	SCALE	

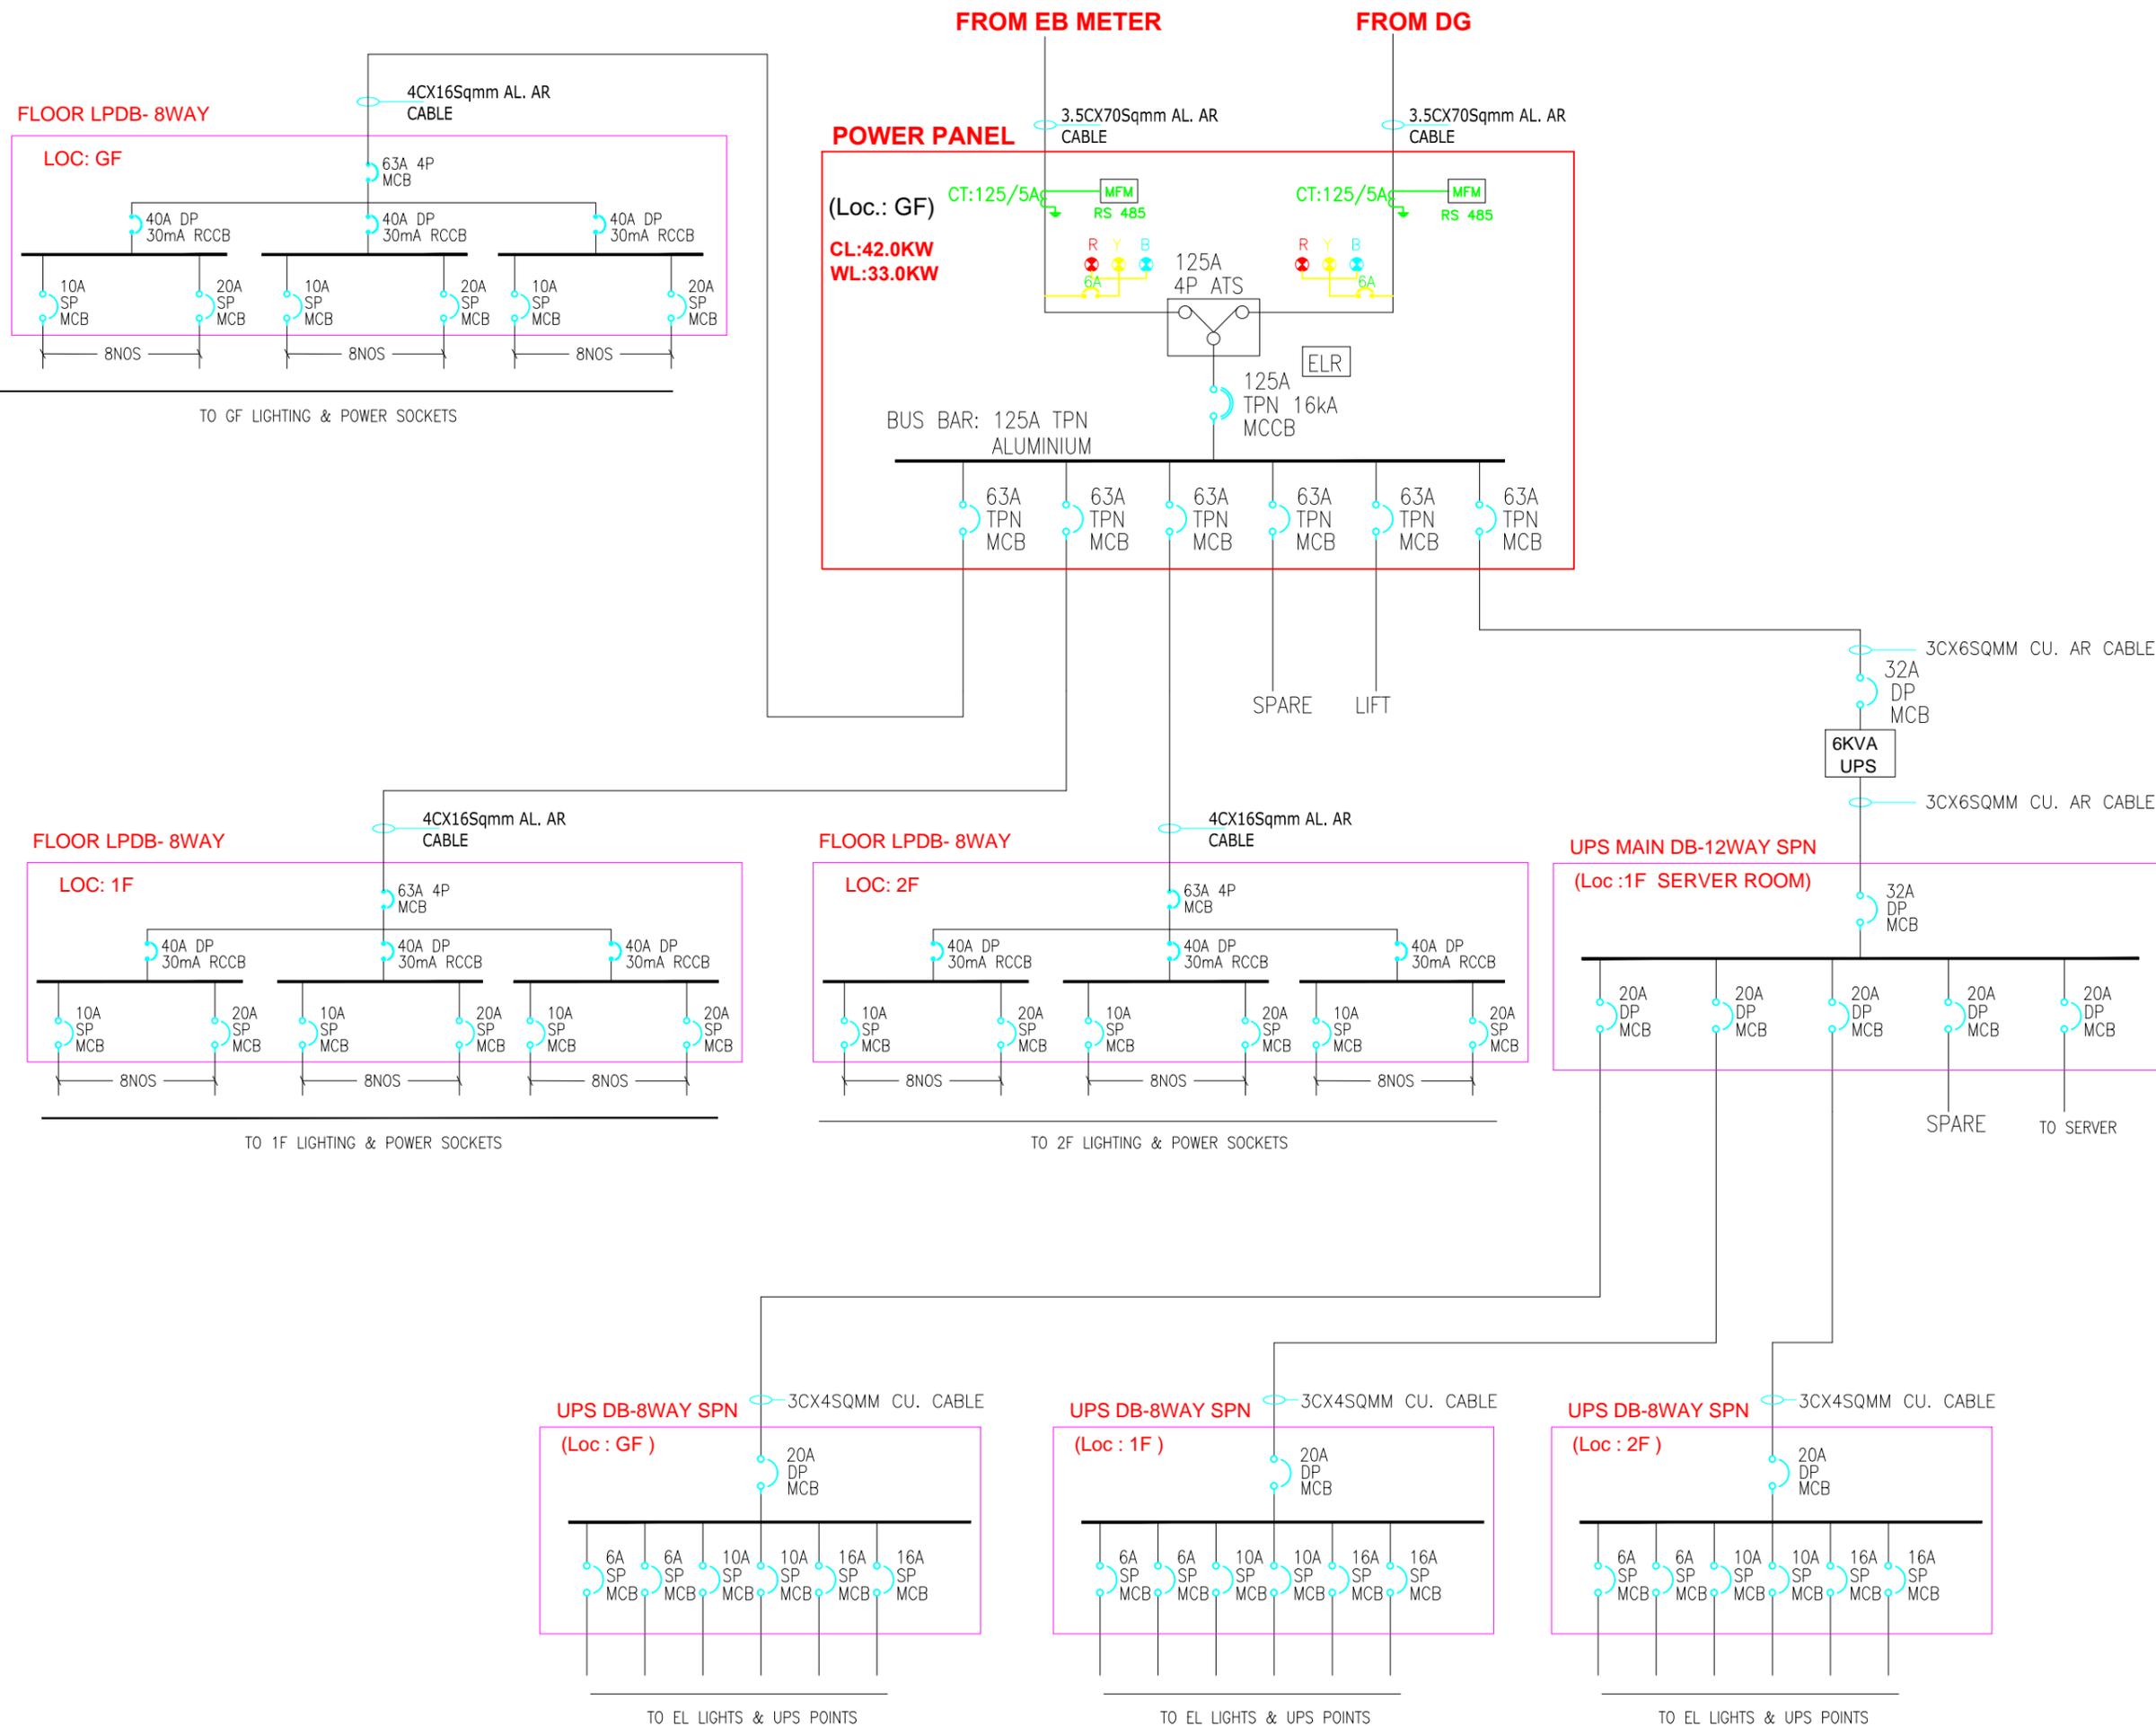

WIRING DETAILS:

- FOR LTG. POINT WIRING:
3CX1.5SQMM FRLS. CU. CABLE
- FOR DB TO LTG.SWITCH BOARD:
3RX2.5SQMM FRLS. CU. WIRE
- FOR DB TO 5A SOCKETS:
3RX2.5SQMM FRLS. CU. WIRE
- FOR 1.5/2TR/16A/20A SOCKETS:
3CX4.0SQMM FRLS. CU. CABLE

PROJECT
PROPOSED BPCL OFFICE
PROJECT AT VIJAYAWADA


DRAWING TITLE
ELECTRICAL SLD

DRAWING PURPOSE: FOR GFC


REV. NO: R1 **DATE:** 27-06-2024

ARCHITECT :
NEW DESIGNER WEB
Chennai

ELECTRICAL CONSULTANT :
AVB DESIGN SERVICES
7/23, Police office road,
St. Thomas mount, Chennai -16,
Ph:+91 9840957296,
EMail:project.avbdesign@gmail.com


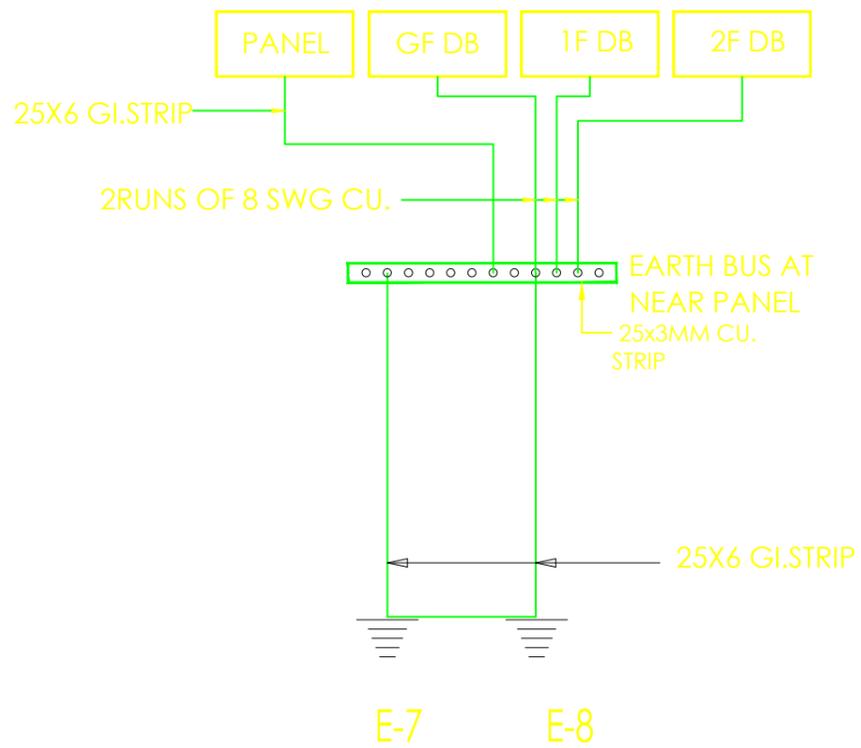


GENERAL BODY EARTHING

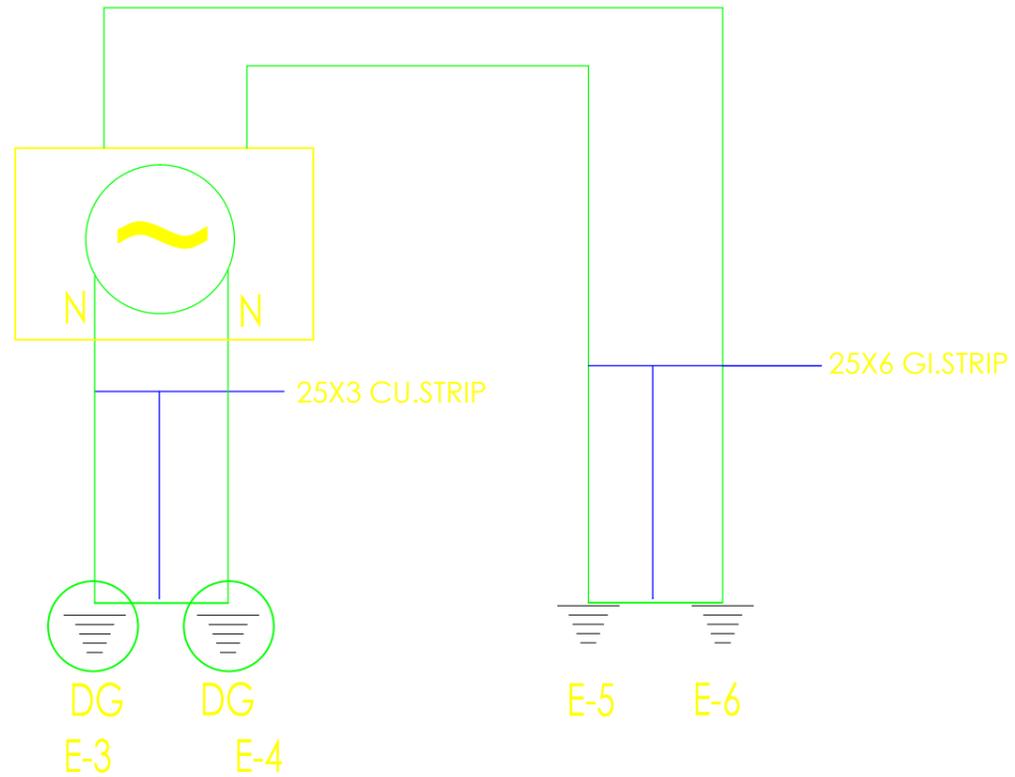

DG NEUTRAL EARTHING

DG BODY EARTHING

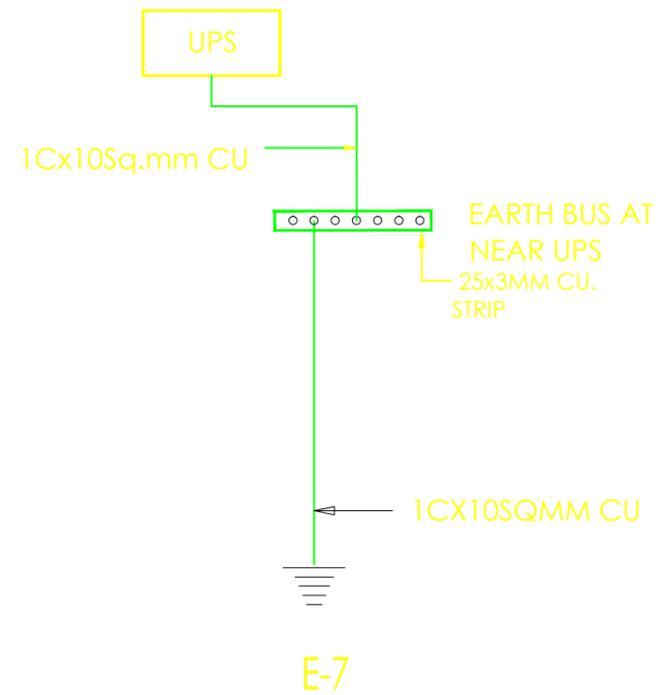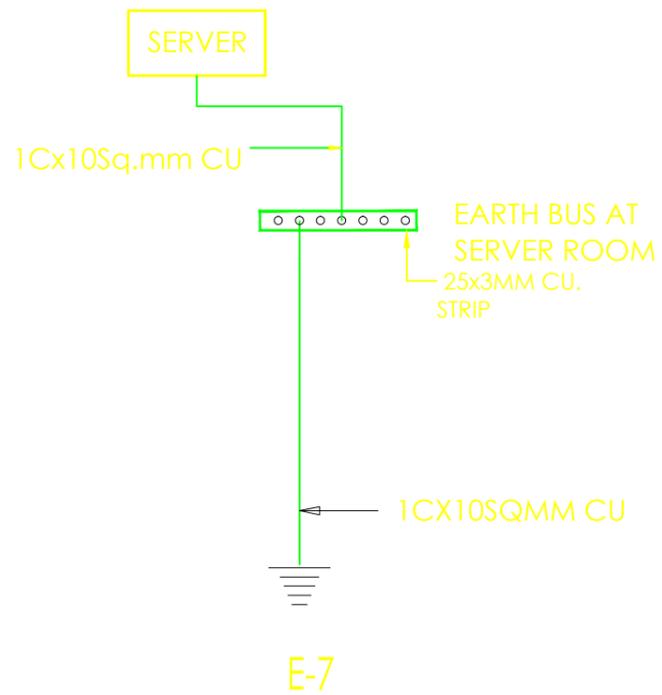

PROJECT
PROPOSED BPCL OFFICE
PROJECT AT VIJAYAWADA


DRAWING TITLE
EARTHING SLD

DRAWING PURPOSE: FOR GFC

REV. NO: R1 DATE: 27-06-2024

ARCHITECT :
NEW DESIGNER WEB
Chennai

ELECTRICAL CONSULTANT :
AVB DESIGN SERVICES
7/23, Police office road,
St. Thomas mount, Chennai -16,
Ph:+91 9840957296,
EMail:project.avbdesign@gmail.com

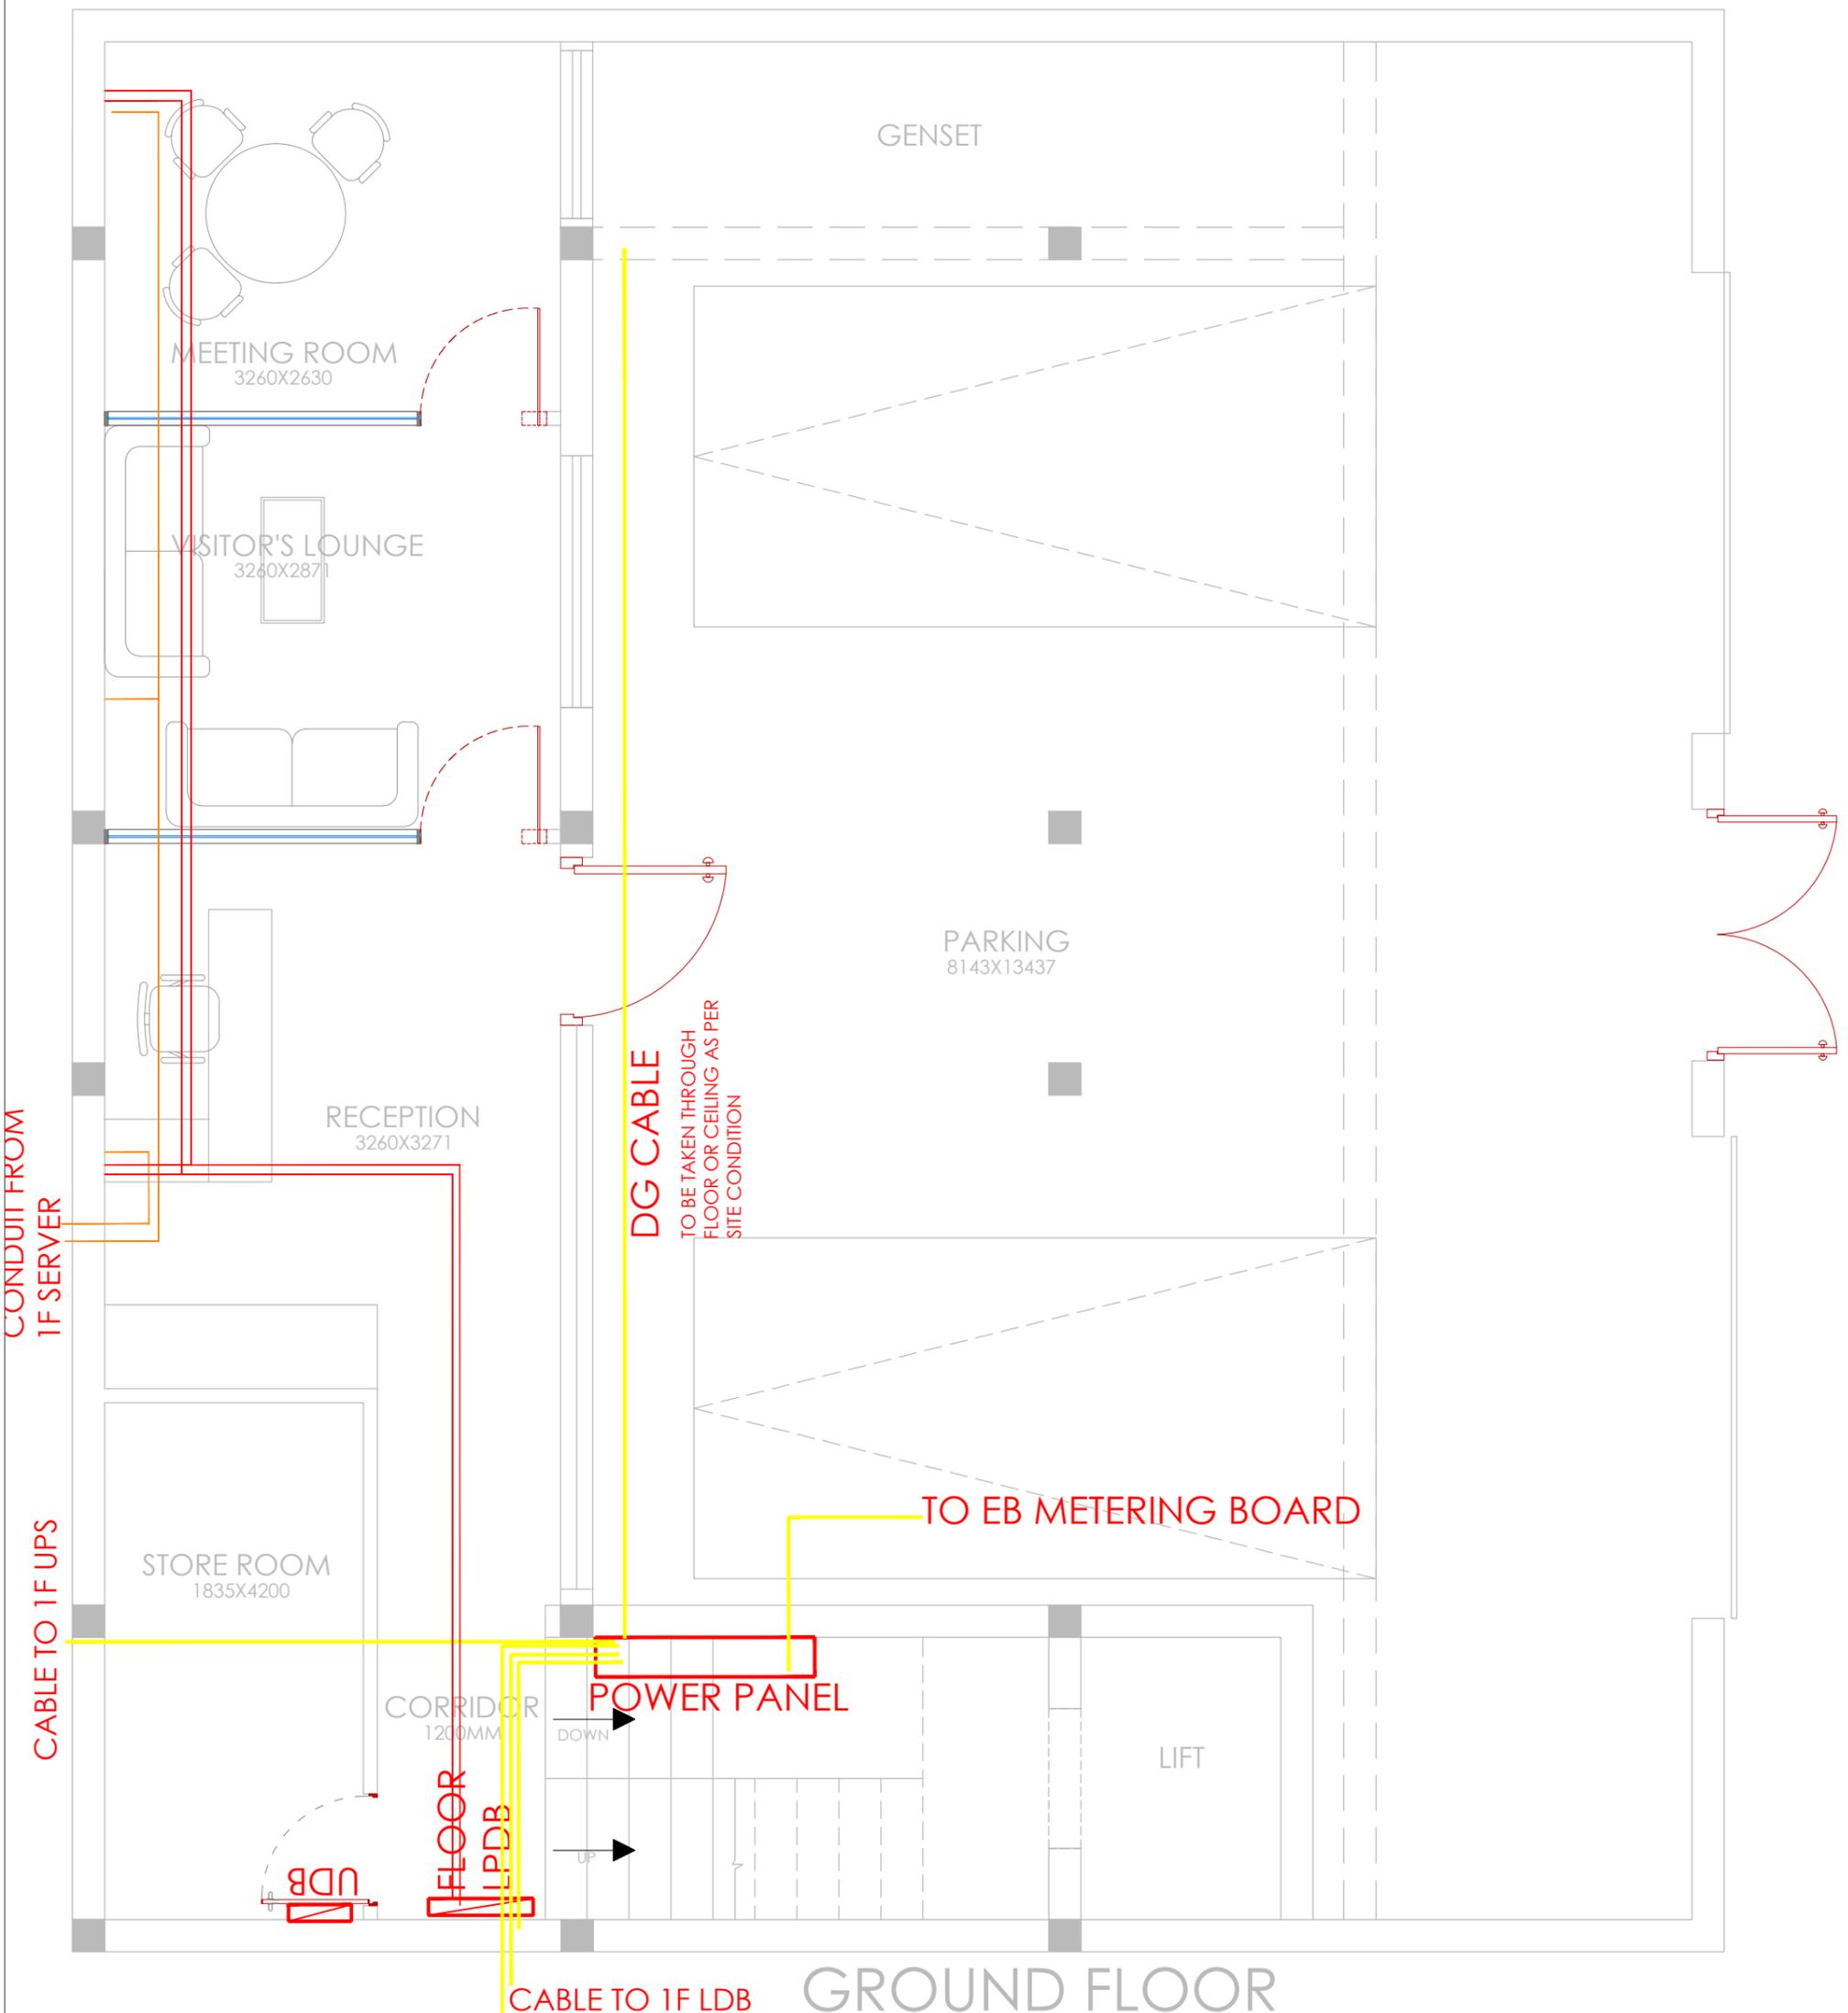


GROUND FLOOR

SYMBOL	DESCRIPTION
	FLOOR TRUNKING OR CONDUIT FOR POWER AND NETWORKING AS PER REQUIREMENT
	150X150X50MM GI FLOOR JUNCTION BOX
	25MM MS CEILING CONDUIT FOR ELECTRICAL
	25MM PVC CEILING CONDUIT FOR DATA & VOICE


Client BPCL	Project Title PROPOSED INTERIORS FOR BPCL TERRITORY OFFICE @ VIJAYAWADA	Drawing Title POWER & NETWORKING CONDUIT LAYOUT	Dwg No BPCL_TO_TD-015				
GENERAL NOTE: 1. DRAWING TO BE USED ONLY FOR THE PURPOSE RELEASED. 2. DO NOT SCALE THIS DRAWING, ONLY WRITTEN DIMENSIONS TO BE FOLLOWED. 3. ANY DISCREPANCY IN THE DRAWING SHOULD BE IMMEDIATELY BROUGHT TO THE NOTICE OF ARCHITECT.	REV	DESCRIPTION	BY	DATE	Drawn		Architects New Designer Web Pvt Ltd No.185, 2nd Floor, 1st Main road, Nehru nagar, Kandanchavadi, Perungudi, Chennai - 600096 Tel: +91- 044 - 42125111www.designerweb.in
					Checked		
					Approved		
					Date		
					Issued for		

SYMBOL	DESCRIPTION
	FLOOR TRUNKING OR CONDUIT FOR POWER AND NETWORKING AS PER REQUIREMENT
	150X150X50MM GI FLOOR JUNCTION BOX
	25MM MS CEILING CONDUIT FOR ELECTRICAL
	25MM PVC CEILING CONDUIT FOR DATA & VOICE

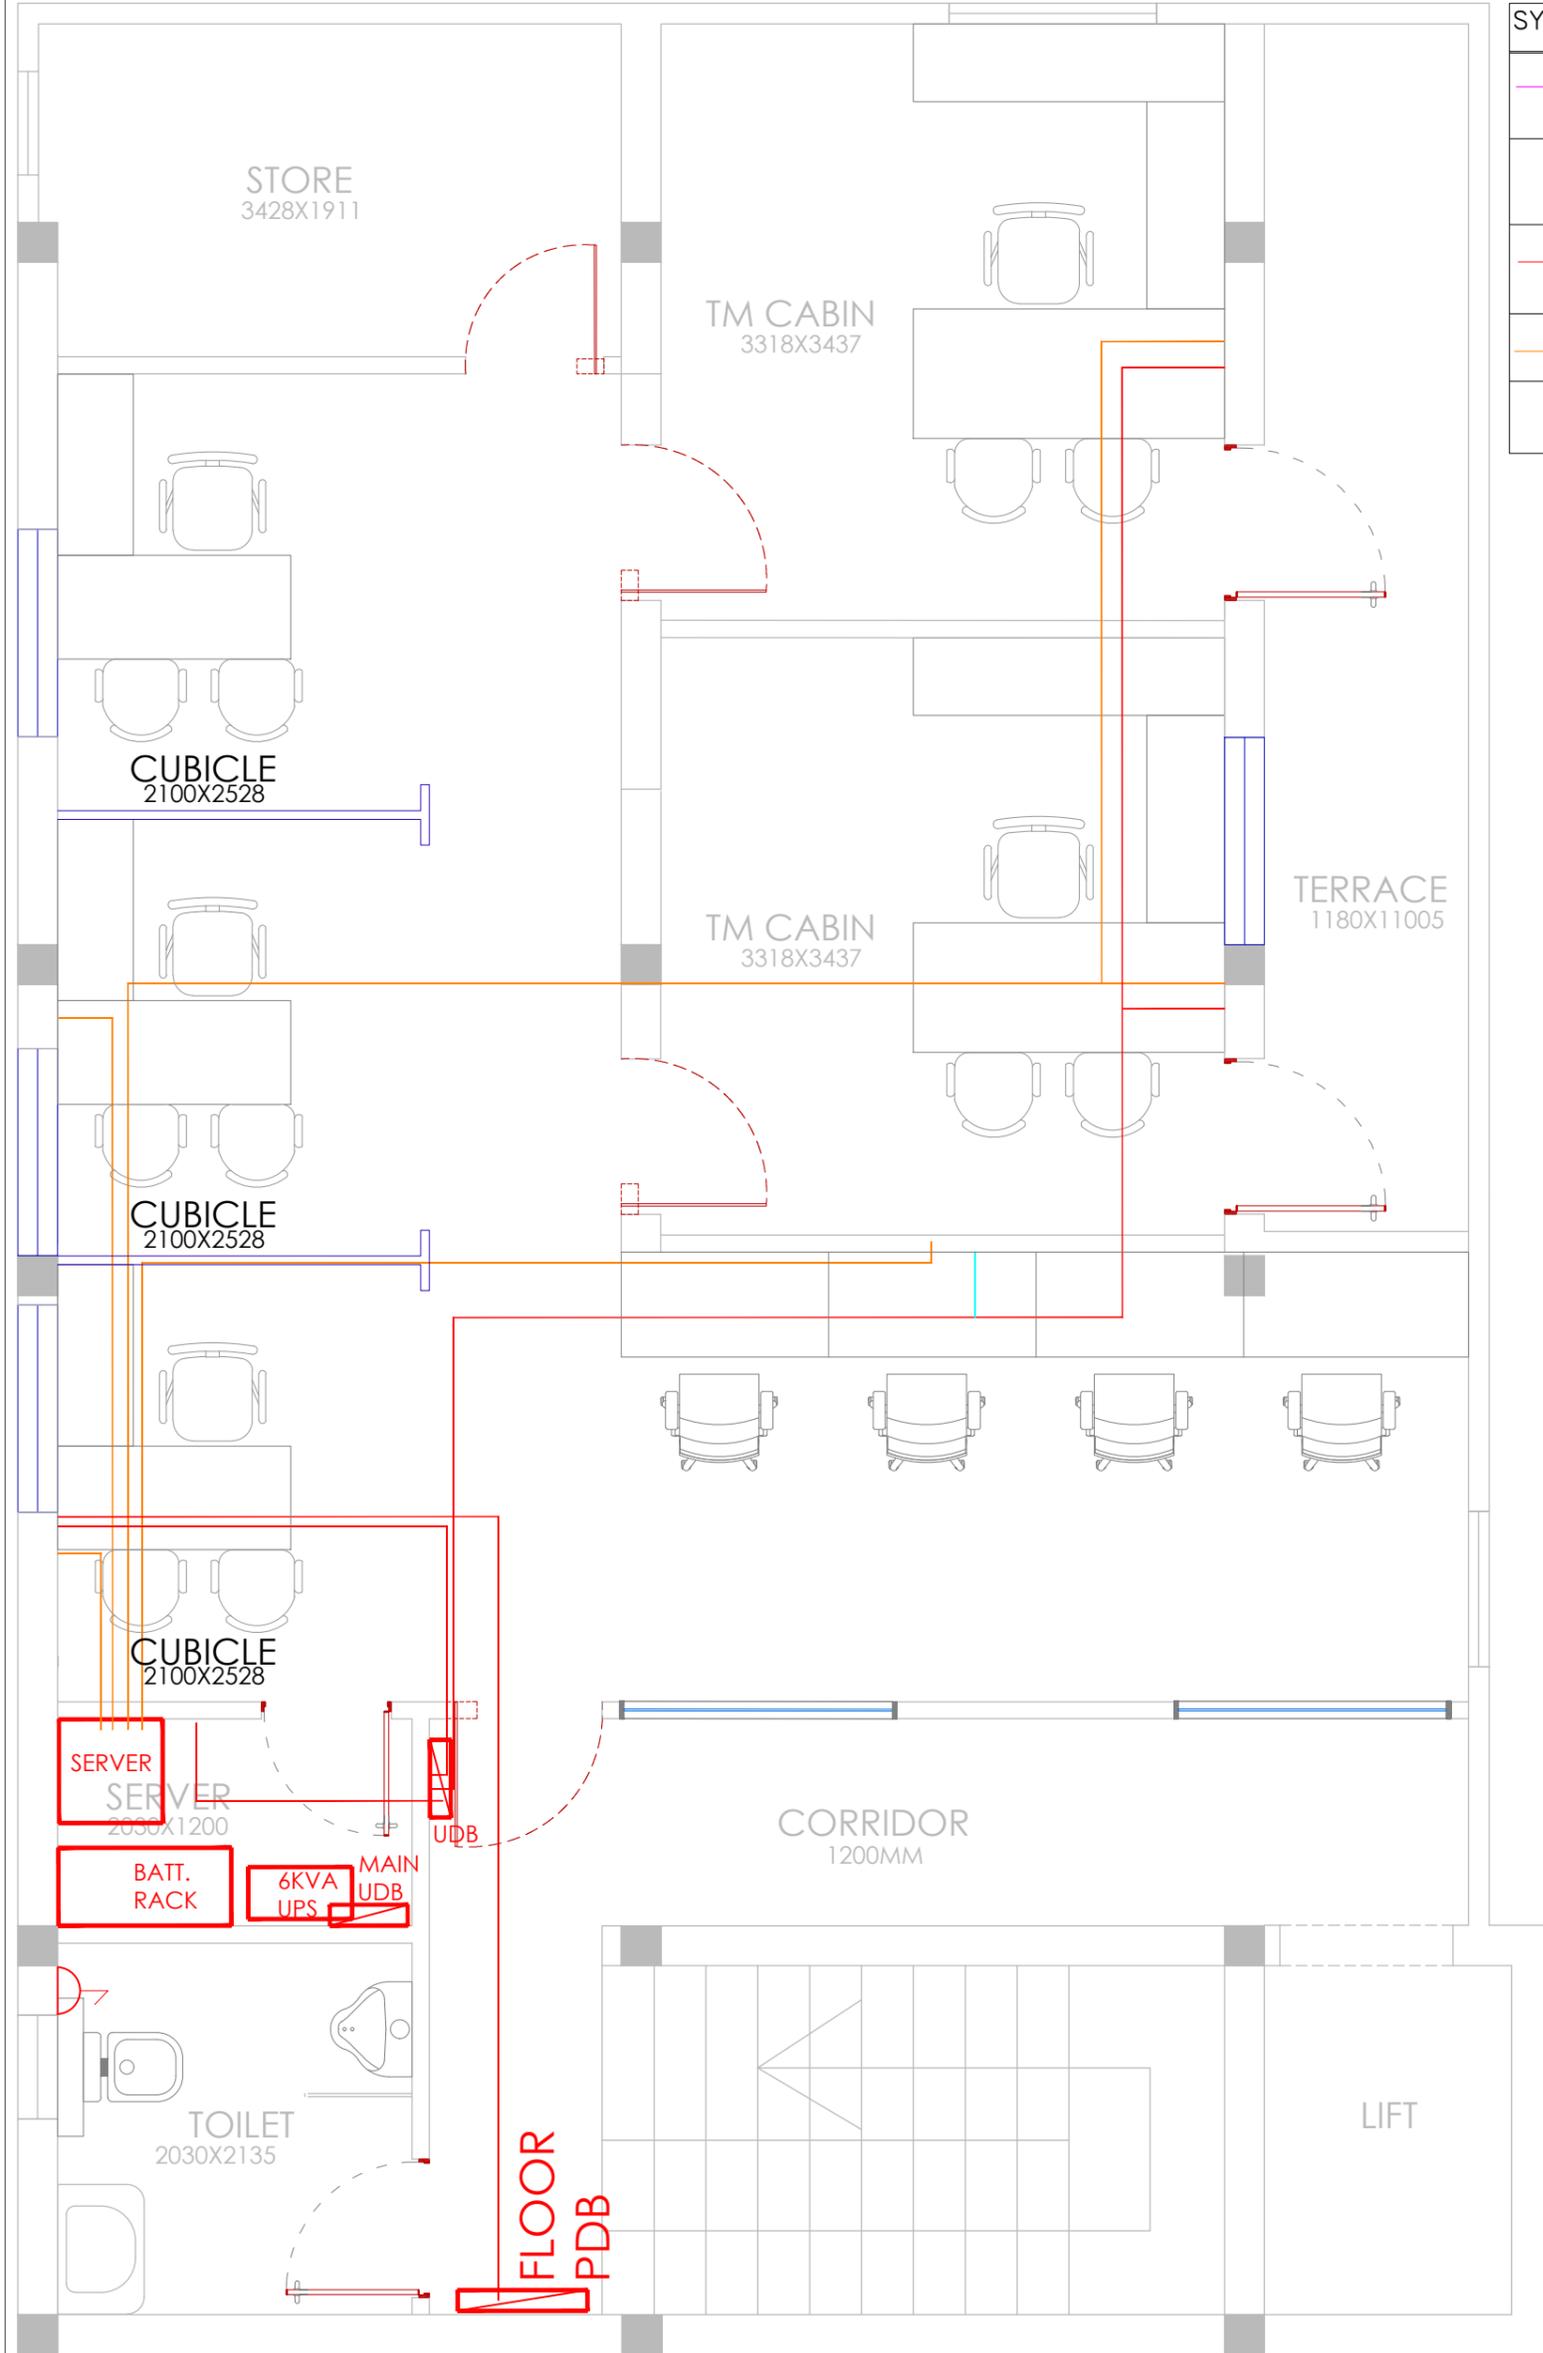

FIRST FLOOR

Client	BPCL	Project Title	PROPOSED INTERIORS FOR BPCL TERRITORY OFFICE @ VIJAYAWADA	Drawing Title	POWER & NETWORKING CONDUIT LAYOUT	Dwg No	BPCL_TO_TD-015
GENERAL NOTE:		REV	DESCRIPTION	BY	DATE	Architects	
1. DRAWING TO BE USED ONLY FOR THE PURPOSE RELEASED.							New Designer Web Pvt Ltd No.185, 2nd Floor, 1st Main road, Nehru nagar, Kandanchavadi, Perungudi, Chennai - 600096 Tel: +91- 044 - 42125111www.designerweb.in
2. DO NOT SCALE THIS DRAWING, ONLY WRITTEN DIMENSIONS TO BE FOLLOWED.							
3. ANY DISCREPANCY IN THE DRAWING SHOULD BE IMMEDIATELY BROUGHT TO THE NOTICE OF ARCHITECT.							

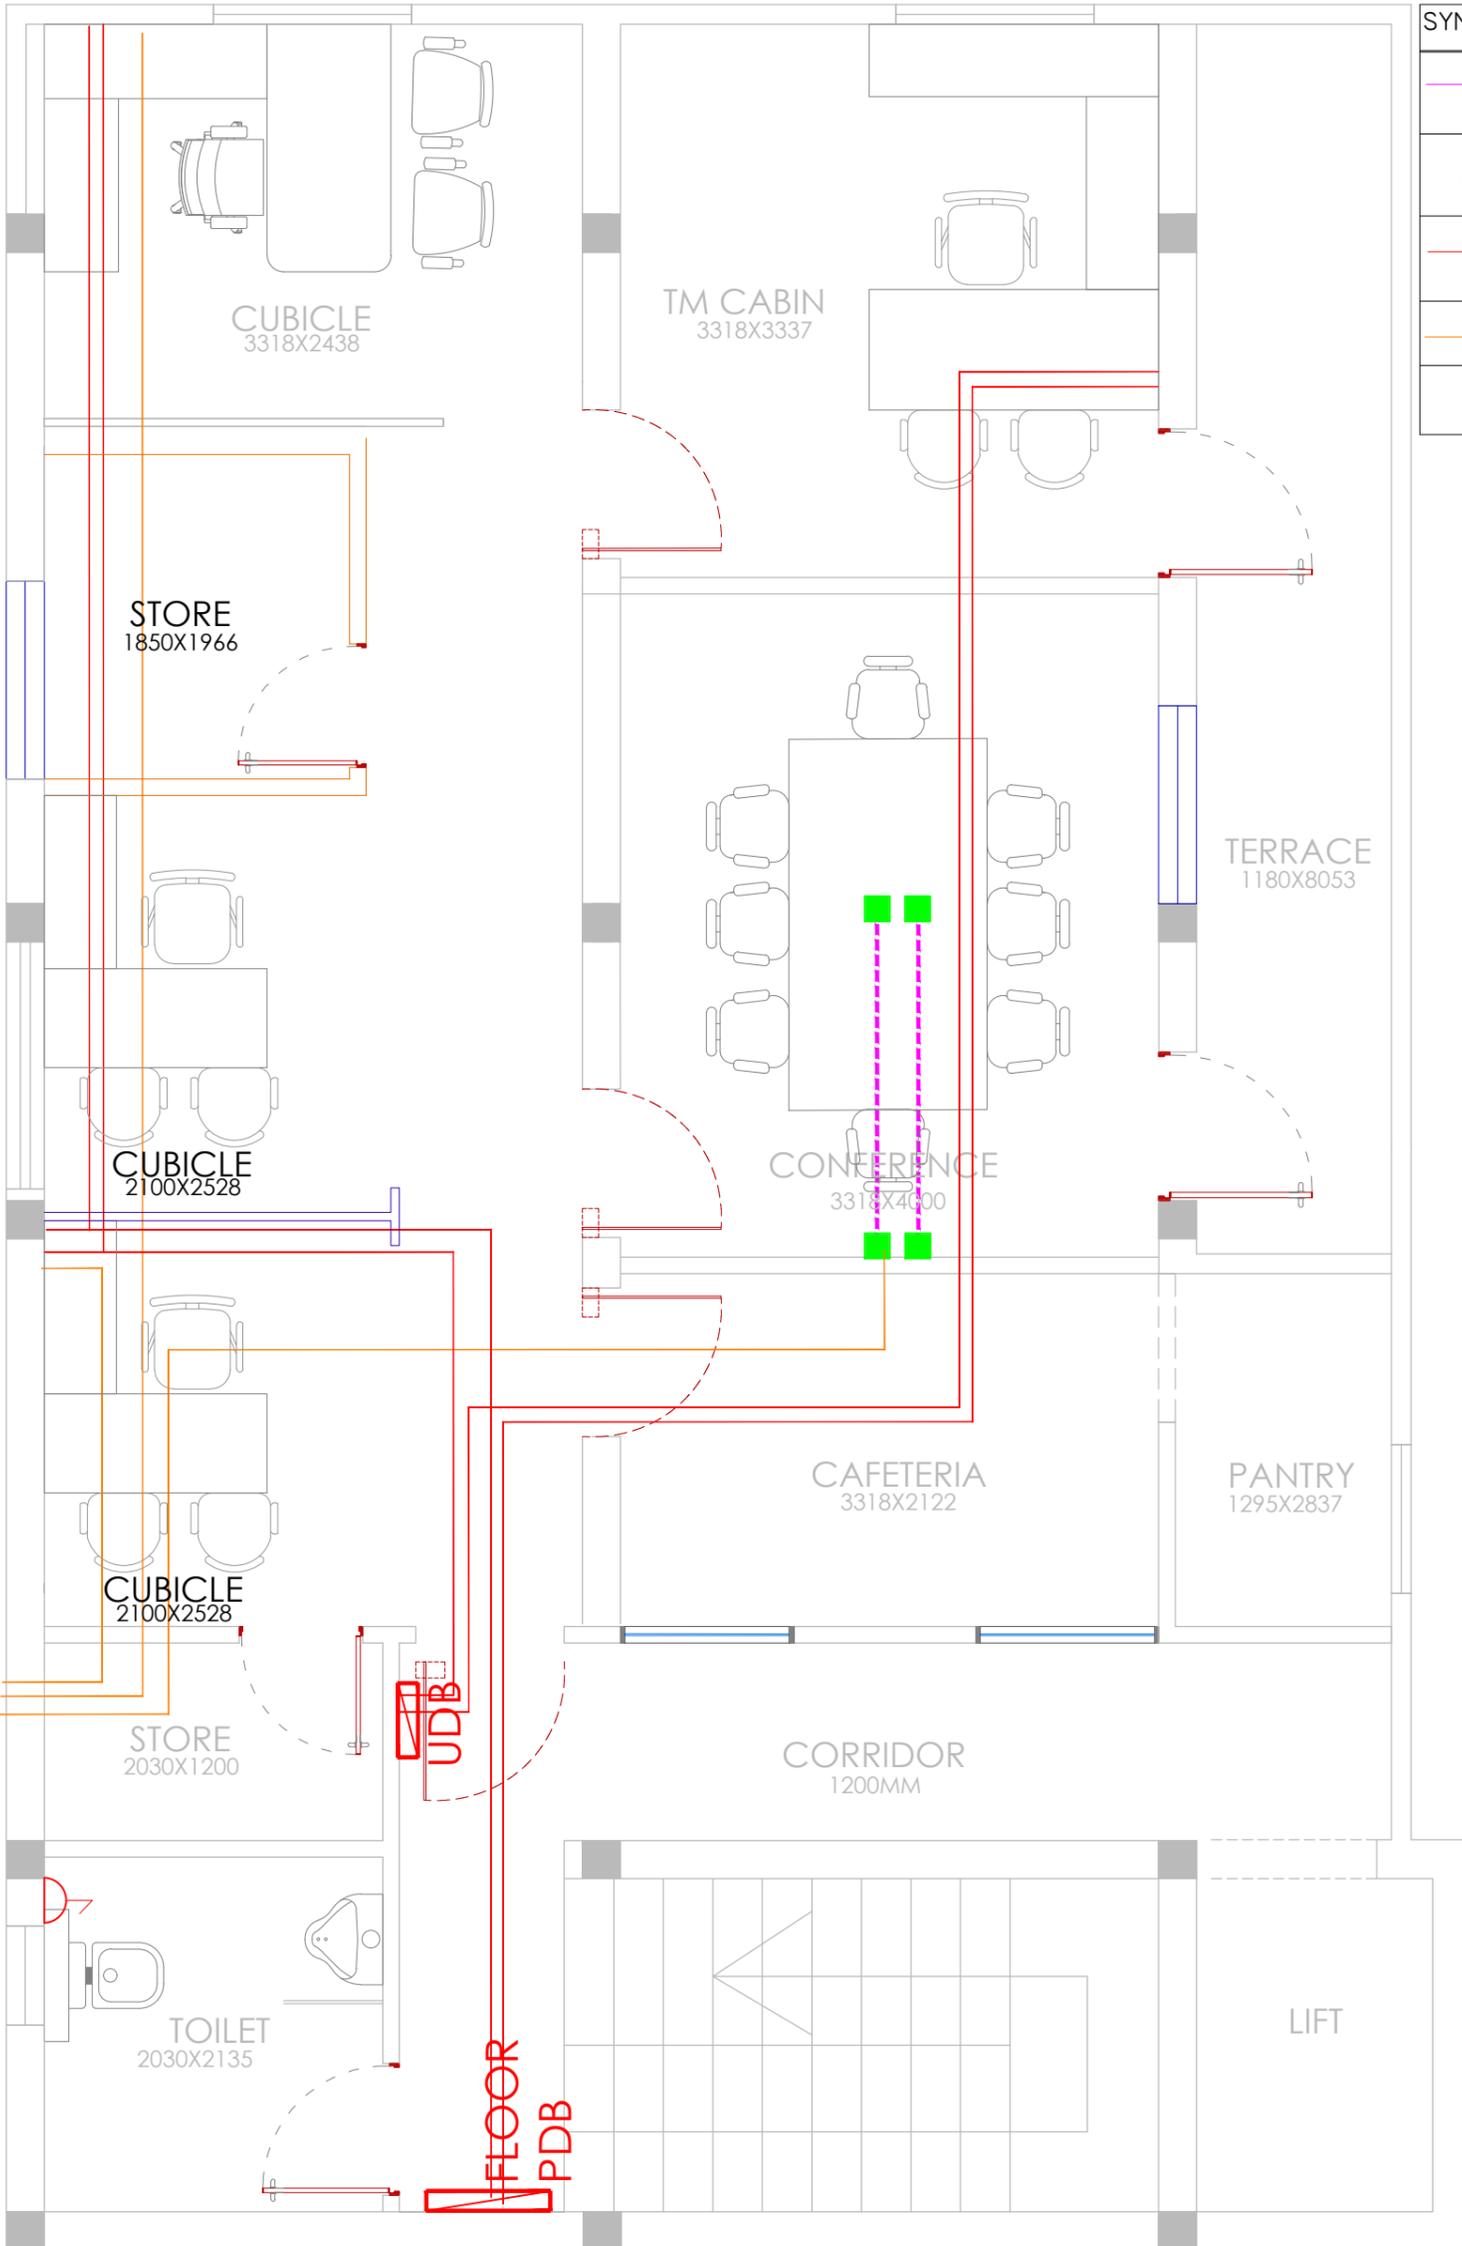

SYMBOL	DESCRIPTION
	FLOOR TRUNKING OR CONDUIT FOR POWER AND NETWORKING AS PER REQUIREMENT
	150X150X50MM GI FLOOR JUNCTION BOX
	25MM MS CEILING CONDUIT FOR ELECTRICAL
	25MM PVC CEILING CONDUIT FOR DATA & VOICE


SECOND FLOOR

CONDUIT FROM 1F SERVER

FLOOR PDB

UDB

Client	BPCL	Project Title	PROPOSED INTERIORS FOR BPCL TERRITORY OFFICE @ VIJAYAWADA		Drawing Title	POWER & NETWORKING CONDUIT LAYOUT		Dwg No	BPCL_TO_TD-015
GENERAL NOTE:		REV	DESCRIPTION	BY	DATE	Drawn			Architects New Designer Web Pvt Ltd No.185, 2nd Floor, 1st Main road, Nehru nagar, Kandanchavadi, Perungudi, Chennai - 600096 Tel: +91- 044 - 42125111www.designerweb.in
1. DRAWING TO BE USED ONLY FOR THE PURPOSE RELEASED.						Checked			
2. DO NOT SCALE THIS DRAWING, ONLY WRITTEN DIMENSIONS TO BE FOLLOWED.						Approved			
3. ANY DISCREPANCY IN THE DRAWING SHOULD BE IMMEDIATELY BROUGHT TO THE NOTICE OF ARCHITECT.						Date			
						Issued for	Scale		

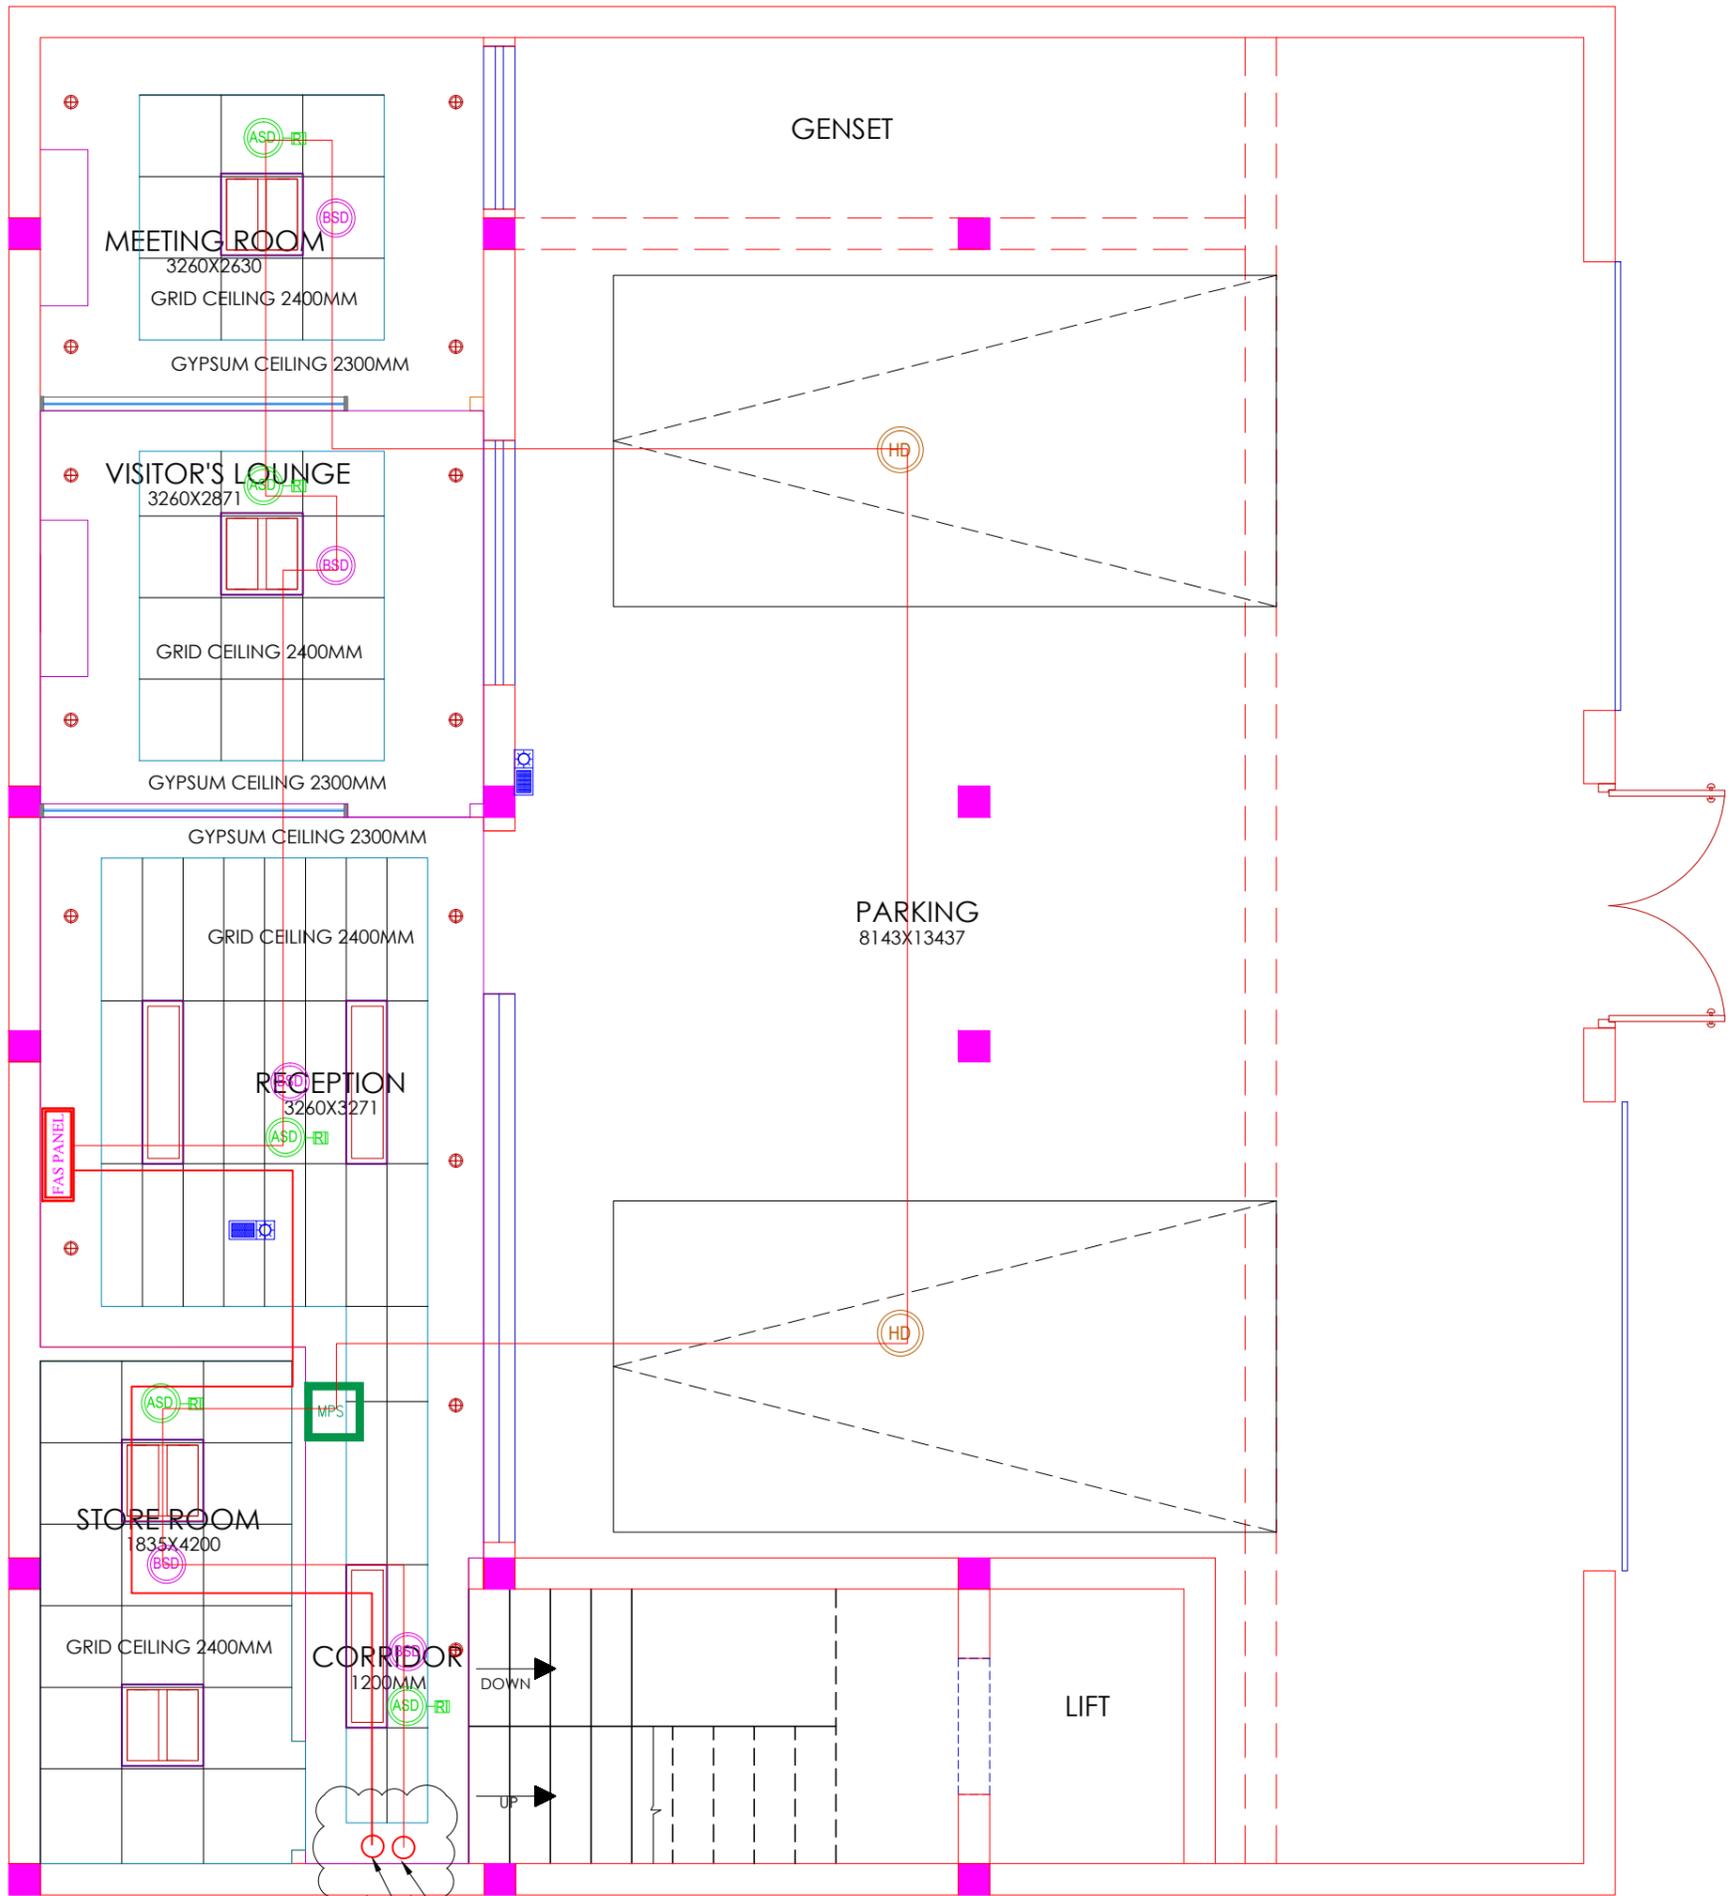

GROUND FLOOR


LEGEND

SYMBOL	DESCRIPTION
	ADDRESSABLE ABOVE SMOKE DETECTOR AT TRUE CEILING WITH RESPONSE INDICATOR
	ADDRESSABLE BELOW SMOKE DETECTOR AT FALSE CEILING
	ADDRESSABLE HEAT DETECTOR
	MANUAL CALL POINT
	SOUNDER CUM STROBE
	FIRE ALARM CONTROL PANEL
	2CX1.5SQMM ARMoured FRLS CABLE

CABLE CORE CUTTING TO FLOOR
DECIDED AS PER SITE CONDITION

FAS LOOP CABLE TO FIRST FLOOR
FAS LOOP CABLE FROM SECOND FLOOR

Client	BPCL	Project Title	PROPOSED INTERIORS FOR BPCL TERRITORY OFFICE @ VIJAYAWADA		Drawing Title	FIRE & SAFETY LAYOUT		Dwg No	BPCL_TO_TD-016
GENERAL NOTE:		REV	DESCRIPTION	BY	DATE	Drawn		Architects New Designer Web Pvt Ltd No.185, 2nd Floor, 1st Main road, Nehru nagar, Kandanchavadi, Perungudi, Chennai - 600096 Tel: +91- 044 - 4212511 www.designerweb.in	
1. DRAWING TO BE USED ONLY FOR THE PURPOSE RELEASED.						Checked			
2. DO NOT SCALE THIS DRAWING, ONLY WRITTEN DIMENSIONS TO BE FOLLOWED.						Approved			
3. ANY DISCREPANCY IN THE DRAWING SHOULD BE IMMEDIATELY BROUGHT TO THE NOTICE OF ARCHITECT.						Date			
						Issued for			

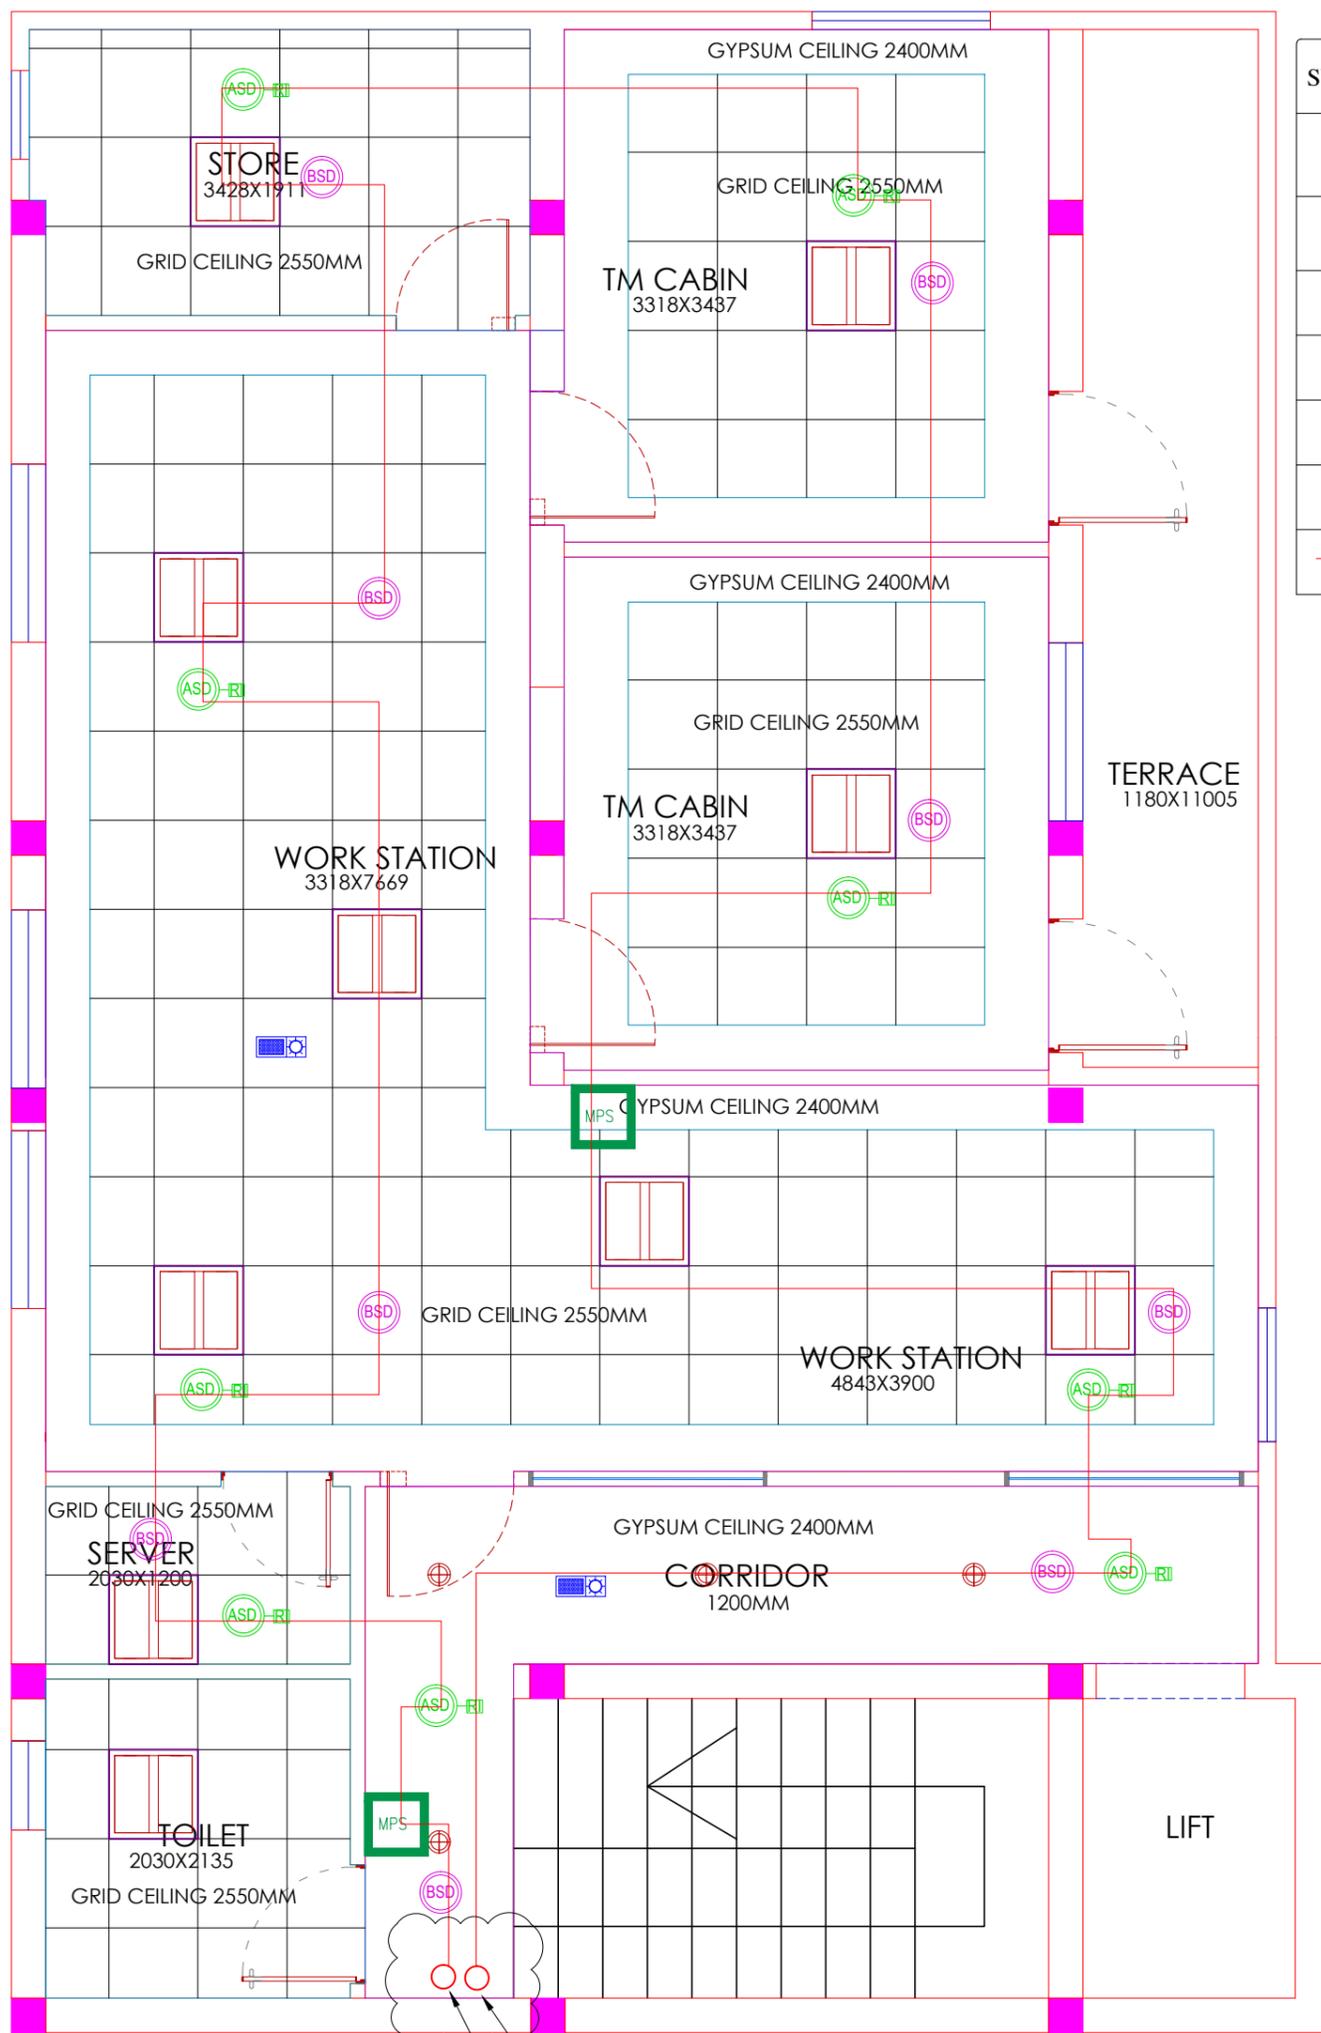

LEGEND


SYMBOL	DESCRIPTION
	ADDRESSABLE ABOVE SMOKE DETECTOR AT TRUE CEILING WITH RESPONSE INDICATOR
	ADDRESSABLE BELOW SMOKE DETECTOR AT FALSE CEILING
	ADDRESSABLE HEAT DETECTOR
	MANUAL CALL POINT
	SOUNDER CUM STROBE
	FIRE ALARM CONTROL PANEL
	2CX1.5SQMM ARMOURED FRLS CABLE

CABLE CORE CUTTING TO FLOOR
DECIDED AS PER SITE CONDITION

FAS LOOP CABLE FROM FIRST FLOOR
FAS LOOP CABLE TO SECOND FLOOR

FIRST FLOOR

Client	BPCL	Project Title	PROPOSED INTERIORS FOR BPCL TERRITORY OFFICE @ VIJAYAWADA	Drawing Title	FIRE & SAFETY LAYOUT	Dwg No	BPCL_TO_TD-016
GENERAL NOTE:		REV	DESCRIPTION	BY	DATE	Architects	
1. DRAWING TO BE USED ONLY FOR THE PURPOSE RELEASED.						 New Designer Web Pvt Ltd No.185, 2nd Floor, 1st Main road, Nehru nagar, Kandanchavadi, Perungudi, Chennai - 600096 Tel: +91- 044 - 4212511 www.designerweb.in	
2. DO NOT SCALE THIS DRAWING, ONLY WRITTEN DIMENSIONS TO BE FOLLOWED.							
3. ANY DISCREPANCY IN THE DRAWING SHOULD BE IMMEDIATELY BROUGHT TO THE NOTICE OF ARCHITECT.							
				Drawn		Scale	
				Checked		SCALE	
				Approved			
				Date			
				Issued for			

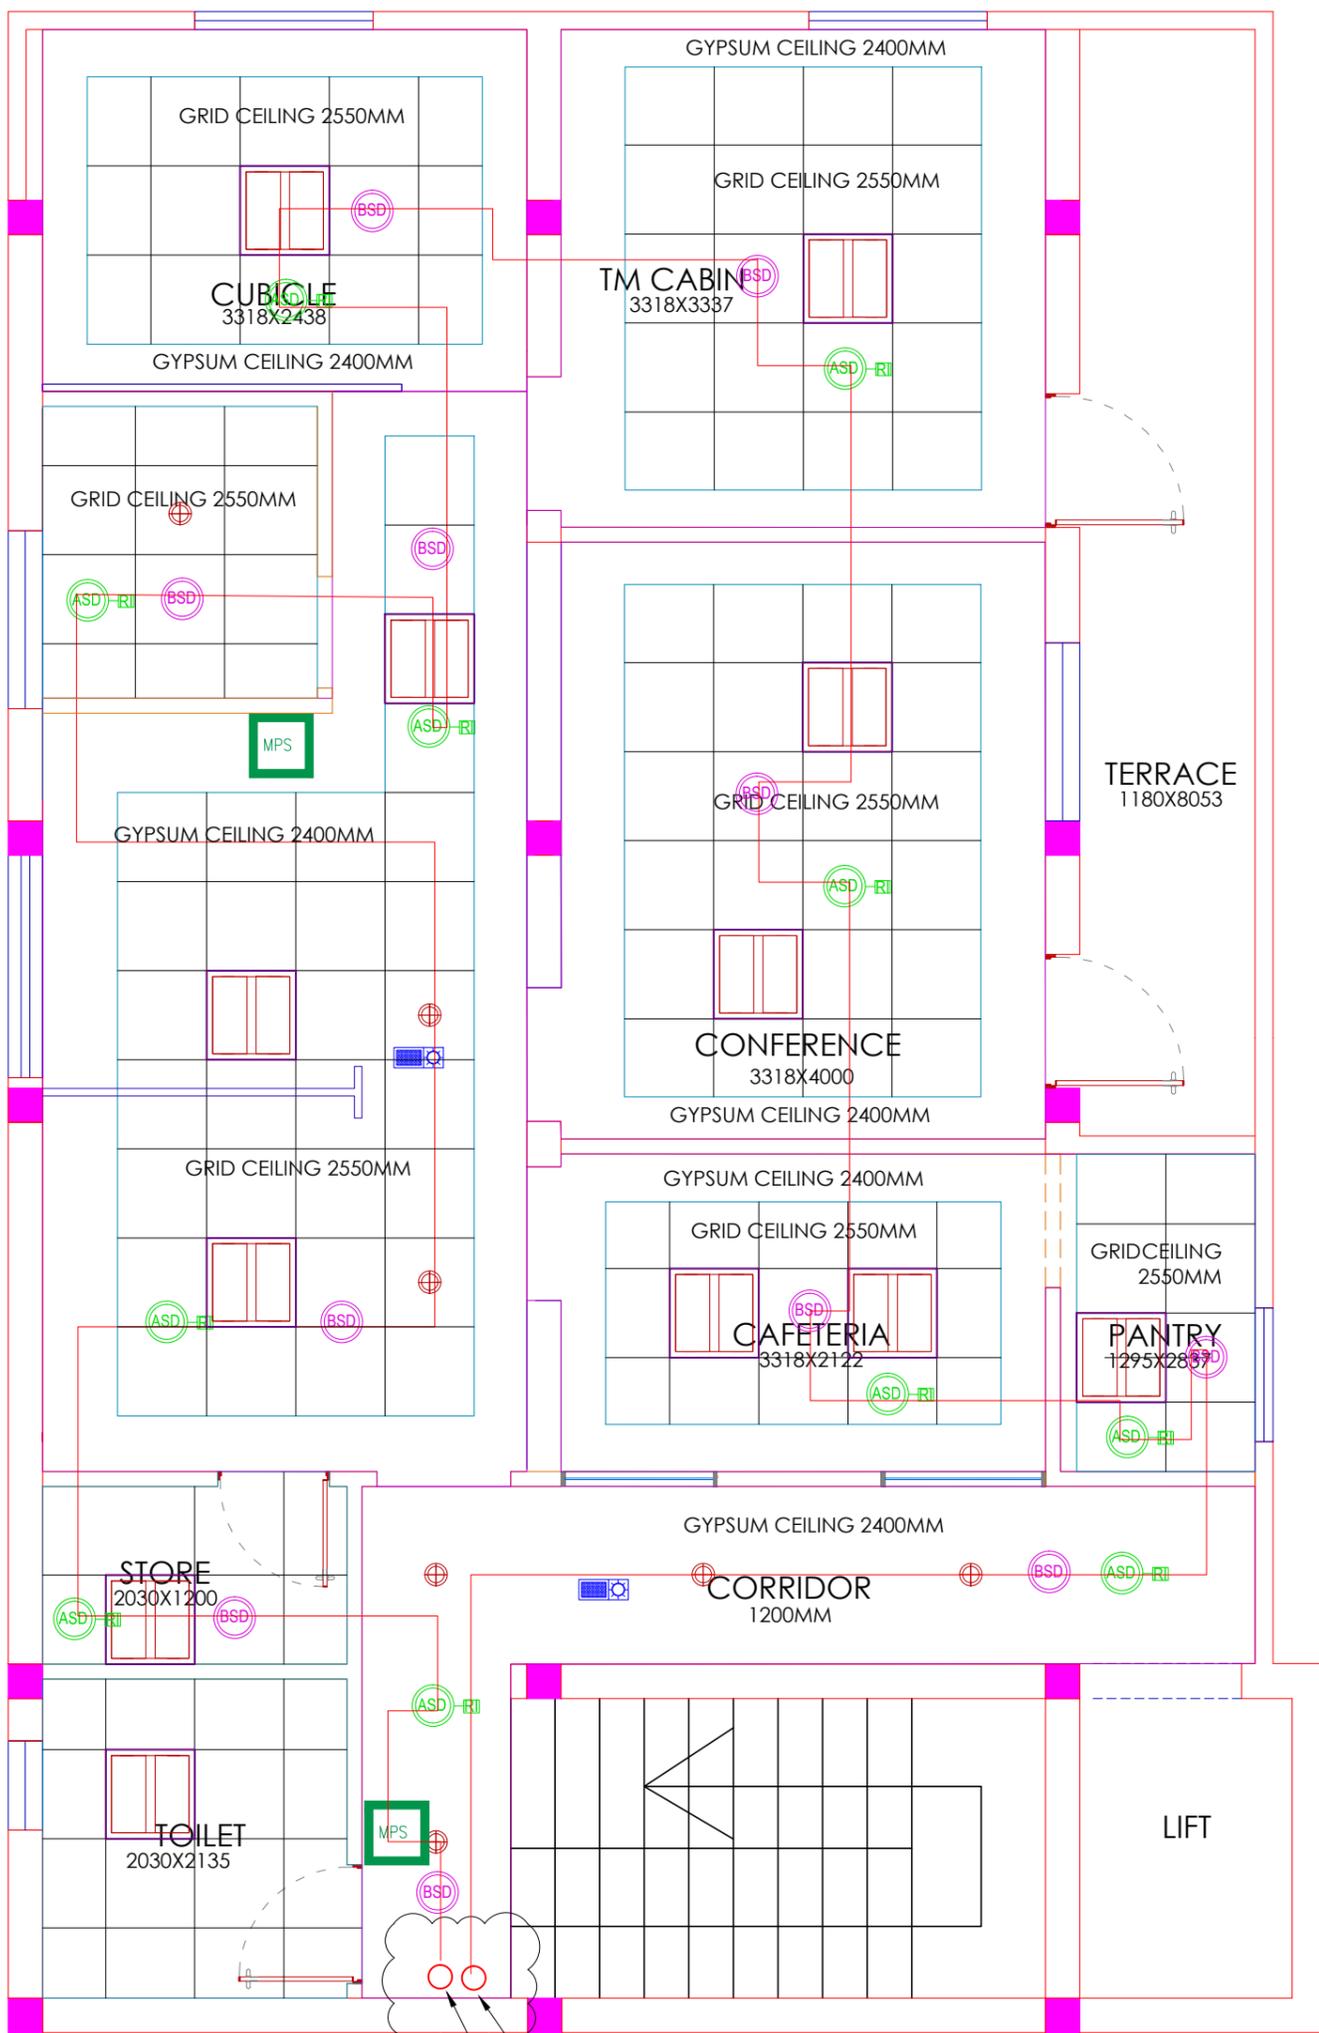

LEGEND


SYMBOL	DESCRIPTION
	ADDRESSABLE ABOVE SMOKE DETECTOR AT TRUE CEILING WITH RESPONSE INDICATOR
	ADDRESSABLE BELOW SMOKE DETECTOR AT FALSE CEILING
	ADDRESSABLE HEAT DETECTOR
	MANUAL CALL POINT
	SOUNDER CUM STROBE
	FIRE ALARM CONTROL PANEL
	2CX1.5SQMM ARMOURD FRLS CABLE

CABLE CORE CUTTING TO FLOOR
DECIDED AS PER SITE CONDITION

FAS LOOP CABLE FROM FIRST FLOOR
FAS LOOP CABLE TO SECOND FLOOR

SECOND FLOOR

Client	BPCL	Project Title	PROPOSED INTERIORS FOR BPCL TERRITORY OFFICE @ VIJAYAWADA	Drawing Title	FIRE & SAFETY LAYOUT	Dwg No	BPCL_TO_TD-016
GENERAL NOTE:		REV	DESCRIPTION	BY	DATE	Architects	
1. DRAWING TO BE USED ONLY FOR THE PURPOSE RELEASED.						 New Designer Web Pvt Ltd No.185, 2nd Floor, 1st Main road, Nehru nagar, Kandanchavadi, Perungudi, Chennai - 600096 Tel: +91- 044 - 42125111www.designerweb.in	
2. DO NOT SCALE THIS DRAWING, ONLY WRITTEN DIMENSIONS TO BE FOLLOWED.							
3. ANY DISCREPANCY IN THE DRAWING SHOULD BE IMMEDIATELY BROUGHT TO THE NOTICE OF ARCHITECT.							
				Drawn		Scale	SCALE
				Checked			
				Approved			
				Date			
				Issued for			

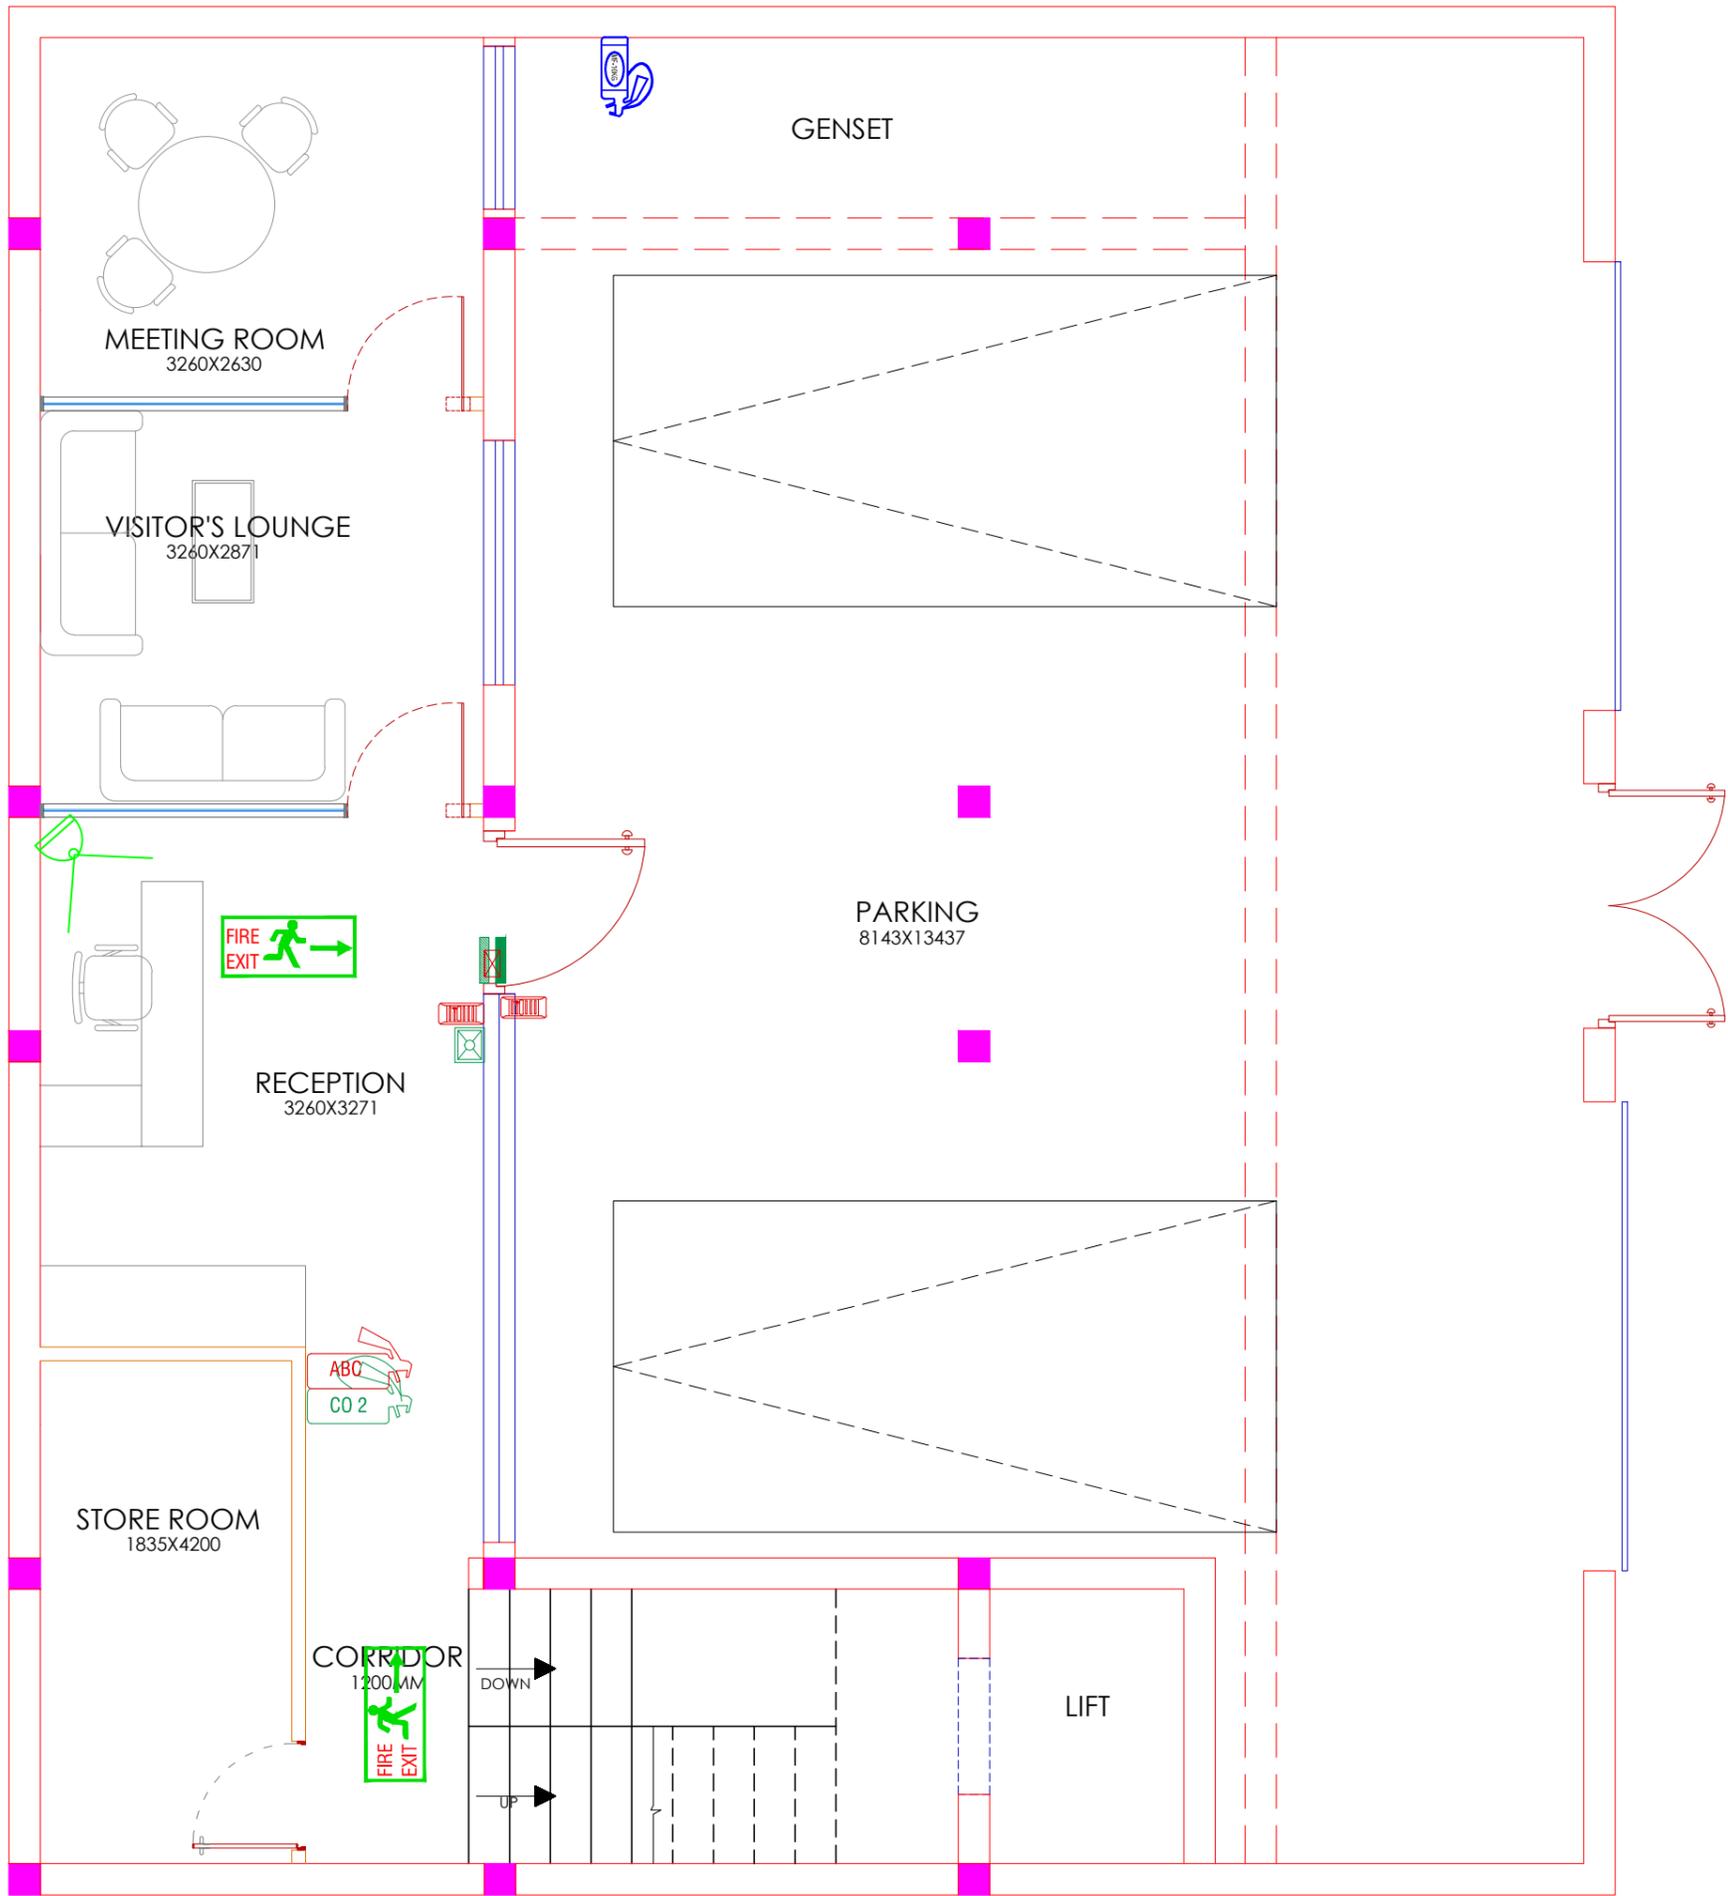


GROUND FLOOR

LEGEND

SYMBOL	DESCRIPTION
	ABC TYPE FLOOR MOUNT EXTINGUISHER 5kg
	CO2 TYPE FLOOR MOUNT EXTINGUISHER 4.5kg
	MECHANICAL FOAM TYPE FIRE EXTINGUISHER 10KG
	FIRE EXIT SIGNAGE
	ELECTRO MAGNETIC LOCK
	CARD READER
	EMERGENCY DOOR RELEASE
	DOOR BUZZAR
	NETWORK CAMERA
	CEILING MOUNT FIRE EXTINGUISHER 5KG

Client	BPCL	Project Title	PROPOSED INTERIORS FOR BPCL TERRITORY OFFICE @ VIJAYAWADA	Drawing Title	SIGNAGE, EXTINGUISHER, CCTV & ACCESS LAYOUT	Dwg No	BPCL_TO_TD-017
GENERAL NOTE:		REV	DESCRIPTION	BY	DATE	Architects	
1. DRAWING TO BE USED ONLY FOR THE PURPOSE RELEASED.						New Designer Web Pvt Ltd No.185, 2nd Floor, 1st Main road, Nehru nagar, Kandanchavadi, Perungudi, Chennai - 600096 Tel: +91- 044 - 4212511 www.designerweb.in	
2. DO NOT SCALE THIS DRAWING, ONLY WRITTEN DIMENSIONS TO BE FOLLOWED.							
3. ANY DISCREPANCY IN THE DRAWING SHOULD BE IMMEDIATELY BROUGHT TO THE NOTICE OF ARCHITECT.							
Drawn Checked Approved Date Issued for						Scale	SCALE

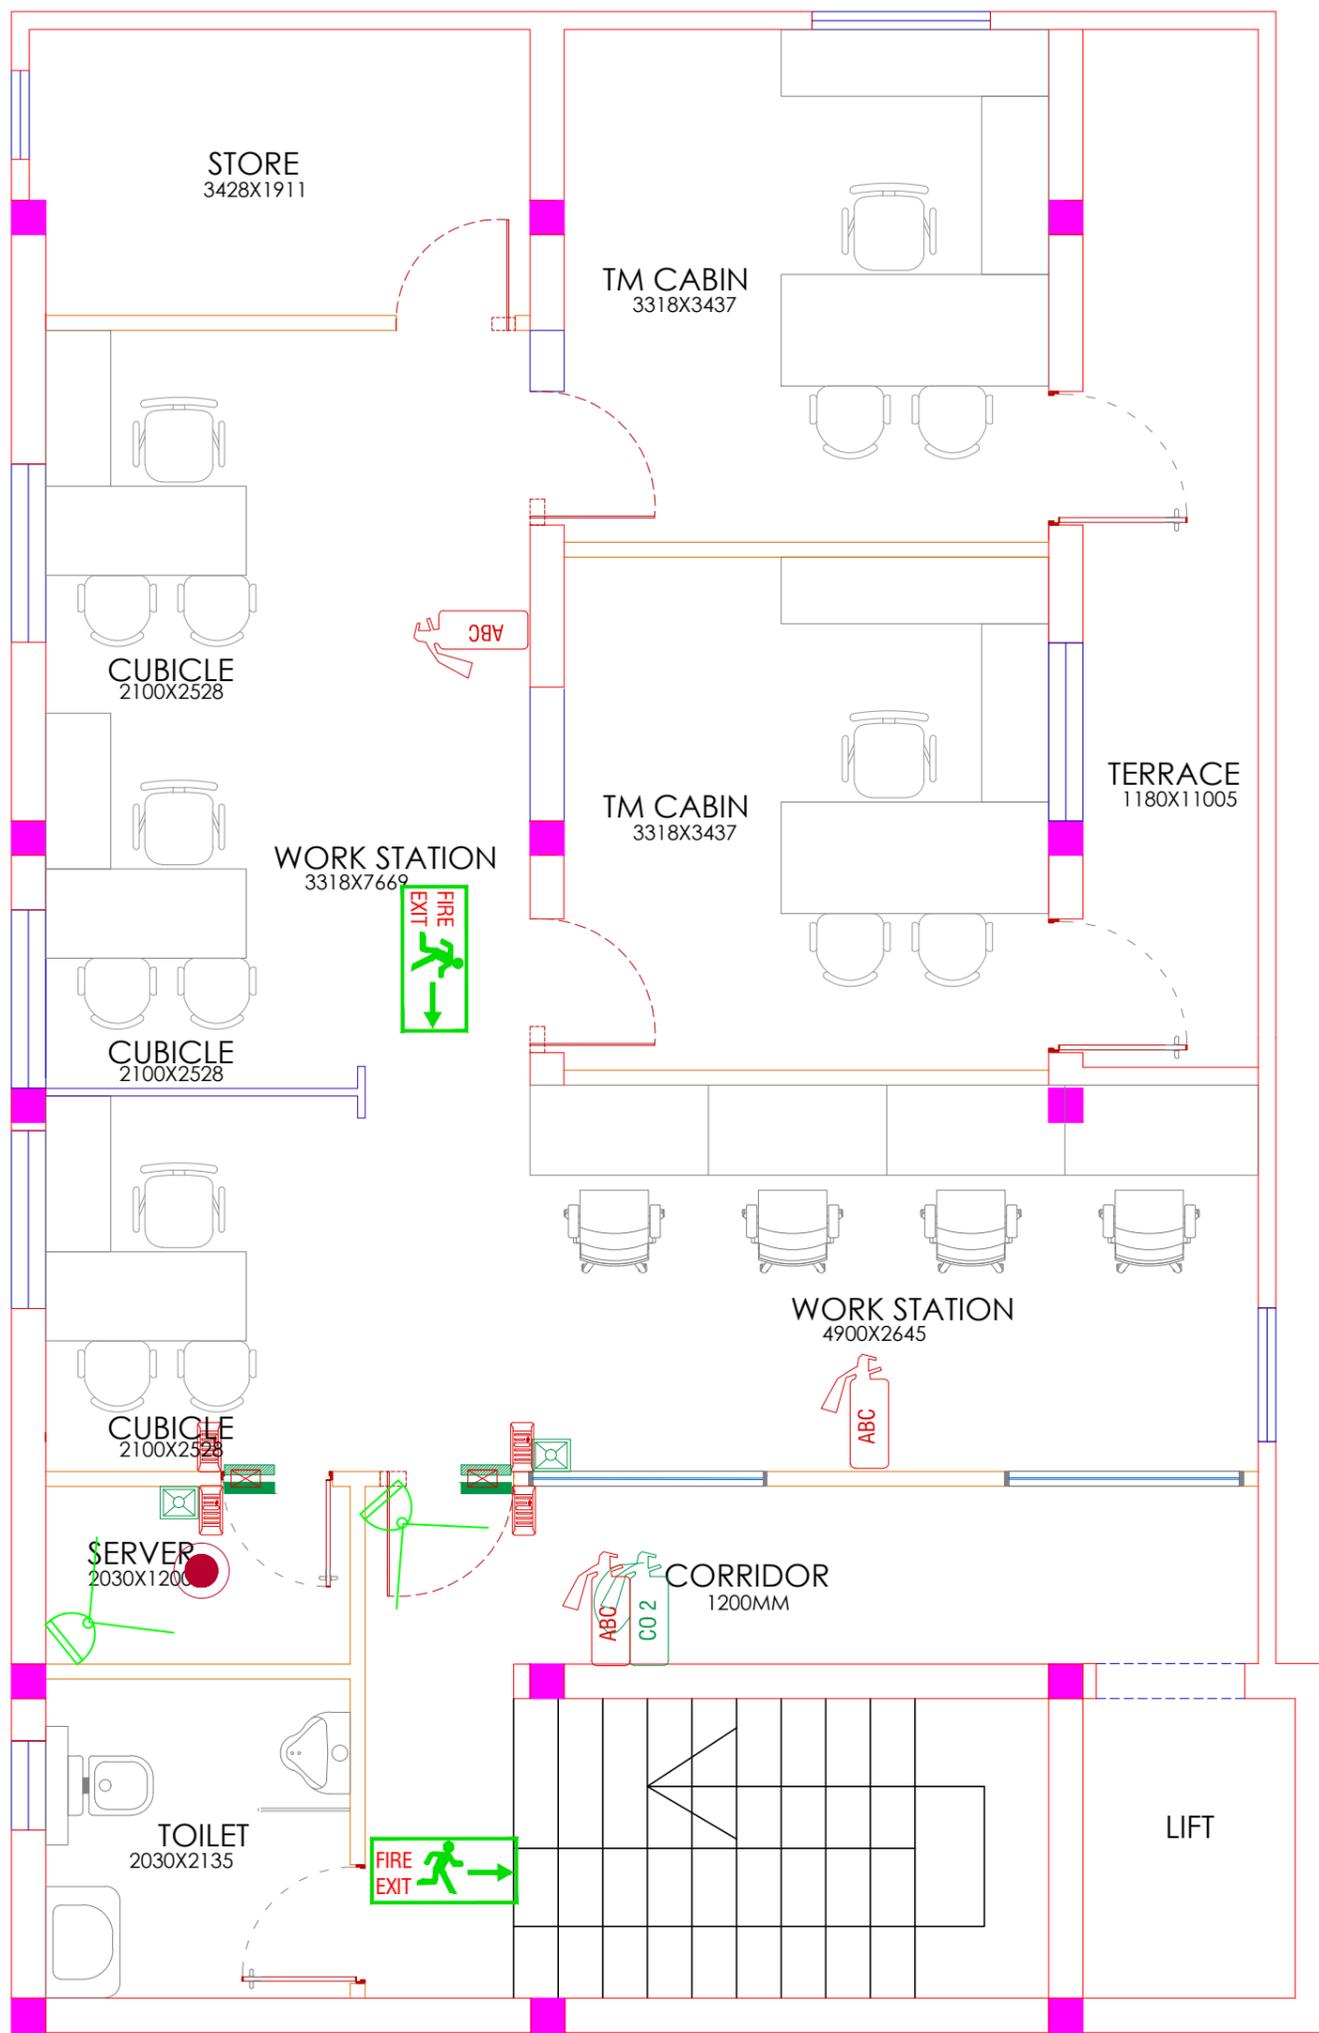


LEGEND

SYMBOL	DESCRIPTION
	ABC TYPE FLOOR MOUNT EXTINGUISHER 5kg
	CO2 TYPE FLOOR MOUNT EXTINGUISHER 4.5kg
	MECHANICAL FOAM TYPE FIRE EXTINGUISHER 10KG
	FIRE EXIT SIGNAGE
	ELECTRO MAGNETIC LOCK
	CARD READER
	EMERGENCY DOOR RELEASE
	DOOR BUZZAR
	NETWORK CAMERA
	CEILING MOUNT FIRE EXTINGUISHER 5KG

FIRST FLOOR

Client	BPCL	Project Title	PROPOSED INTERIORS FOR BPCL TERRITORY OFFICE @ VIJAYAWADA		Drawing Title	SIGNAGE, EXTINGUISHER, CCTV & ACCESS LAYOUT		Dwg No	BPCL_TO_TD-017
GENERAL NOTE: 1. DRAWING TO BE USED ONLY FOR THE PURPOSE RELEASED. 2. DO NOT SCALE THIS DRAWING, ONLY WRITTEN DIMENSIONS TO BE FOLLOWED. 3. ANY DISCREPANCY IN THE DRAWING SHOULD BE IMMEDIATELY BROUGHT TO THE NOTICE OF ARCHITECT.		REV	DESCRIPTION	BY	DATE	Drawn		Architects New Designer Web Pvt Ltd No.185, 2nd Floor, 1st Main road, Nehru nagar, Kandanchavadi, Perungudi, Chennai - 600096 Tel: +91- 044 - 42125111www.designerweb.in	
						Checked			
						Approved			
						Date			
						Issued for			

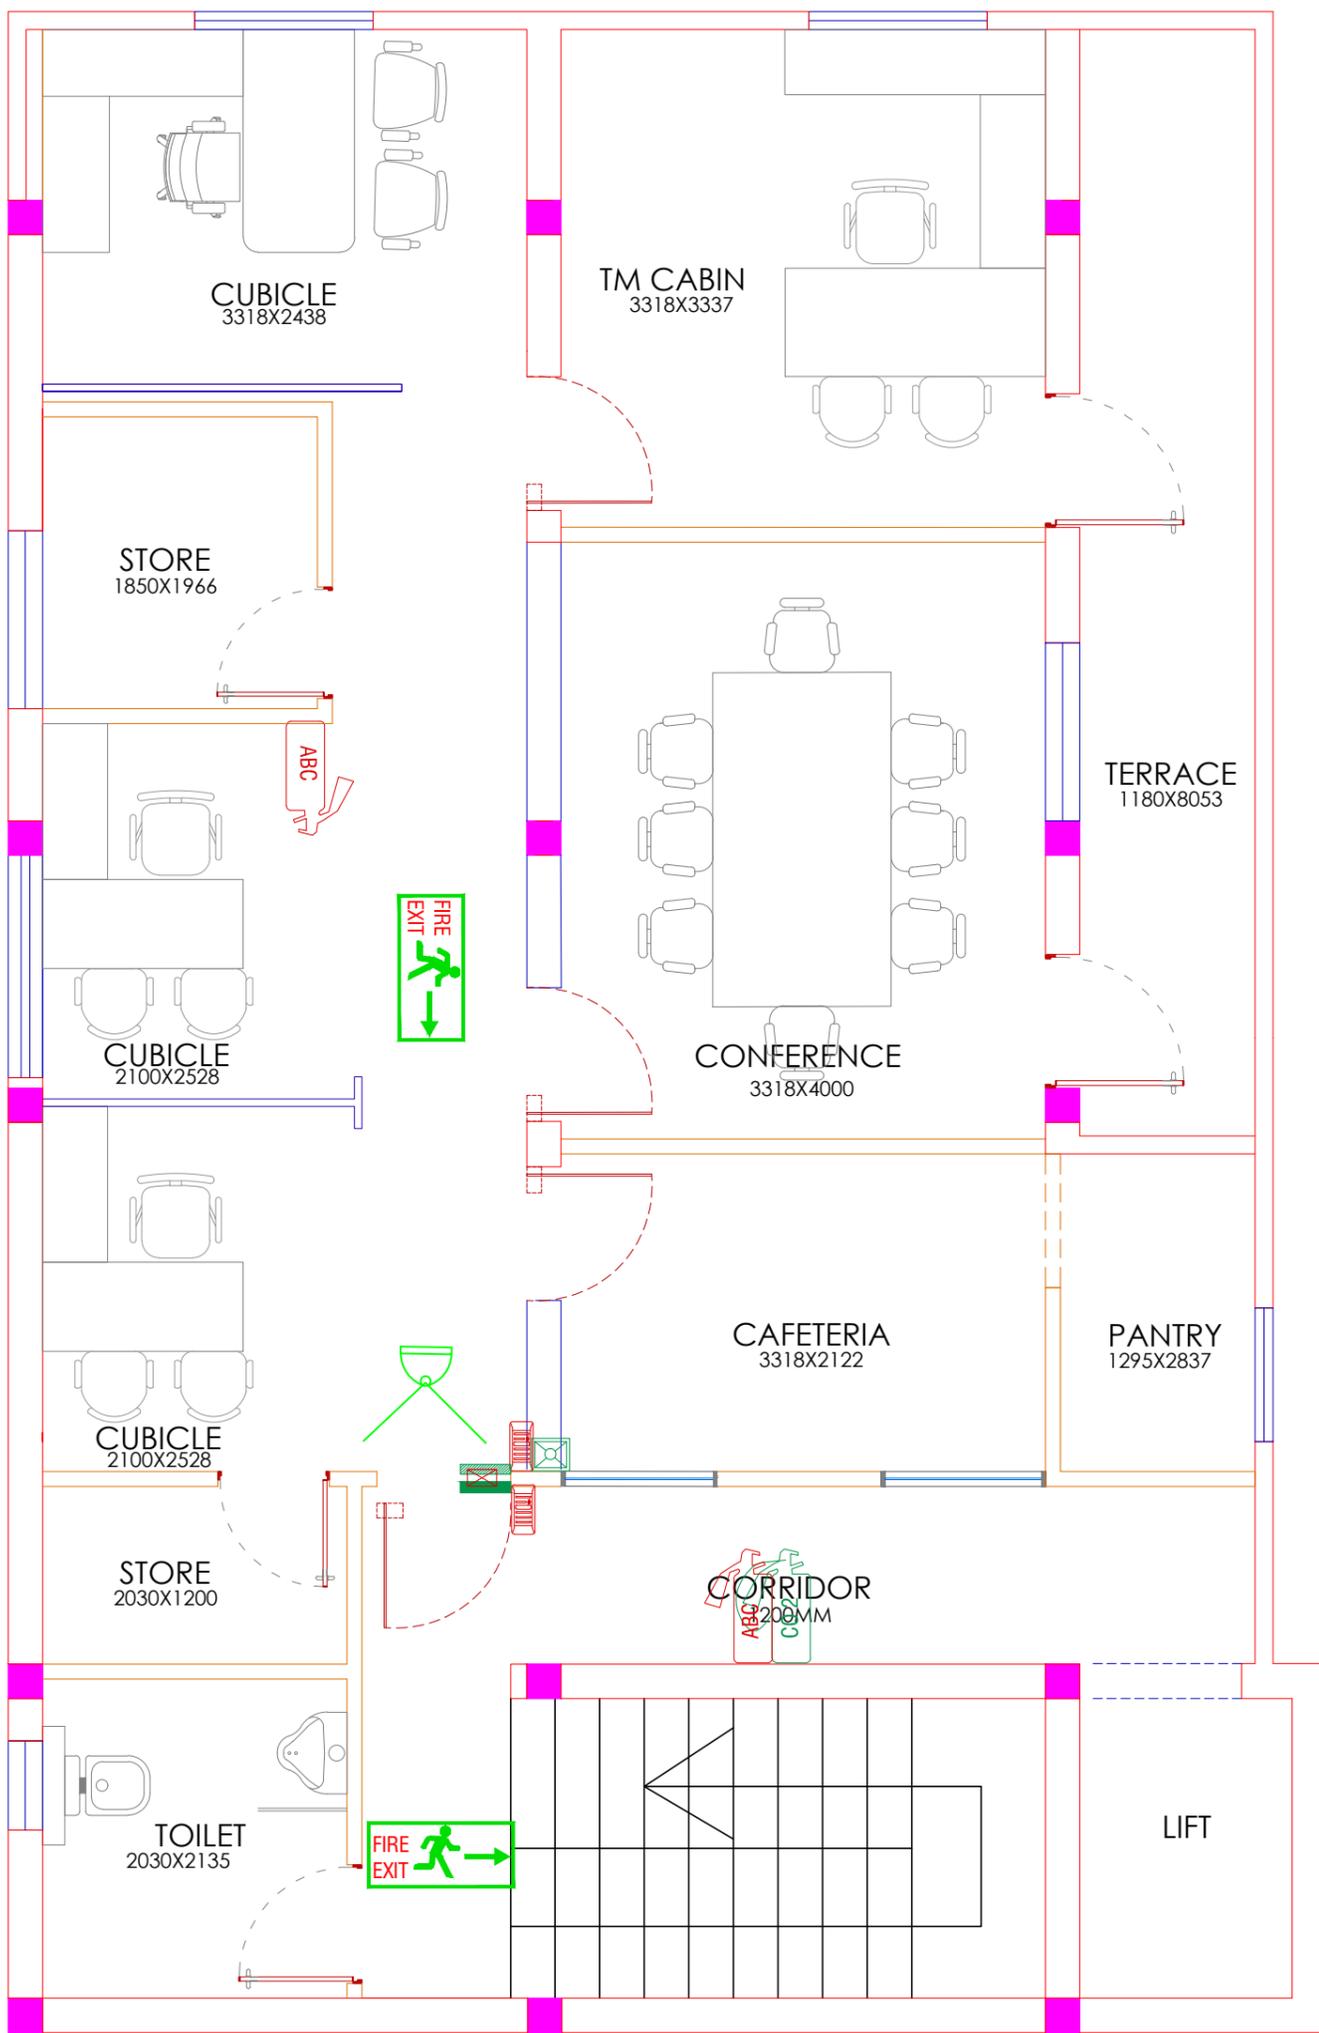


LEGEND


SYMBOL	DESCRIPTION
	ABC TYPE FLOOR MOUNT EXTINGUISHER 5kg
	CO2 TYPE FLOOR MOUNT EXTINGUISHER 4.5kg
	MECHANICAL FOAM TYPE FIRE EXTINGUISHER 10KG
	FIRE EXIT SIGNAGE
	ELECTRO MAGNETIC LOCK
	CARD READER
	EMERGENCY DOOR RELEASE
	DOOR BUZZAR
	NETWORK CAMERA
	CEILING MOUNT FIRE EXTINGUISHER 5KG

SECOND FLOOR


Client	BPCL	Project Title	PROPOSED INTERIORS FOR BPCL TERRITORY OFFICE @ VIJAYAWADA	Drawing Title	SIGNAGE, EXTINGUISHER, CCTV & ACCESS LAYOUT	Dwg No	BPCL_TO_TD-017	
GENERAL NOTE:		REV	DESCRIPTION	BY	DATE	Architects		
1. DRAWING TO BE USED ONLY FOR THE PURPOSE RELEASED.						New Designer Web Pvt Ltd No.185, 2nd Floor, 1st Main road, Nehru nagar, Kandanchavadi, Perungudi, Chennai - 600096 Tel: +91- 044 - 42125111www.designerweb.in		
2. DO NOT SCALE THIS DRAWING, ONLY WRITTEN DIMENSIONS TO BE FOLLOWED.								
3. ANY DISCREPANCY IN THE DRAWING SHOULD BE IMMEDIATELY BROUGHT TO THE NOTICE OF ARCHITECT.								
					Drawn			
					Checked			
					Approved			
					Date			
					Issued for	Scale	SCALE	

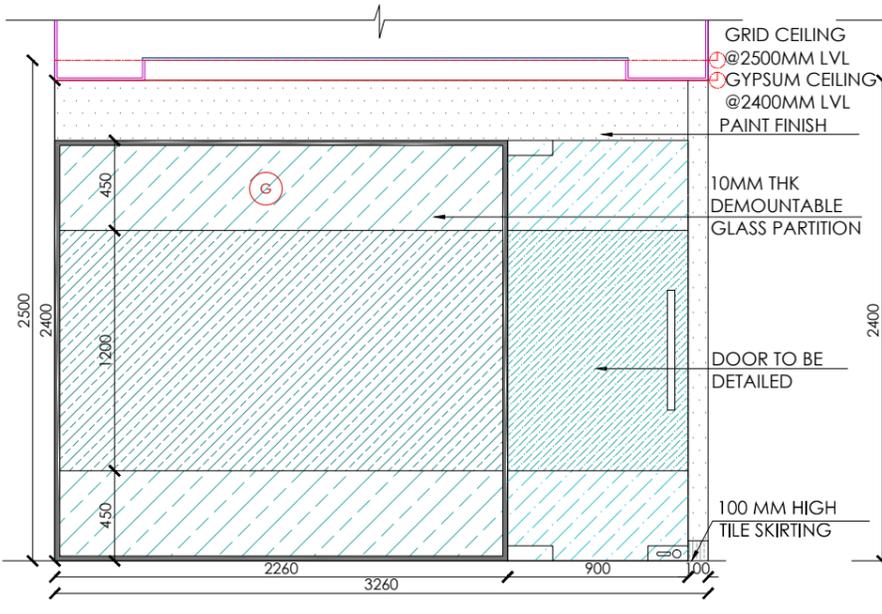


03 ELEVATION - C
EL-001

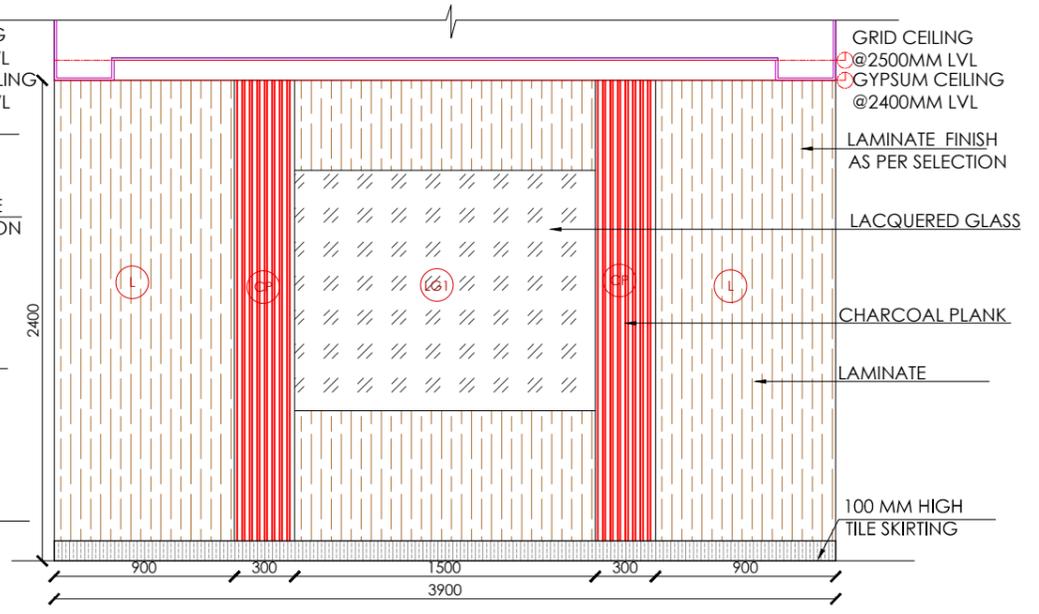


04 ELEVATION - D
EL-001

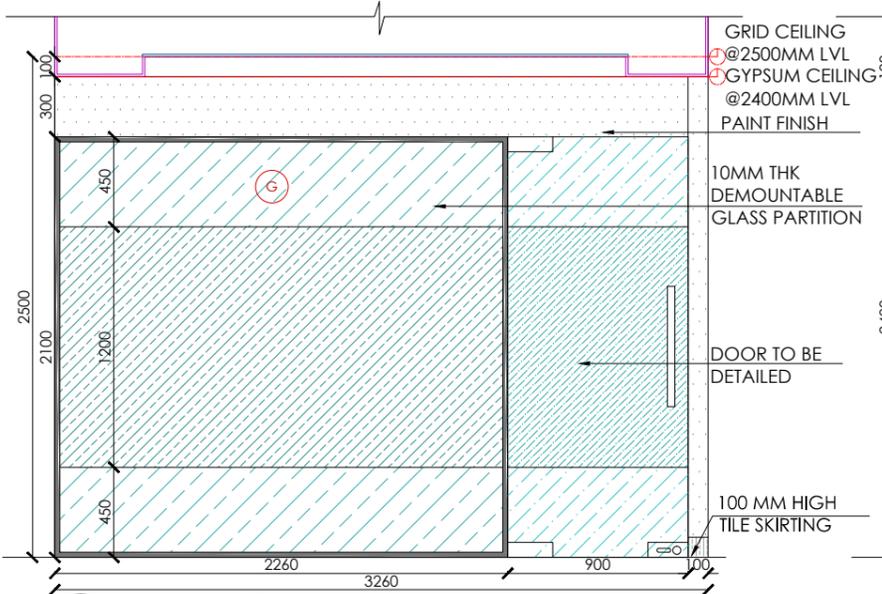


01 ELEVATION - A
EL-001

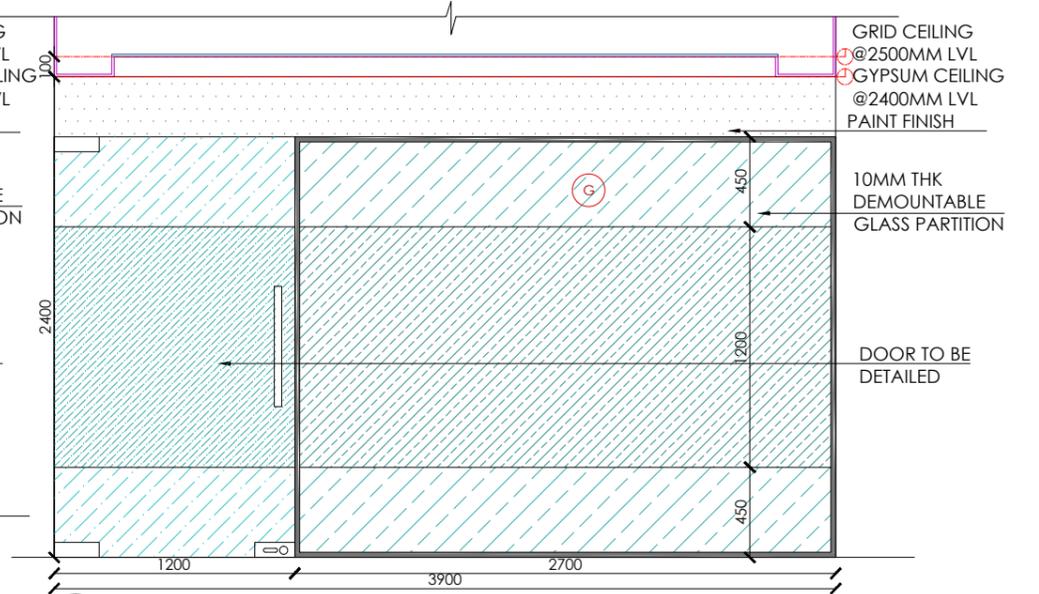

02 ELEVATION - B
EL-001

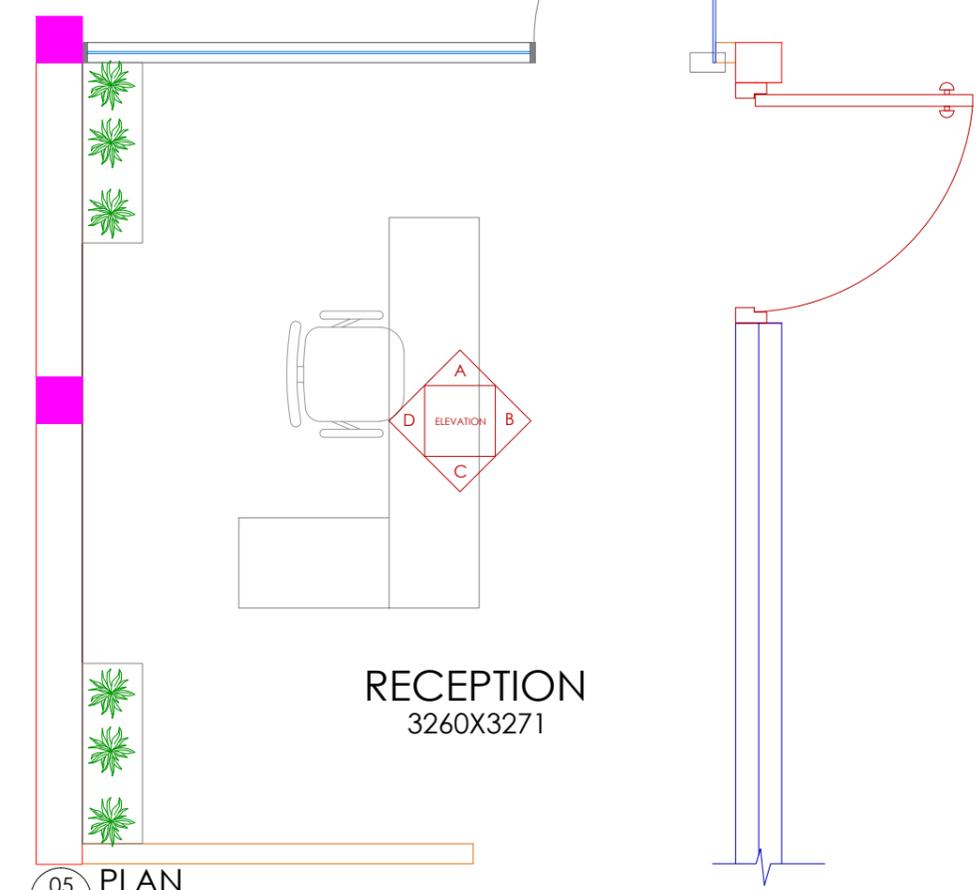


05 PLAN
EL-001

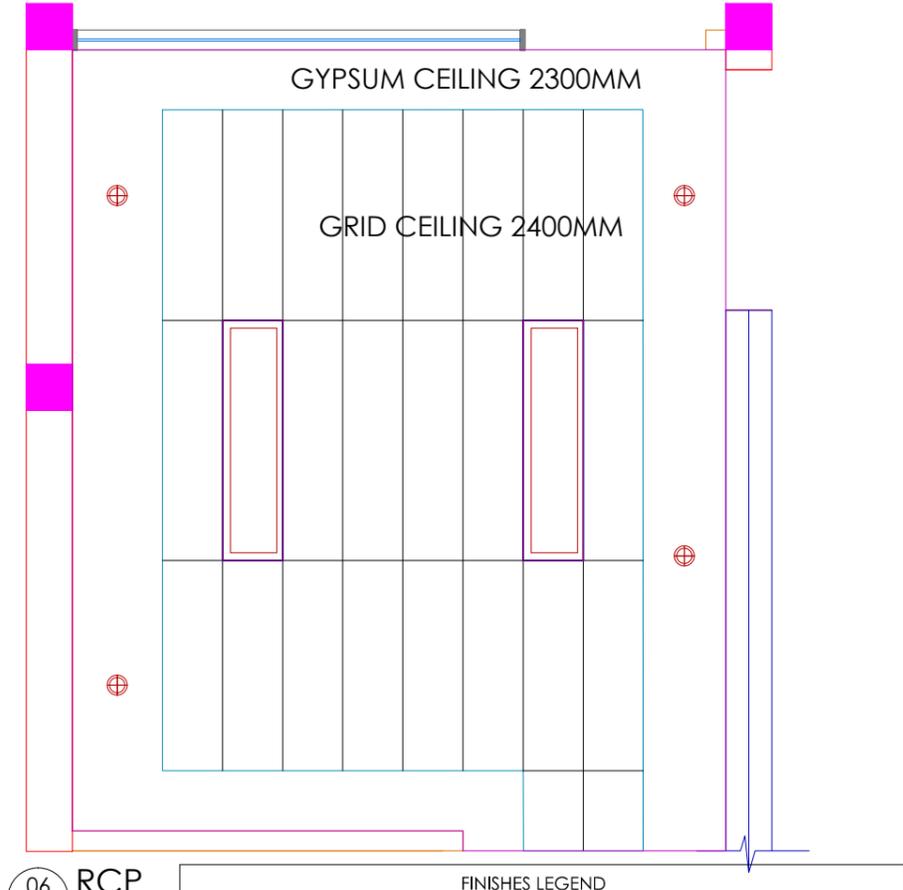


06 RCP
EL-001

FINISHES LEGEND				
HATCH	TAG	FINISH	CODE	MAKE
[Hatch]	P1	PAINT		ASIAN
[Hatch]	CP	CHARCOAL PALNK		EURO PARTIK
[Hatch]	G	GLASS		
[Hatch]	GE	GLASS ETCHING		
[Hatch]	TP	TEXTURE PAINT		ASIAN
[Hatch]	L	LAMINATE		GREENLAM
[Hatch]	GP	WALLPAPER		SAINT GOBAIN


Client	BPCL,VIJAYAWADA	Project Title	PROPOSED OFFICE INTERIOR FOR BPCL ,VIJAYAWADA	Drawing Title	RECEPTION ELEVATION DRAWING	Dwg No	EL_001
GENERAL NOTE: 1. DRAWING TO BE USED ONLY FOR THE PURPOSE RELEASED. 2. DO NOT SCALE THIS DRAWING, ONLY WRITTEN DIMENSIONS TO BE FOLLOWED. 3. ANY DISCREPANCY IN THE DRAWING SHOULD BE IMMEDIATELY BROUGHT TO THE NOTICE OF ARCHITECT.		REV	DESCRIPTION	BY	DATE	 Architects New Designer Web Pvt Ltd No.185, 2nd Floor, 1st Main road, Nehru nagar, Kandanchavadi, Perungudi, Chennai - 600096 Tel: +91- 044 - 42125111www.designerweb.in	
Drawn: GOTHAI Checked: KARTHIKEYAN Approved: VYOM Date: 24.01.2024 Issued for:		Scale: SCALE					

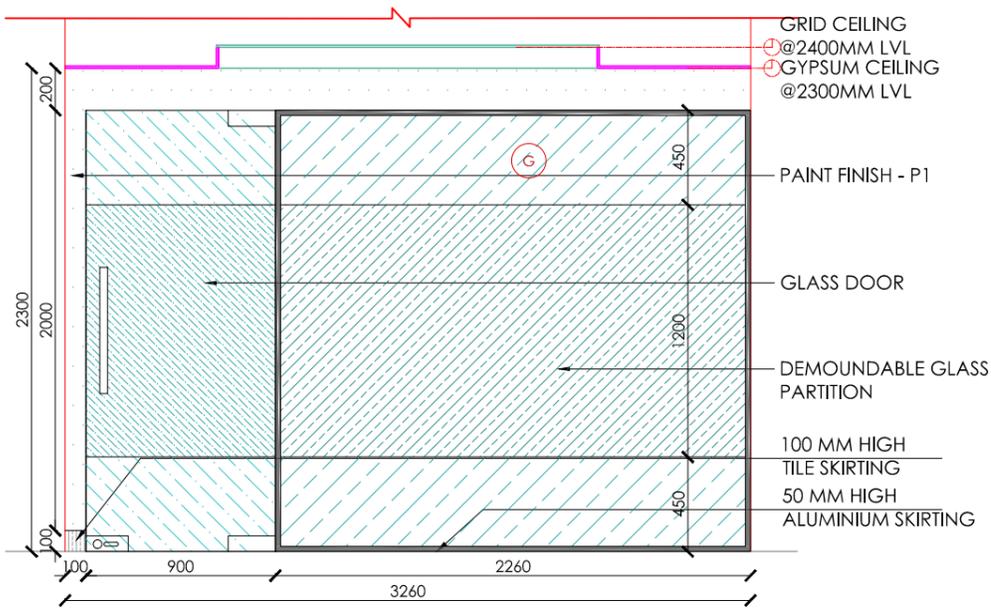


01 ELEVATION - C
EL-002

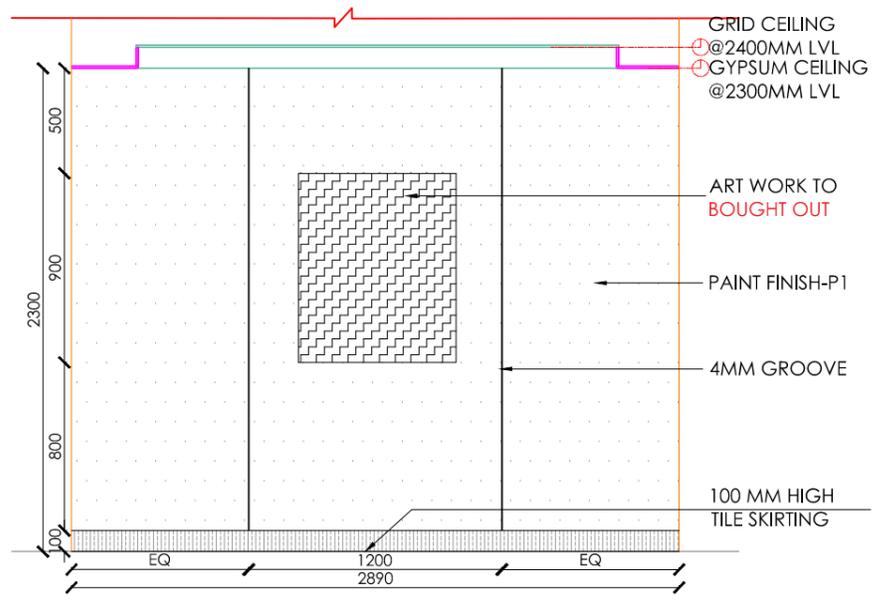

01 ELEVATION - D
EL-002

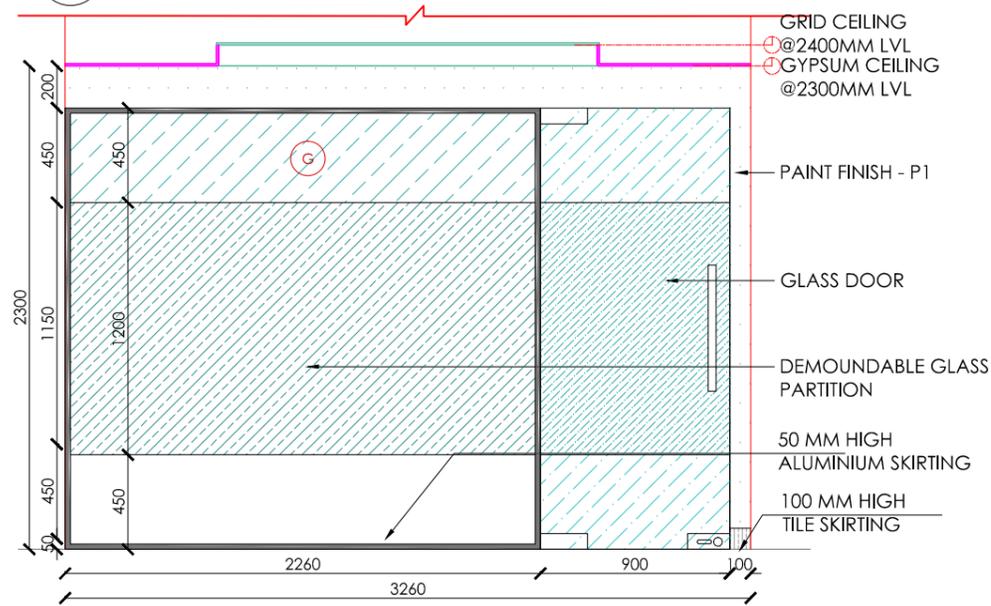


01 ELEVATION - A
EL-002

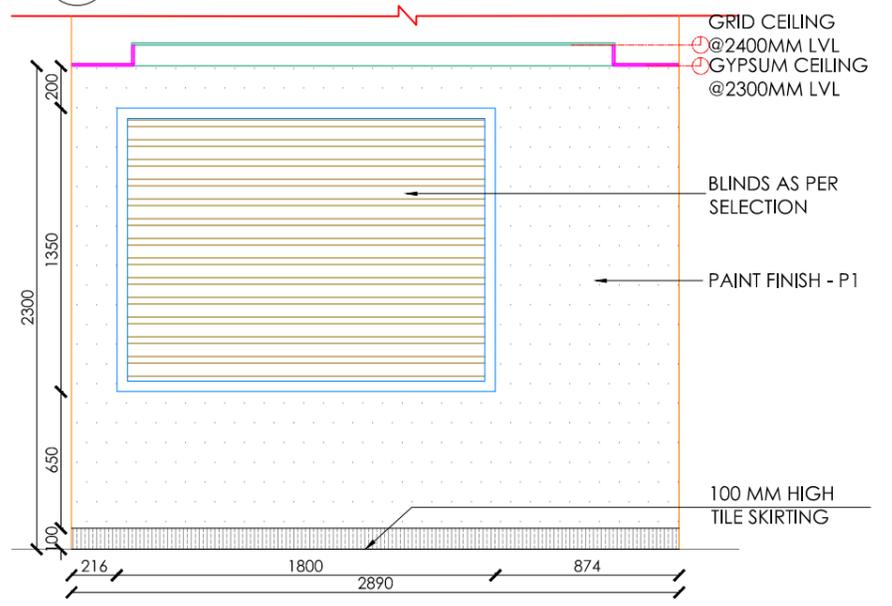

01 ELEVATION - B
EL-002




05 PLAN
EL-002

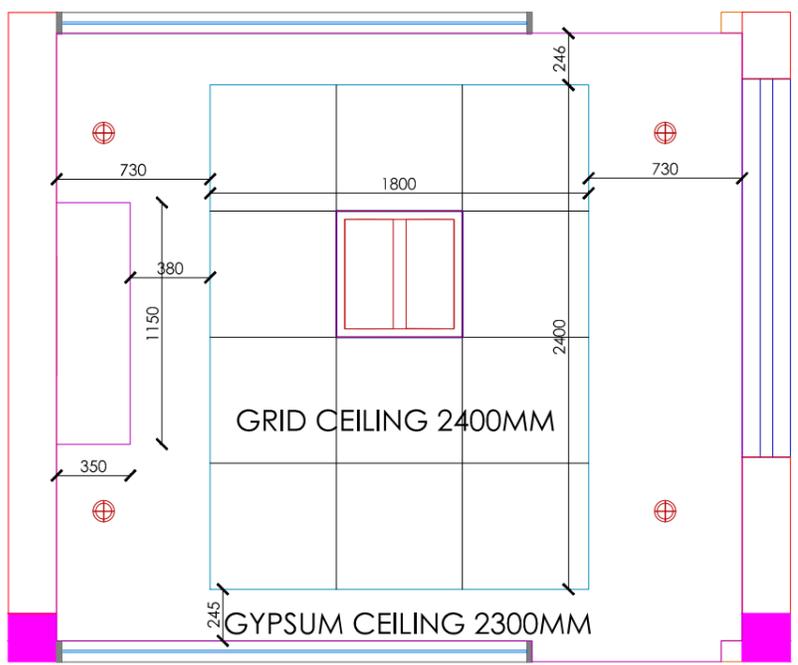


06 RCP
EL-002

FINISHES LEGEND				
HATCH	TAG	FINISH	CODE	MAKE
	P1	PAINT		ASIAN
	TP	TEXTURE PAINT		ASIAN
	G	GLASS		
	GE	GLASS ETCHING		


Client	BPCL,VIJAYAWADA	Project Title	PROPOSED OFFICE INTERIOR FOR BPCL ,VIJAYAWADA	Drawing Title	VISITOR'S LOUNGE ELEVATION DRAWING	Dwg No	EL_002
GENERAL NOTE: 1. DRAWING TO BE USED ONLY FOR THE PURPOSE RELEASED. 2. DO NOT SCALE THIS DRAWING, ONLY WRITTEN DIMENSIONS TO BE FOLLOWED. 3. ANY DISCREPANCY IN THE DRAWING SHOULD BE IMMEDIATELY BROUGHT TO THE NOTICE OF ARCHITECT.	REV	DESCRIPTION	BY	DATE	Drawn	KARTHIK	 Architects New Designer Web Pvt Ltd No.185, 2nd Floor, 1st Main road, Nehru nagar, Kandanchavadi, Perungudi, Chennai - 600096 Tel: +91- 044 - 4212511/www.designerweb.in
					Checked	VYOM	
					Approved	VYOM	
					Date	24.01.2024	
					Issued for	Scale	

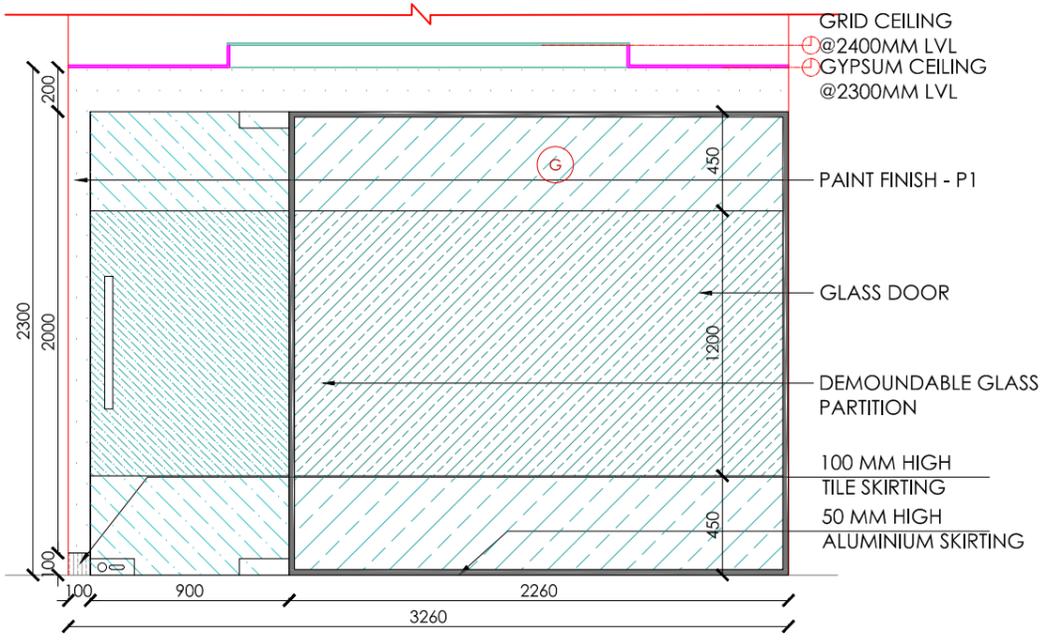


01 ELEVATION - C
EL-003

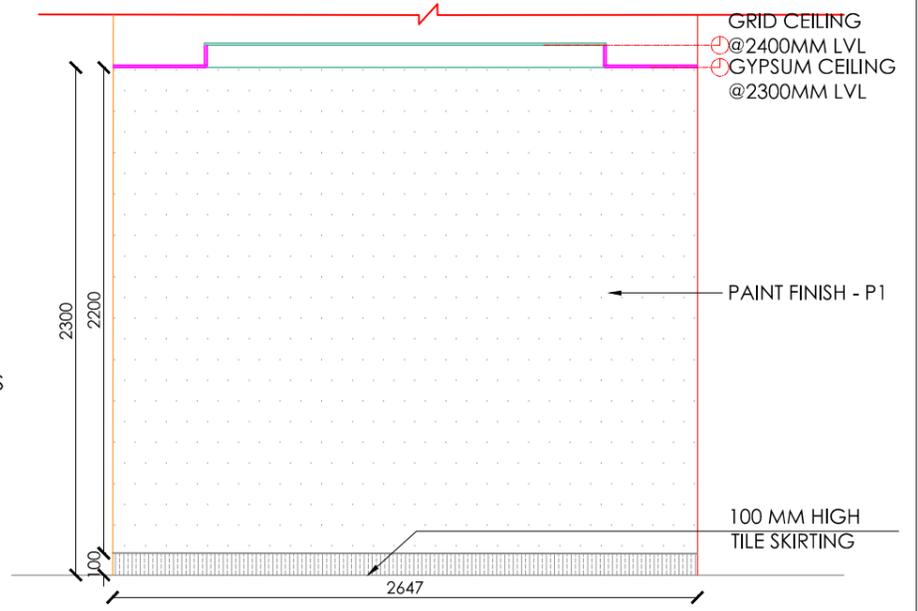


01 ELEVATION - D
EL-003

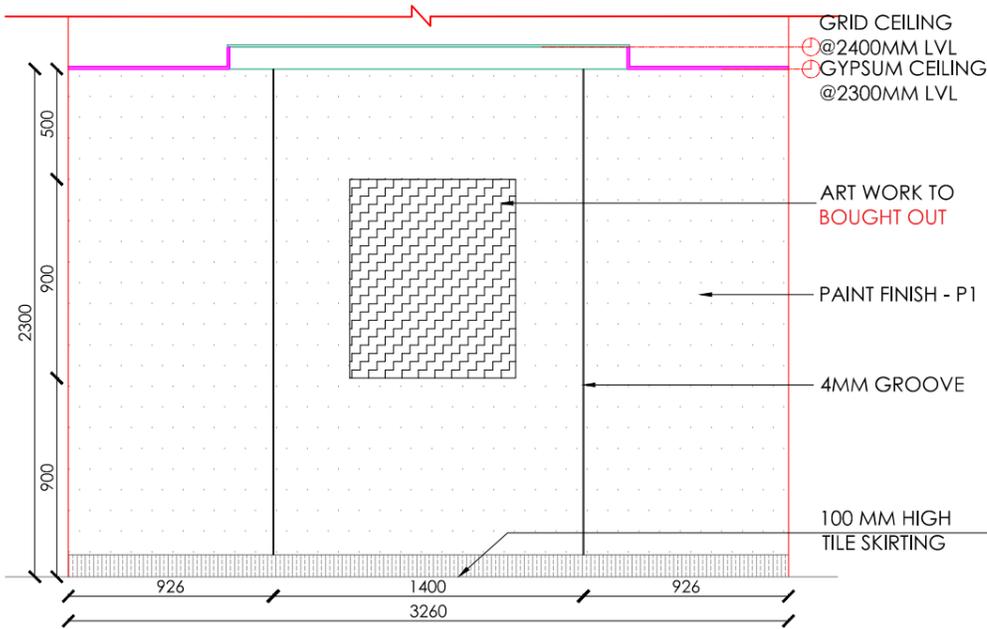


01 ELEVATION - A
EL-003

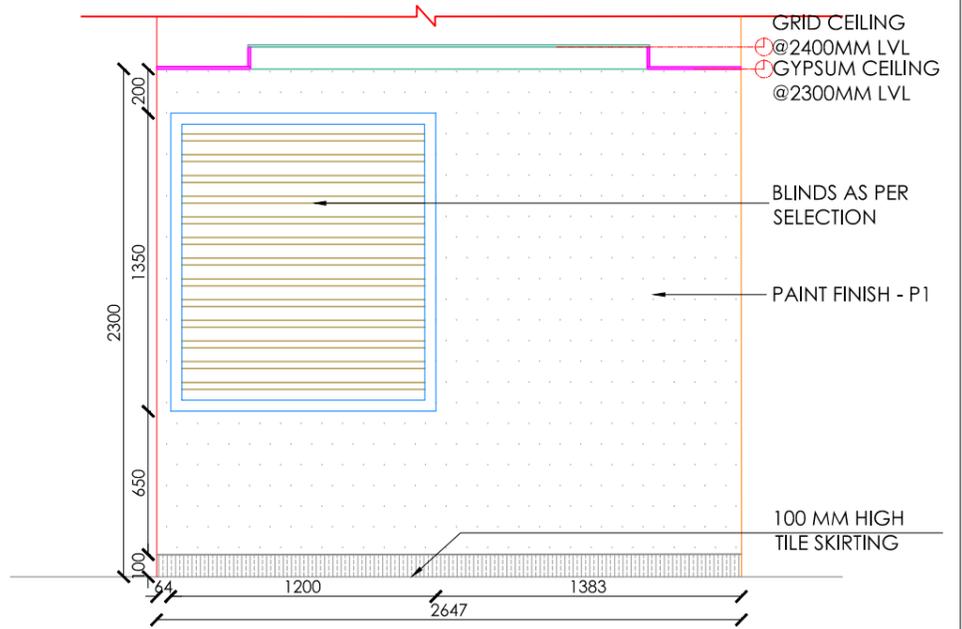

01 ELEVATION - B
EL-003

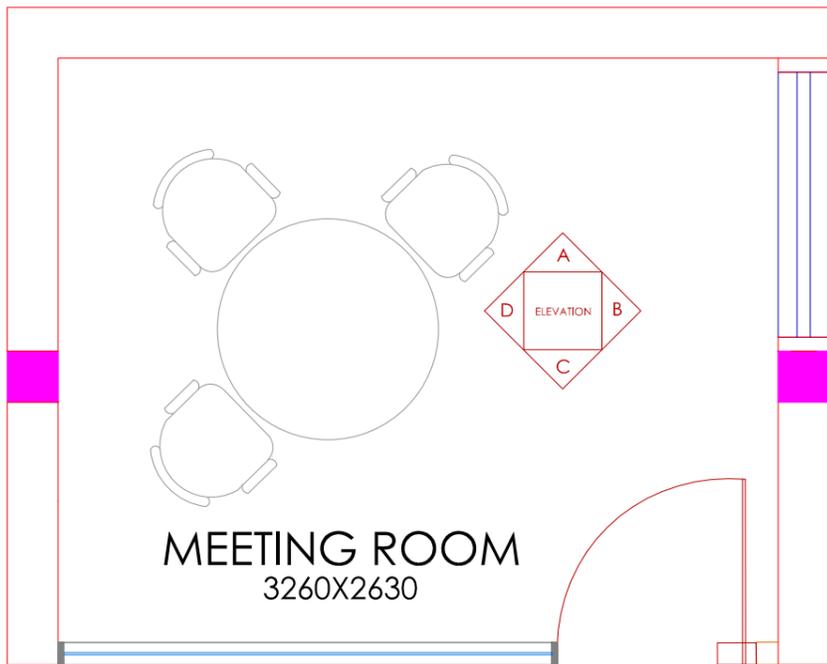



05 PLAN
EL-003

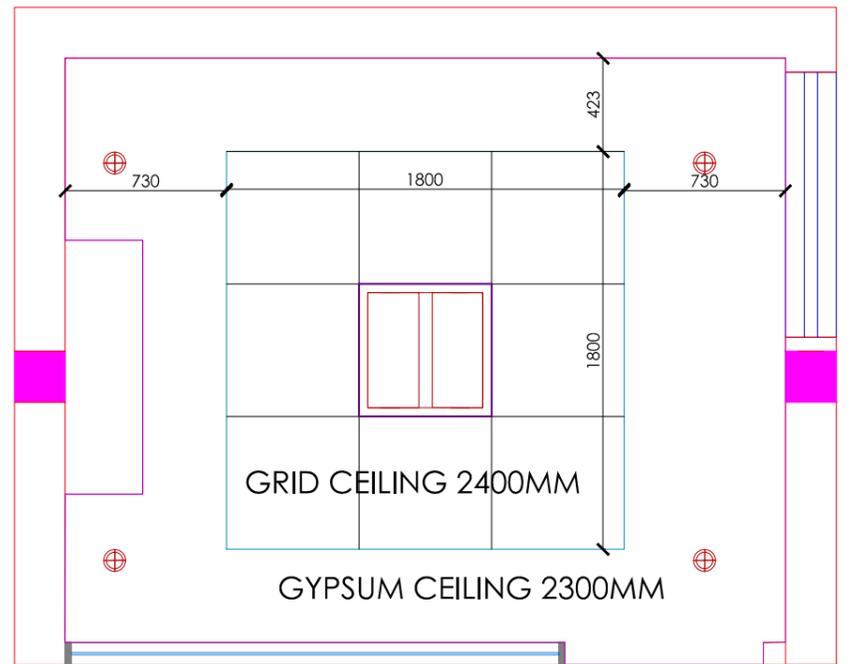

06 RCP
EL-003


FINISHES LEGEND				
HATCH	TAG	FINISH	CODE	MAKE
	P1	PAINT		ASIAN
	TP	TEXTURE PAINT		ASIAN
	G	GLASS		
	GE	GLASS ETCHING		

Client	BPCL,VIJAYAWADA	Project Title	PROPOSED OFFICE INTERIOR FOR BPCL ,VIJAYAWADA	Drawing Title	MEETING ROOM ELEVATION DRAWING	Dwg No	EL_003
GENERAL NOTE: 1. DRAWING TO BE USED ONLY FOR THE PURPOSE RELEASED. 2. DO NOT SCALE THIS DRAWING, ONLY WRITTEN DIMENSIONS TO BE FOLLOWED. 3. ANY DISCREPANCY IN THE DRAWING SHOULD BE IMMEDIATELY BROUGHT TO THE NOTICE OF ARCHITECT.	REV	DESCRIPTION	BY	DATE	Drawn	KARTHIK	 Architects New Designer Web Pvt Ltd No.185, 2nd Floor, 1st Main road, Nehru nagar, Kandanchavadi, Perungudi, Chennai - 600096 Tel: +91- 044 - 4212511www.designerweb.in
					Checked	VYOM	
					Approved	VYOM	
					Date	24.01.2024	
					Issued for	Scale	

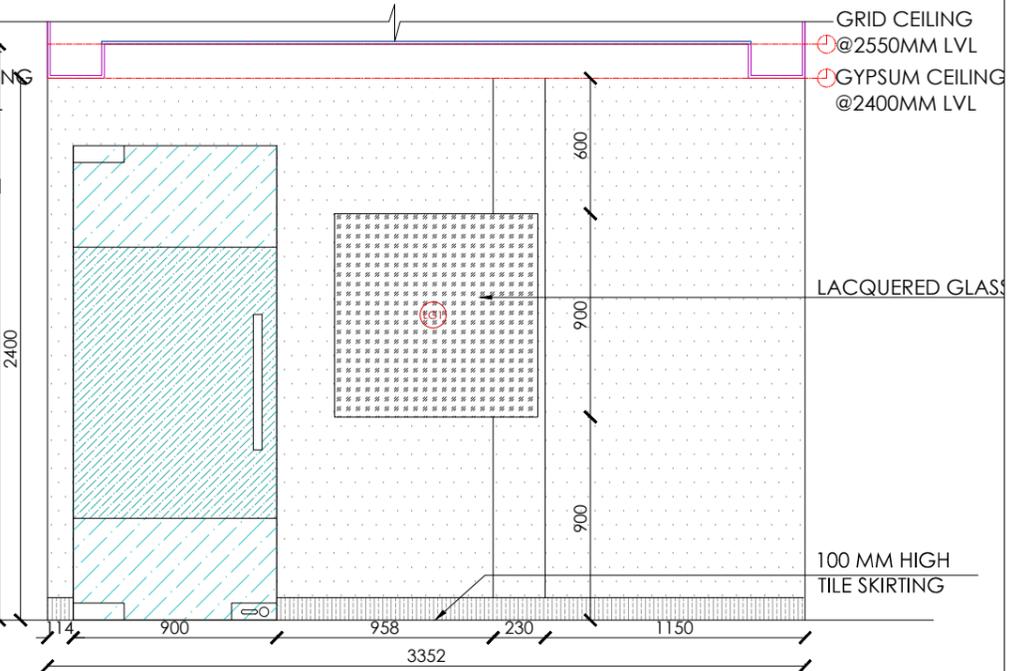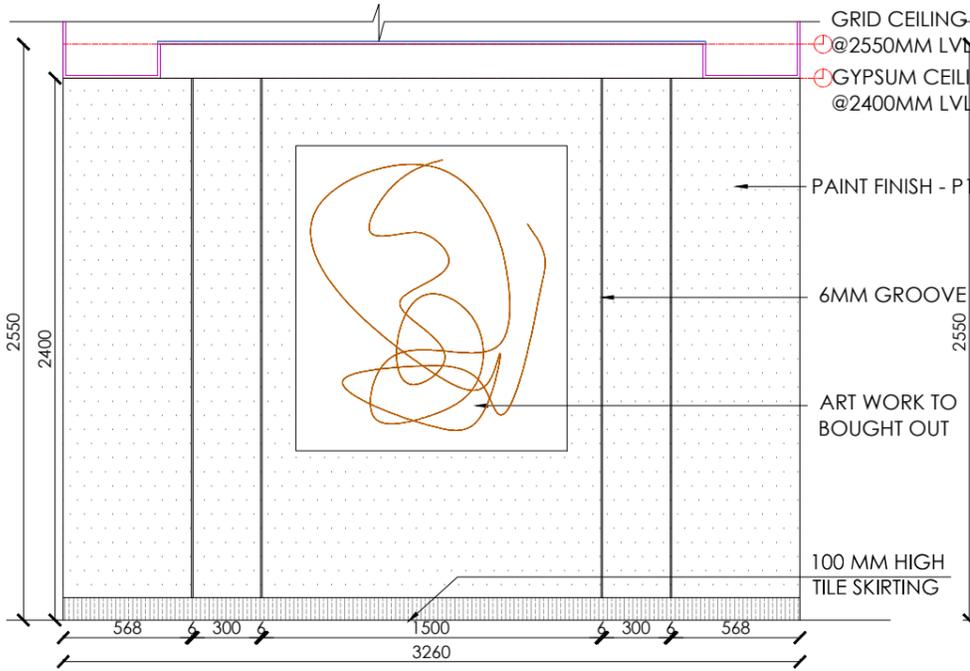


03 ELEVATION - C
EL-005


04 ELEVATION - D
EL-005

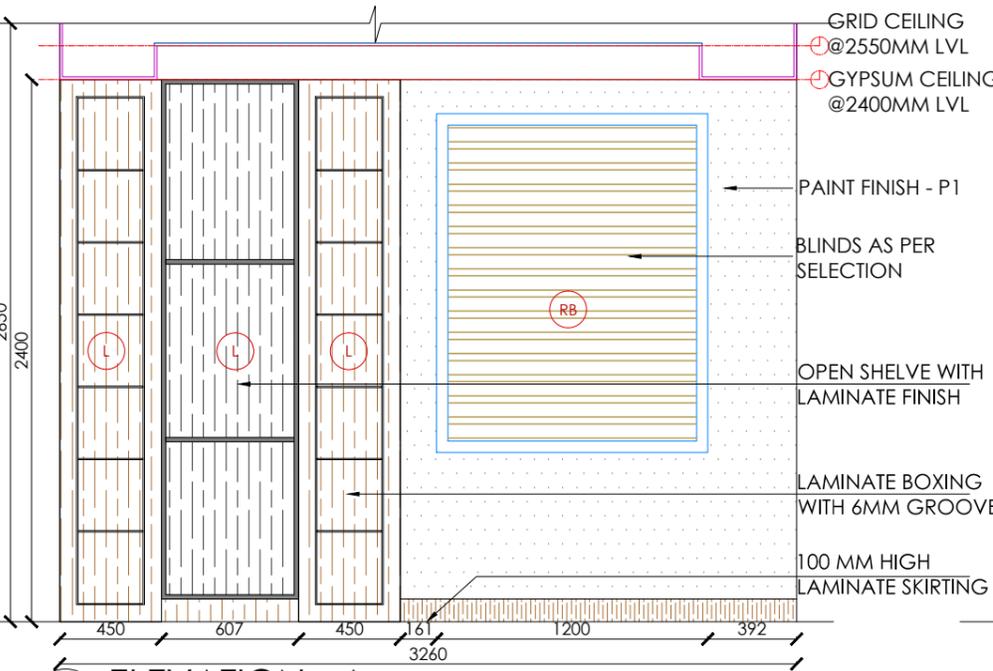


01 ELEVATION - A
EL-005

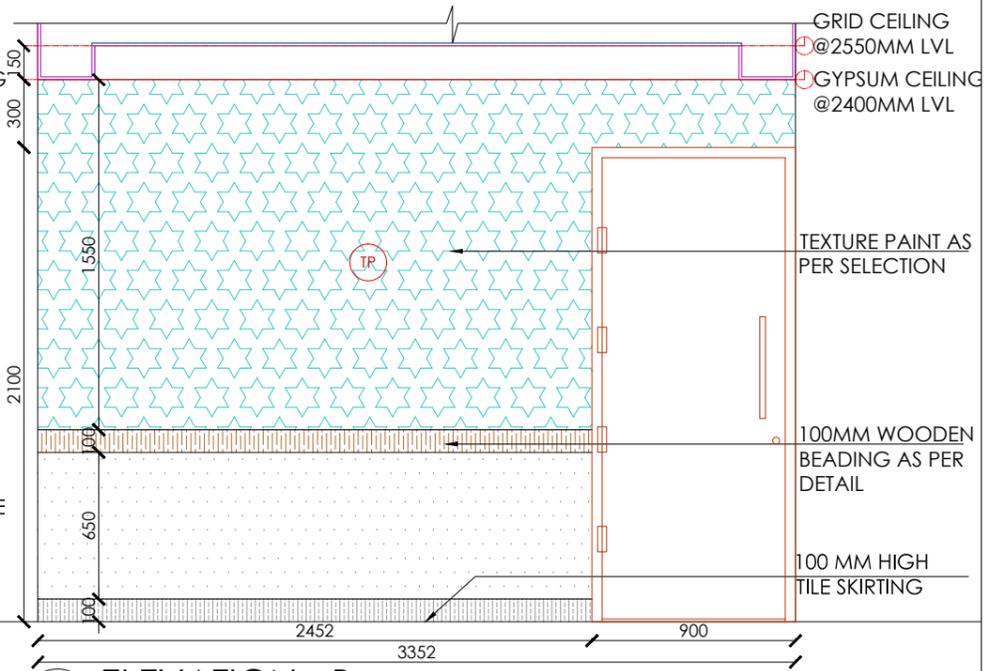

02 ELEVATION - B
EL-005

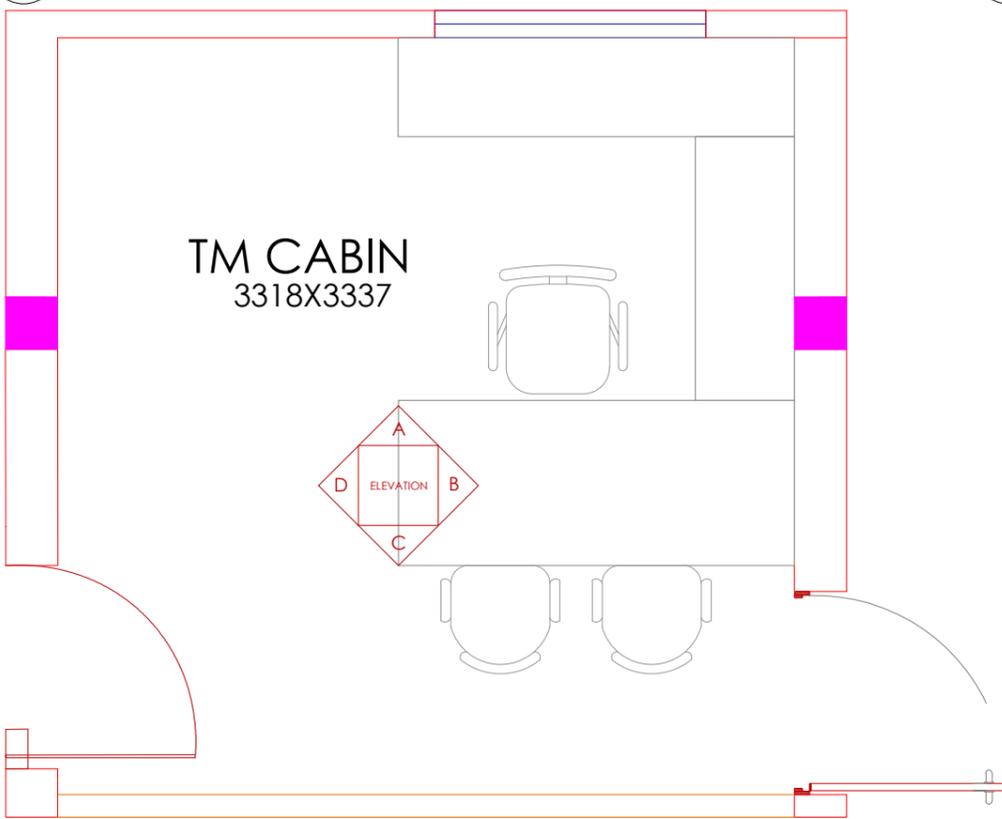


05 PLAN
EL-005

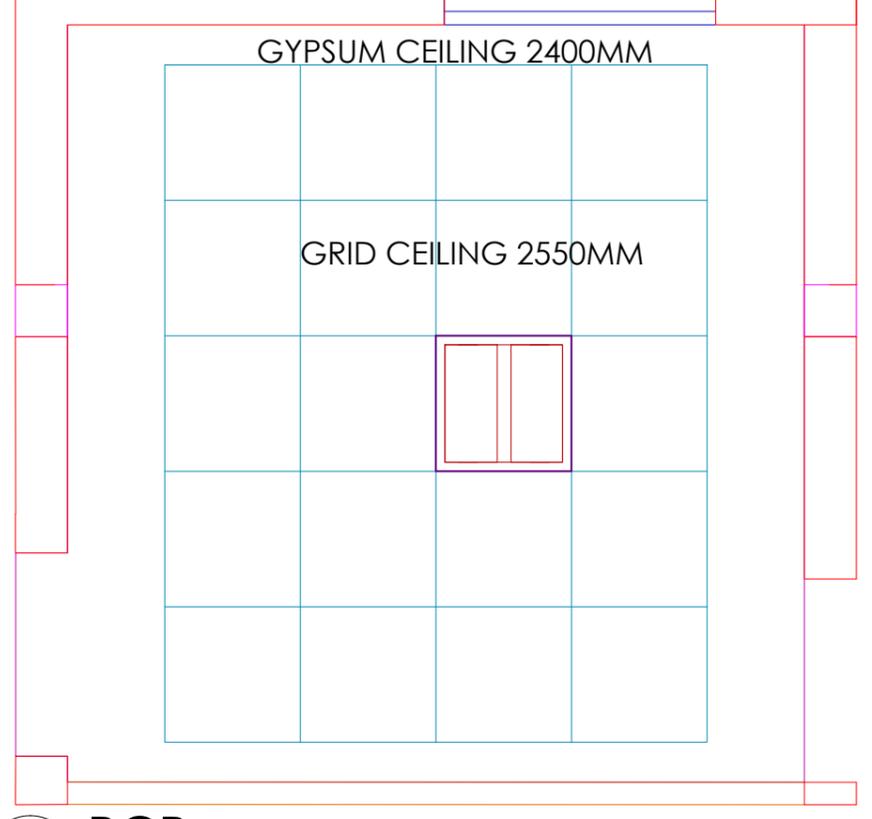

06 RCP
EL-005


FINISHES LEGEND				
HATCH	TAG	FINISH	CODE	MAKE
	(P1)	PAINT		ASIAN
	(TP)	TEXTURE PAINT		ASIAN
	(G)	GLASS		
	(GE)	GLASS ETCHING		

Client	BPCL,VIJAYAWADA	Project Title	PROPOSED OFFICE INTERIOR FOR BPCL ,VIJAYAWADA	Drawing Title	CABIN ELEVATION DRAWING	Dwg No	EL_005
GENERAL NOTE:		REV	DESCRIPTION	BY	DATE	Architects	
1. DRAWING TO BE USED ONLY FOR THE PURPOSE RELEASED.						 New Designer Web Pvt Ltd No.185, 2nd Floor, 1st Main road, Nehru nagar, Kandanchavadi, Perungudi, Chennai - 600096 Tel: +91- 044 - 4212511/www.designerweb.in	
2. DO NOT SCALE THIS DRAWING, ONLY WRITTEN DIMENSIONS TO BE FOLLOWED.							
3. ANY DISCREPANCY IN THE DRAWING SHOULD BE IMMEDIATELY BROUGHT TO THE NOTICE OF ARCHITECT.							
		Drawn		GOTHAJ		Scale	
		Checked		KARTHIK		SCALE	
		Approved		VYOM			
		Date		24.01.2024			
		Issued for					

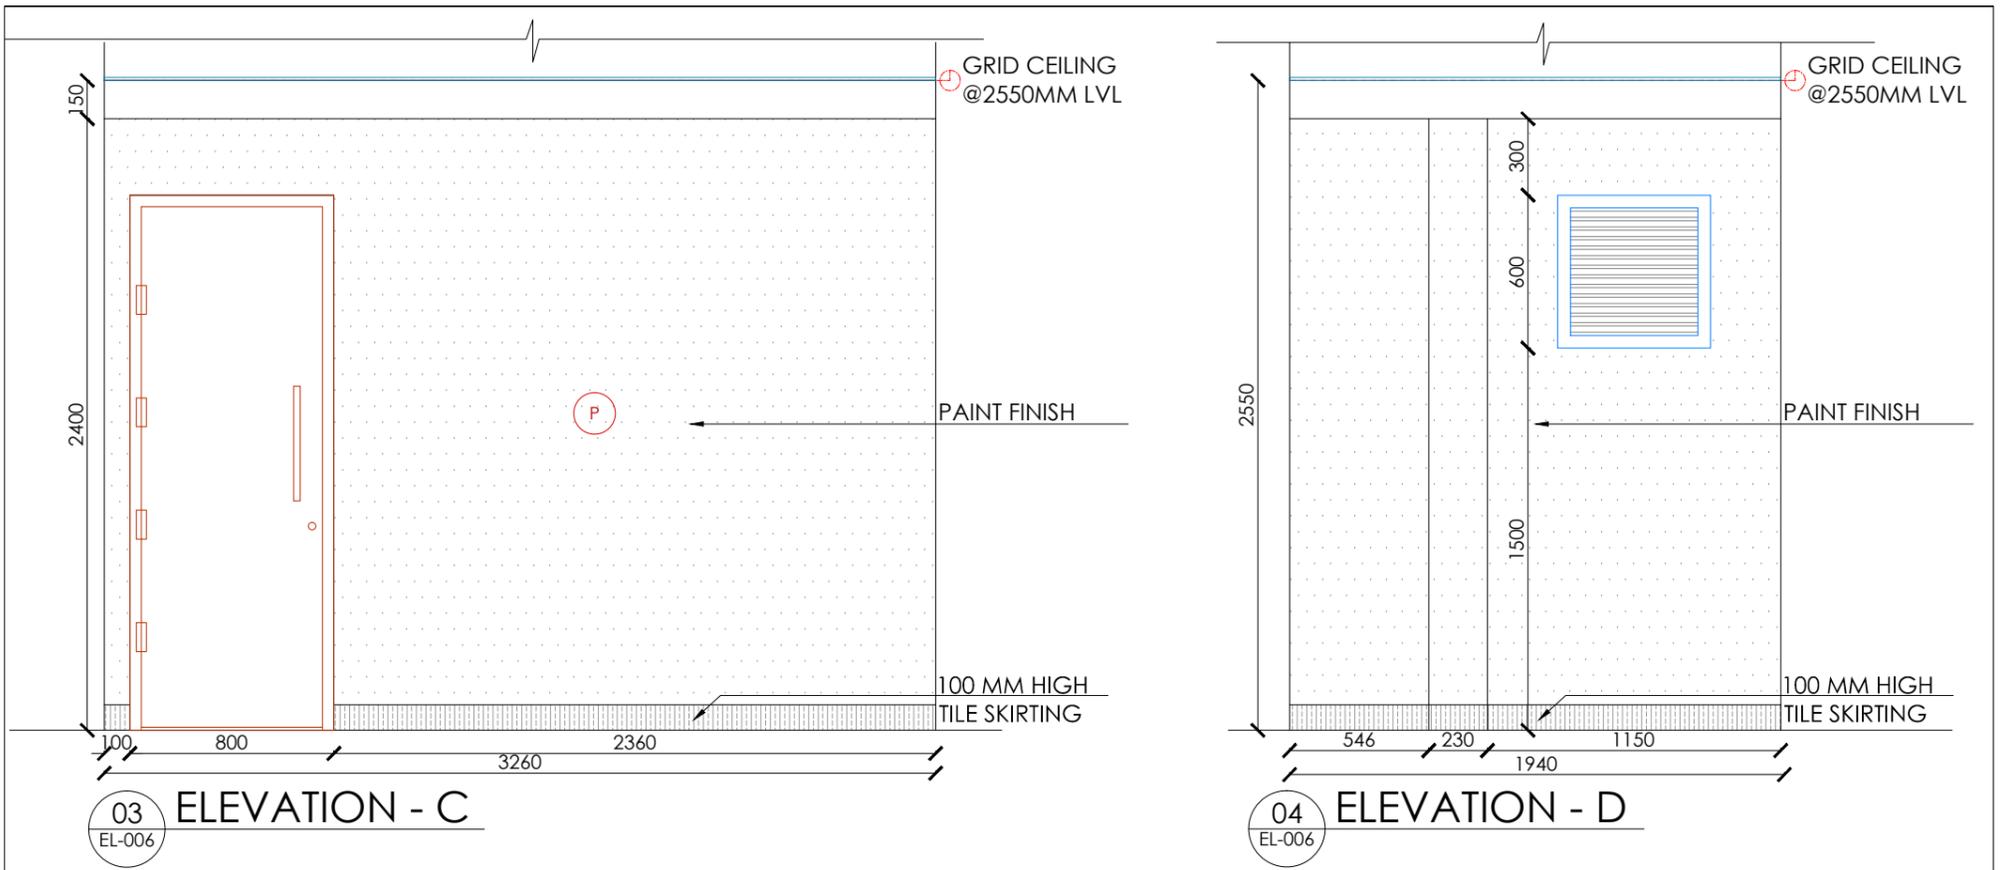


03 ELEVATION - C
EL-006

04 ELEVATION - D
EL-006

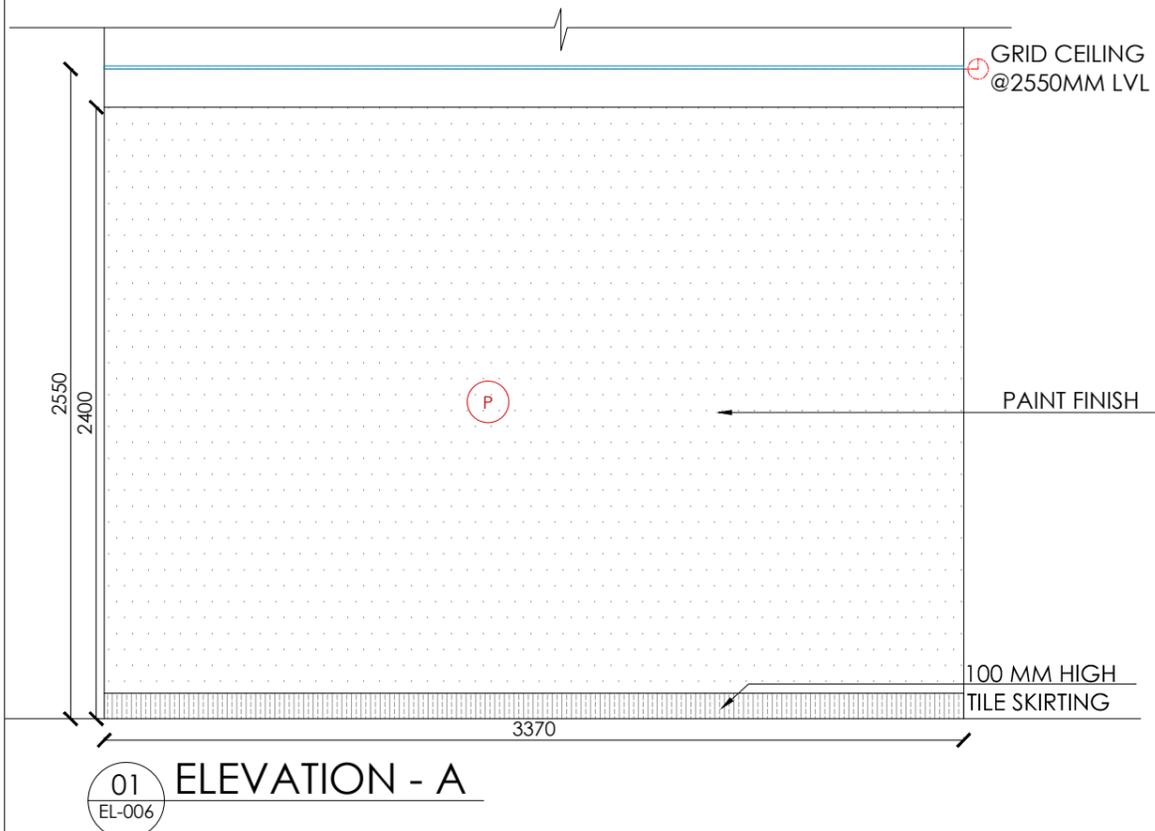


01 ELEVATION - A
EL-006

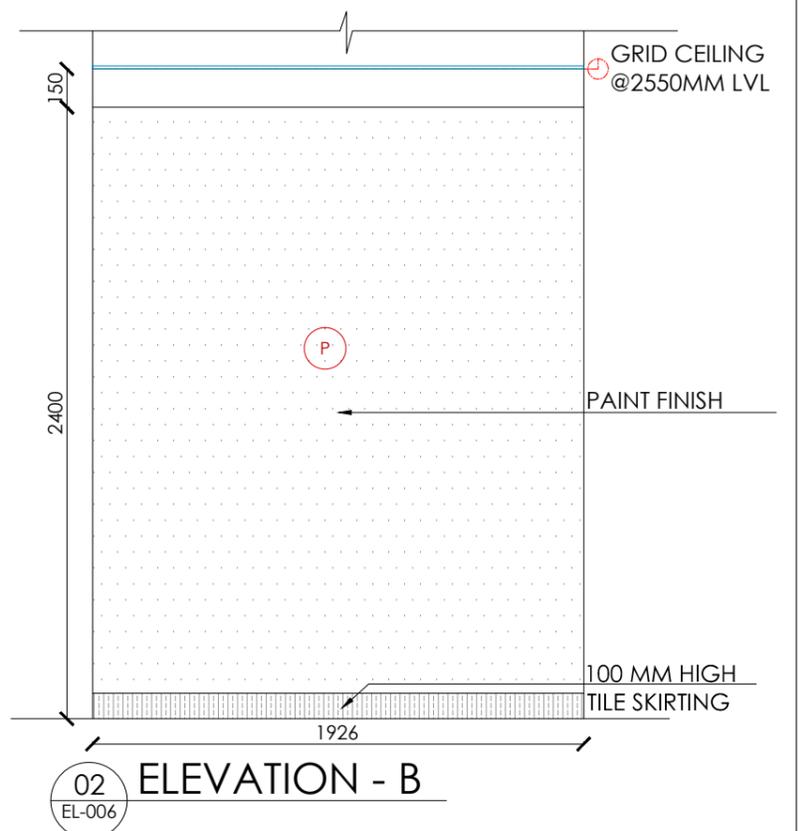

02 ELEVATION - B
EL-006








05 PLAN
EL-006

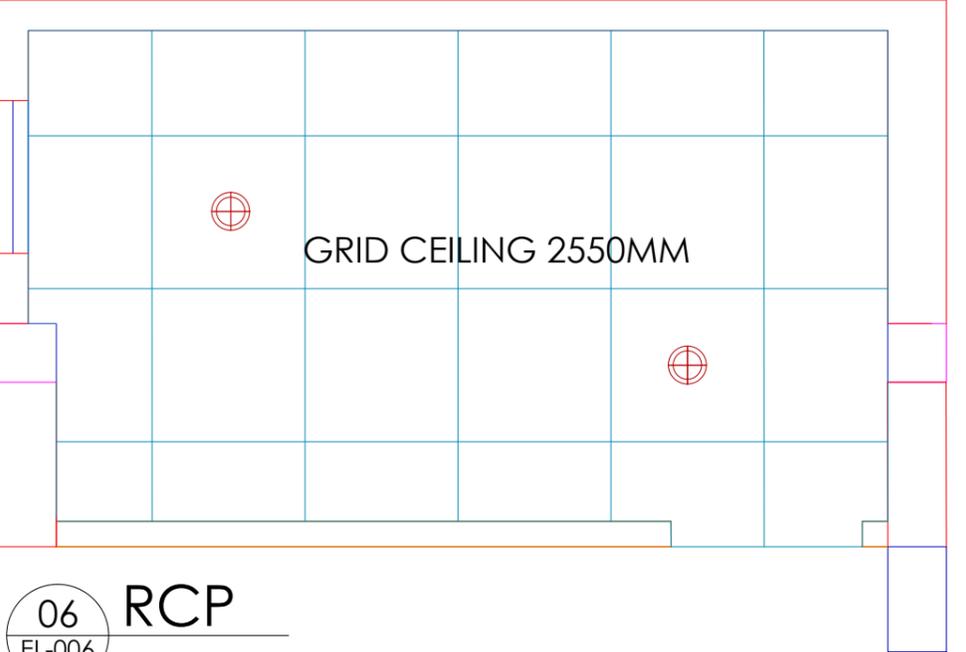

06 RCP
EL-006


FINISHES LEGEND				
HATCH	TAG	FINISH	CODE	MAKE
	P1	PAINT		ASIAN

Client	BPCL,VIJAYAWADA	Project Title	PROPOSED OFFICE INTERIOR FOR BPCL ,VIJAYAWADA	Drawing Title	STORE ROOM- FS ELEVATION DRAWING	Dwg No	EL_006
GENERAL NOTE: 1. DRAWING TO BE USED ONLY FOR THE PURPOSE RELEASED. 2. DO NOT SCALE THIS DRAWING, ONLY WRITTEN DIMENSIONS TO BE FOLLOWED. 3. ANY DISCREPANCY IN THE DRAWING SHOULD BE IMMEDIATELY BROUGHT TO THE NOTICE OF ARCHITECT.		REV	DESCRIPTION	BY	DATE	Architects	
							New Designer Web Pvt Ltd No.185, 2nd Floor, 1st Main road, Nehru nagar, Kandanchavadi, Perungudi, Chennai - 600096 Tel: +91- 044 - 4212511www.designerweb.in
		Drawn	GOTHAJ				
		Checked	KARTHIK				
		Approved	VYOM				
		Date	24.01.2024	Issued for	Scale	SCALE	

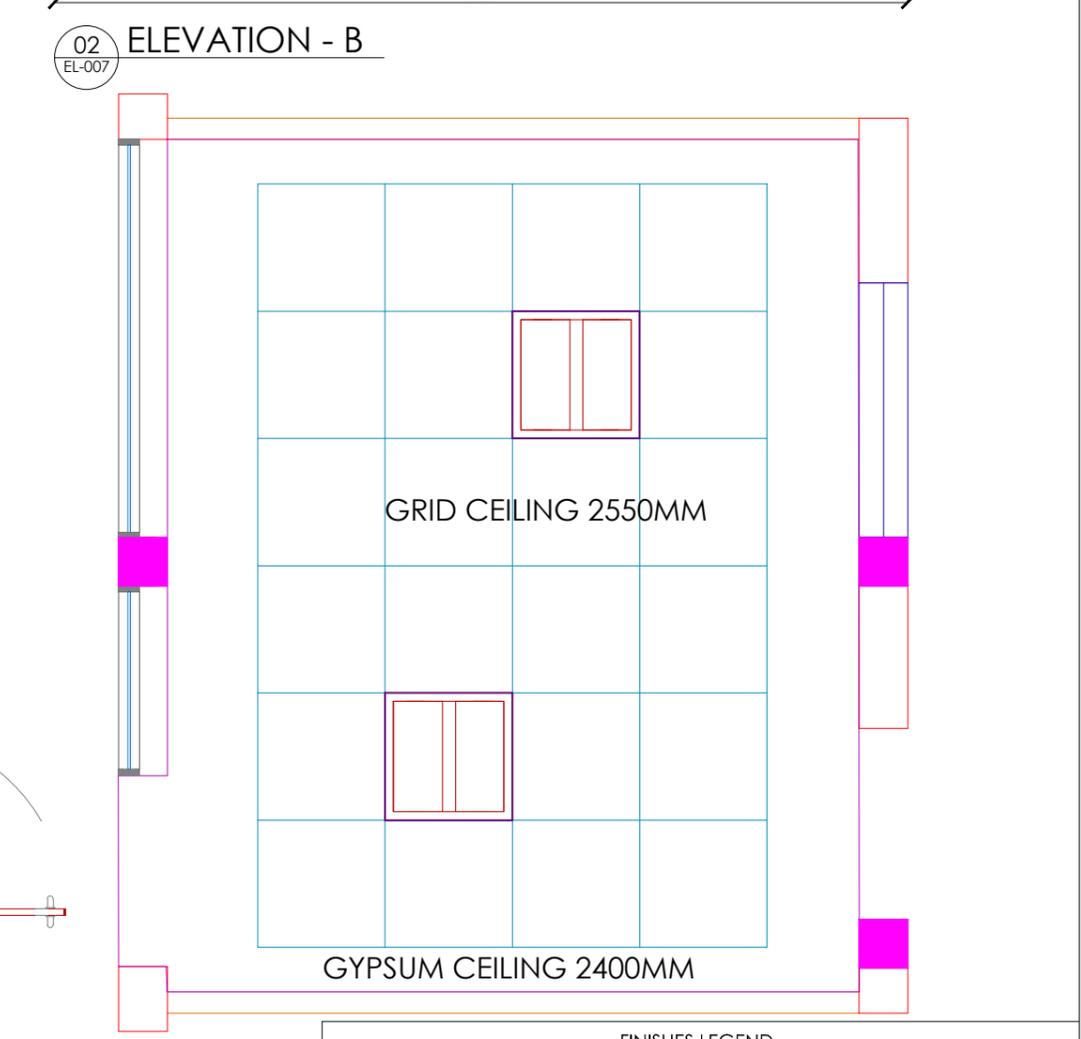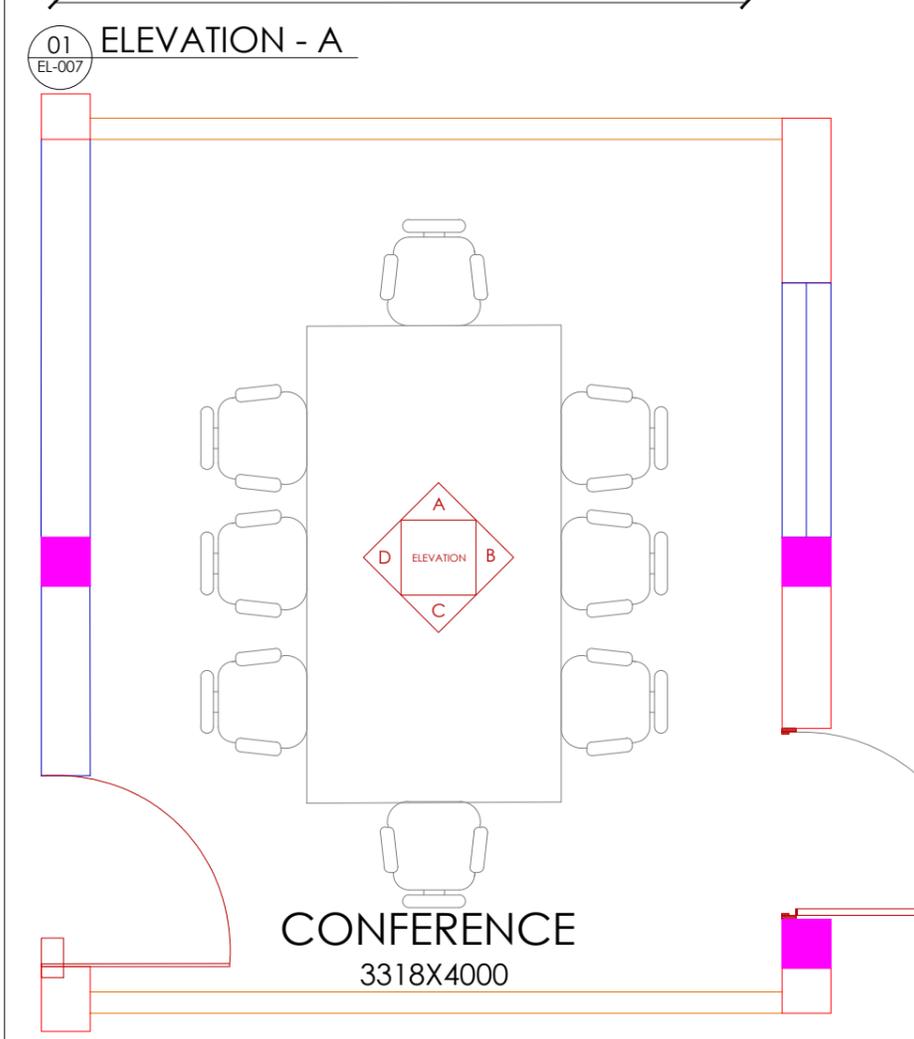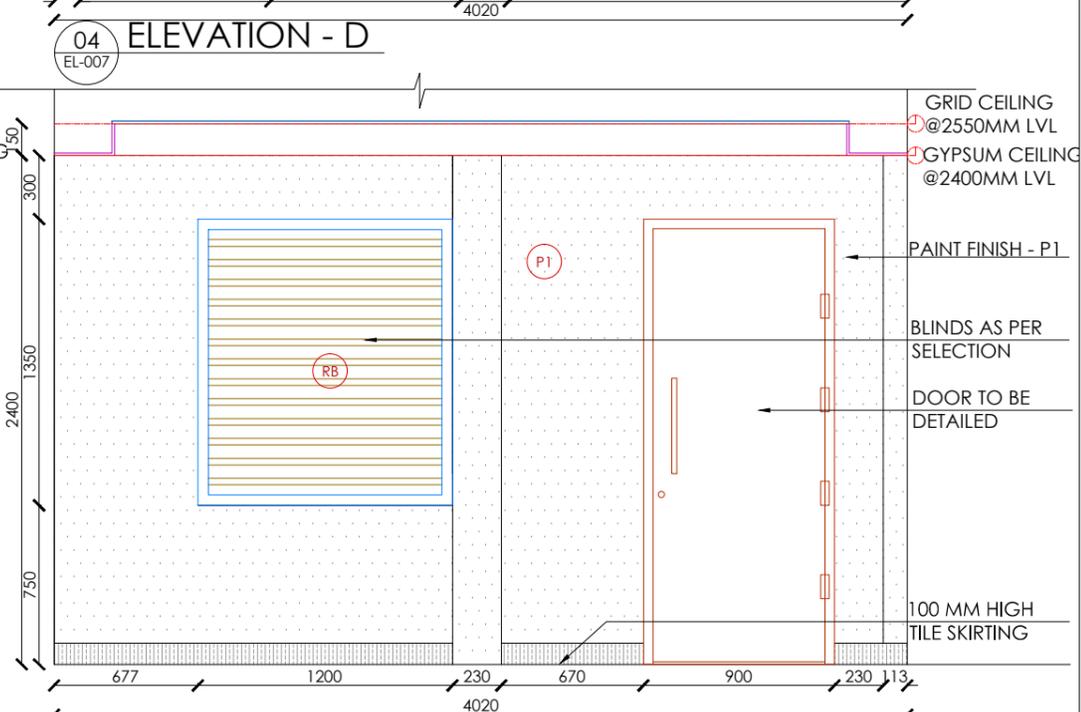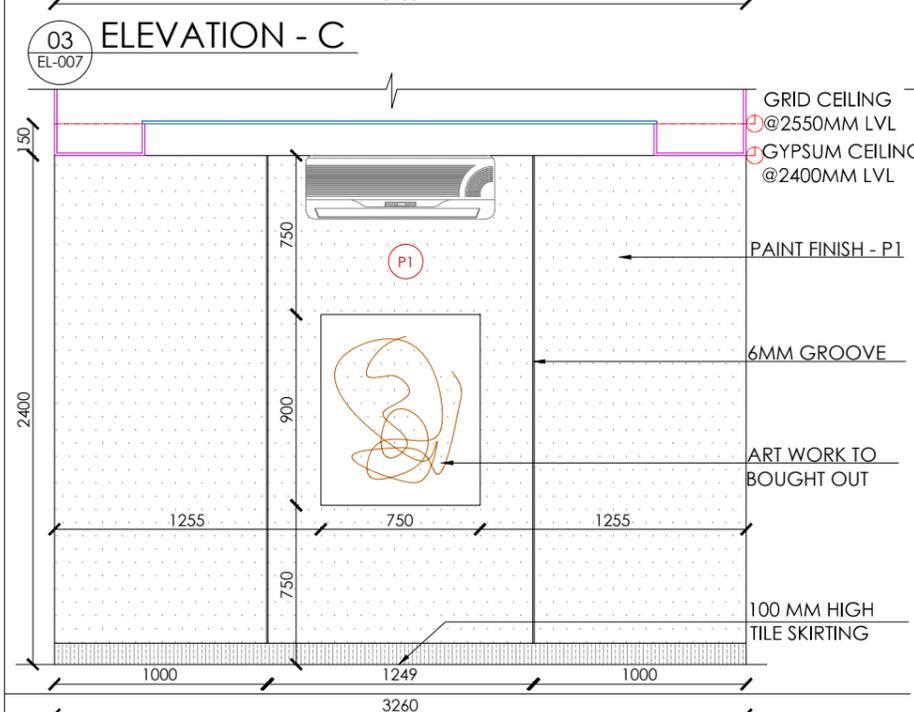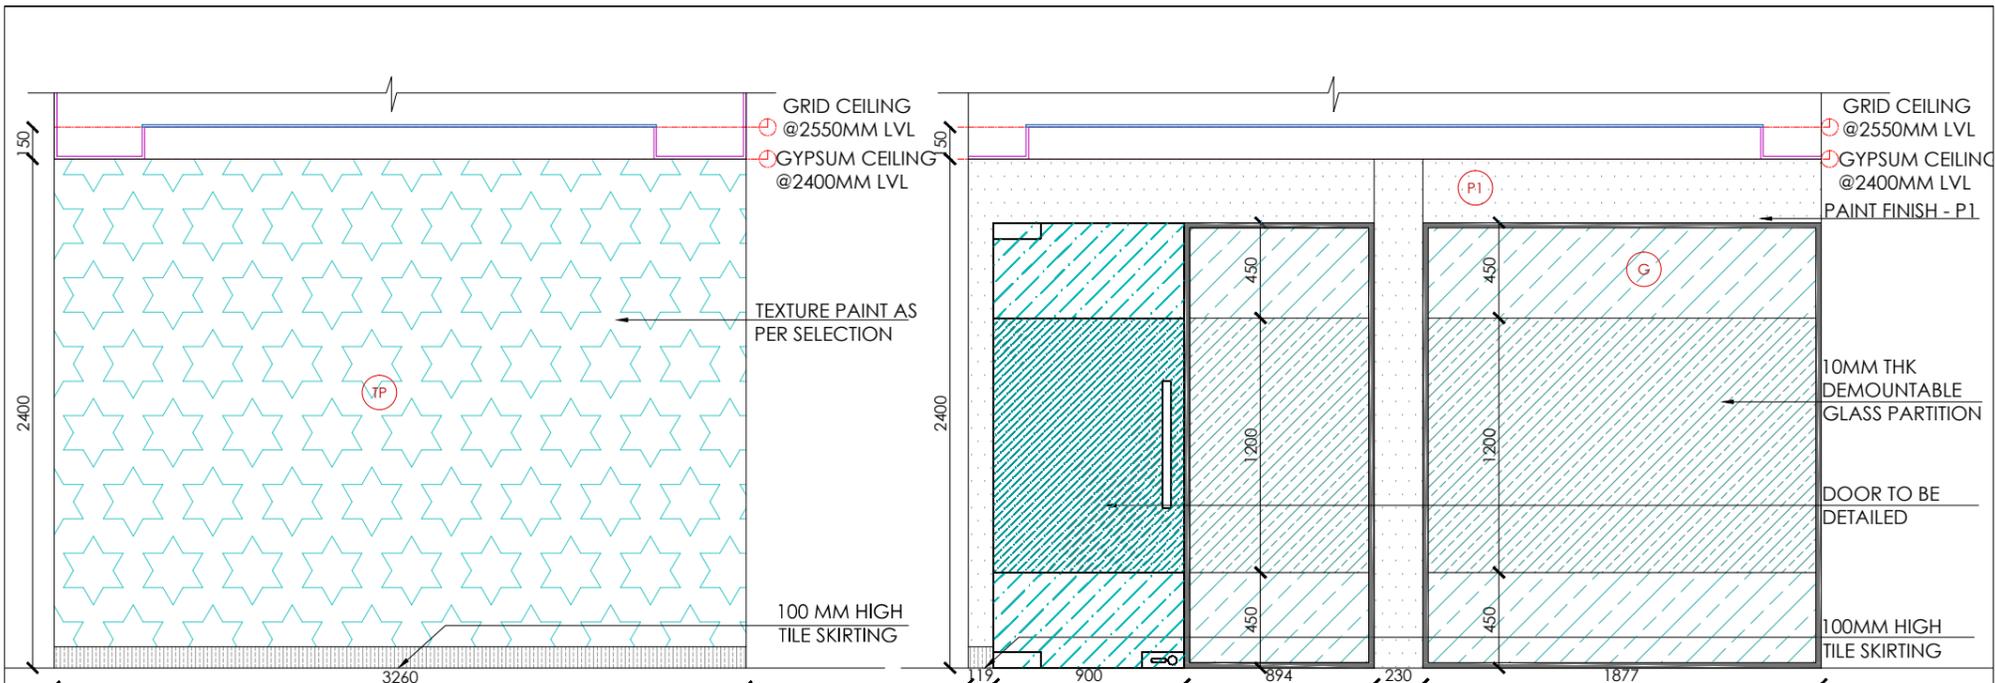


FINISHES LEGEND				
HATCH	TAG	FINISH	CODE	MAKE
[Pattern]	P1	PAINT		ASIAN
[Pattern]	TP	TEXTURE PAINT		ASIAN
[Pattern]	G	GLASS		
[Pattern]	GE	GLASS ETCHING		


Client	BPCL,VIJAYAWADA	Project Title	PROPOSED OFFICE INTERIOR FOR BPCL ,VIJAYAWADA	Drawing Title	CONFERENCE ROOM ELEVATION DRAWING	Dwg No	EL_007
GENERAL NOTE:		REV	DESCRIPTION	BY	DATE	Architects	
1. DRAWING TO BE USED ONLY FOR THE PURPOSE RELEASED.							New Designer Web Pvt Ltd No.185, 2nd Floor, 1st Main road, Nehru nagar, Kandanchavadi, Perungudi, Chennai - 600096 Tel: +91- 044 - 4212511/www.designerweb.in
2. DO NOT SCALE THIS DRAWING, ONLY WRITTEN DIMENSIONS TO BE FOLLOWED.							
3. ANY DISCREPANCY IN THE DRAWING SHOULD BE IMMEDIATELY BROUGHT TO THE NOTICE OF ARCHITECT.							
				Drawn	GOTHAJ	Scale	
				Checked	KARTHIK	SCALE	
				Approved	YVOM		
				Date	24.01.2024		
				Issued for			

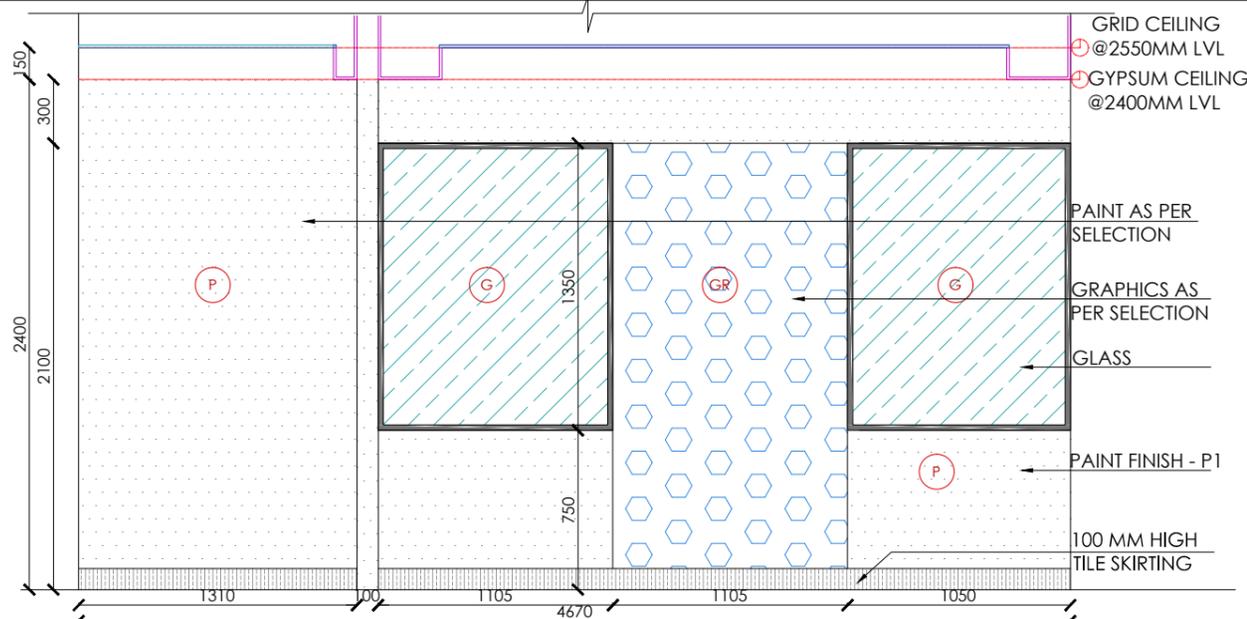


03 ELEVATION - C
EL-008

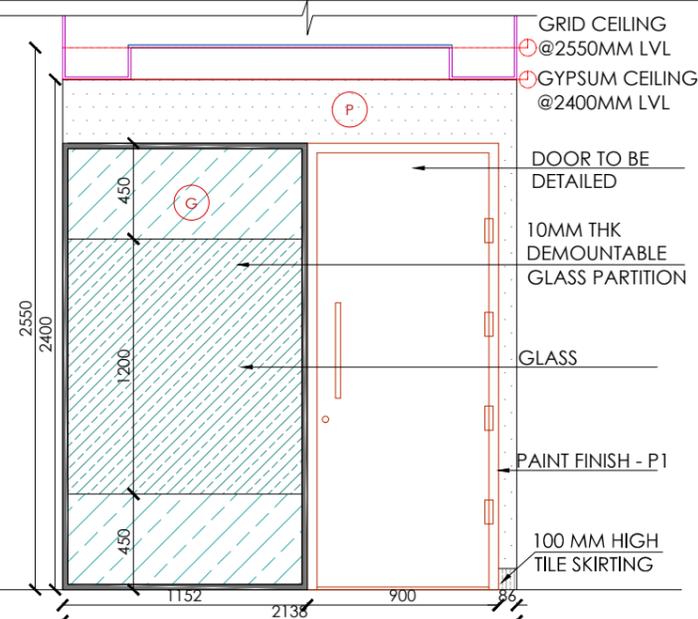

04 ELEVATION - D
EL-008

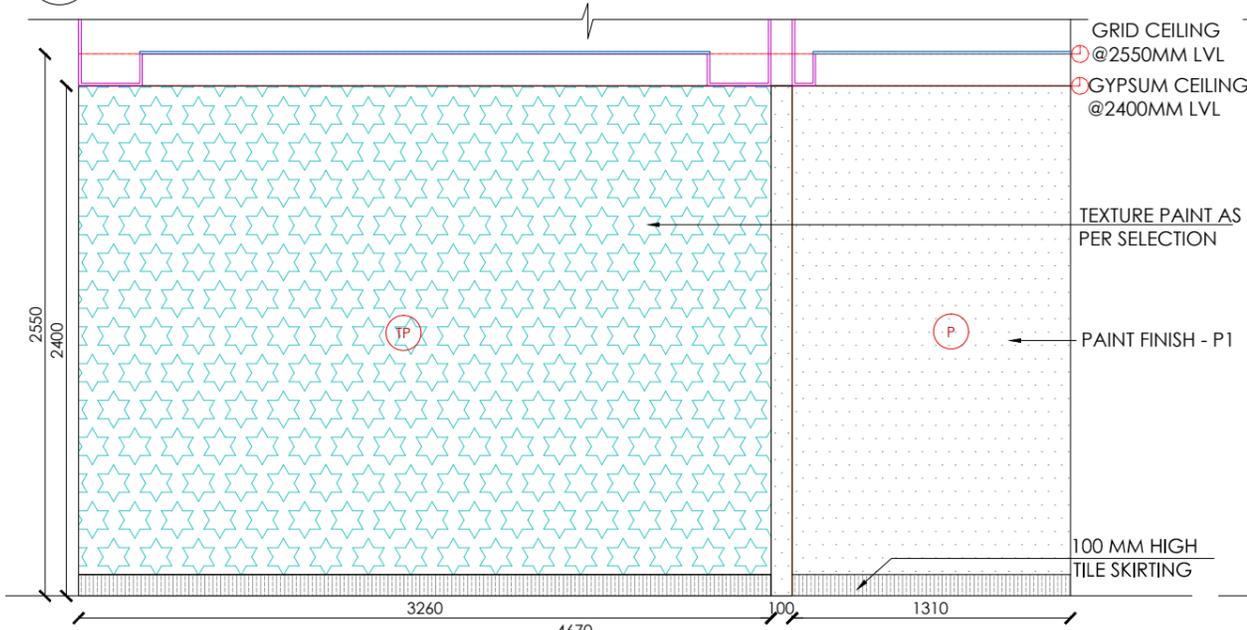


01 ELEVATION - A
EL-008

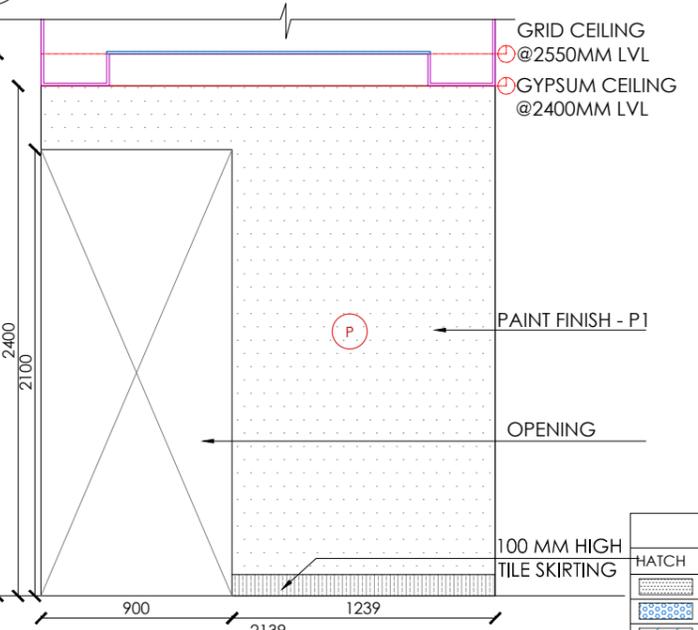


02 ELEVATION - B
EL-008

FINISHES LEGEND				
HATCH	TAG	FINISH	CODE	MAKE
[Dotted Pattern]	(P)	PAINT		ASIAN
[Star Pattern]	(G)	GRAPHICS		DESIGNED
[Diagonal Lines]	(G)	GLASS		
[Diagonal Lines with Dots]	(G)	GLASS ETCHING		
[Star Pattern]	(TP)	TEXTURE PAINT		ASIAN

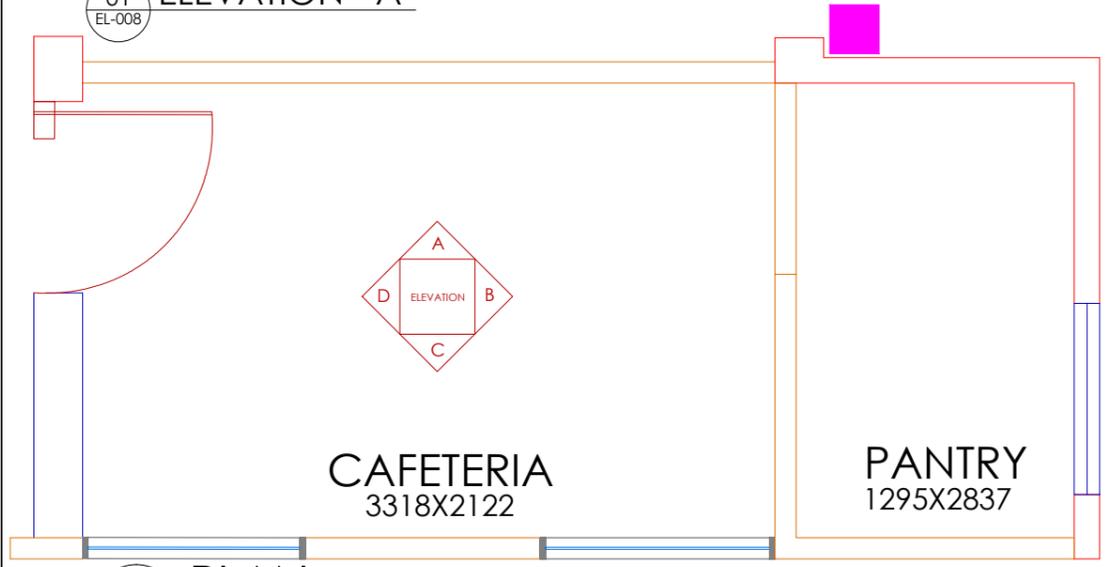

05 PLAN
EL-008

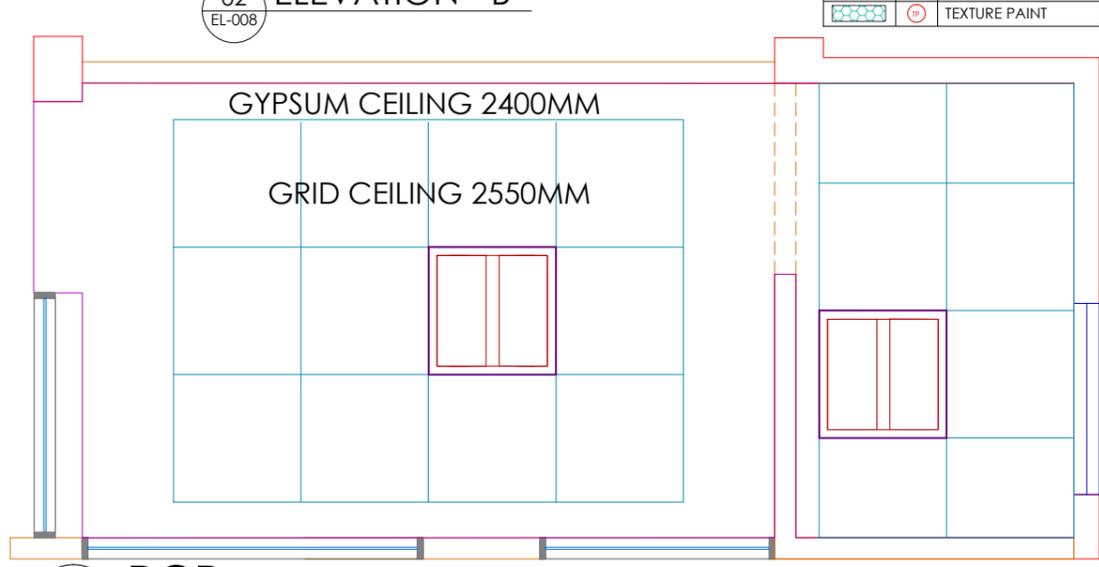

06 RCP
EL-008

GENERAL NOTE
 1. DRAWING TO BE USED ONLY FOR THE PURPOSE RELEASED.
 2. DO NOT SCALE THIS DRAWING, ONLY WRITTEN DIMENSIONS TO BE FOLLOWED.
 3. ANY DISCREPANCY IN THE DRAWING SHOULD BE IMMEDIATELY BROUGHT TO THE NOTICE OF ARCHITECT.

REV	DESCRIPTION	BY	DATE
1			
2			
3			
4			
5			

Client
 BPCL, VIJAYAWADA
 VIJAYAWADA


Project Title
 PROPOSED OFFICE INTERIOR FOR
 BPCL, VIJAYAWADA

Drawing Title
 CAFETERIA ELEVATION DRAWING


Architects
New Designer Web Pvt Ltd
 No.185, 2nd Floor, 1st Main road, Nehru nagar,
 Kanchanchavadi, Perungudi, Chennai - 600096
 Tel: +91-844-4212511 www.designerweb.in

Drawn
 Checked
 Approved


GOTHAISRI
 KARTHIK
 VYOM
 Date 24.01.2024
 Scale SCALE
 Dwg No EL_008
 File Name

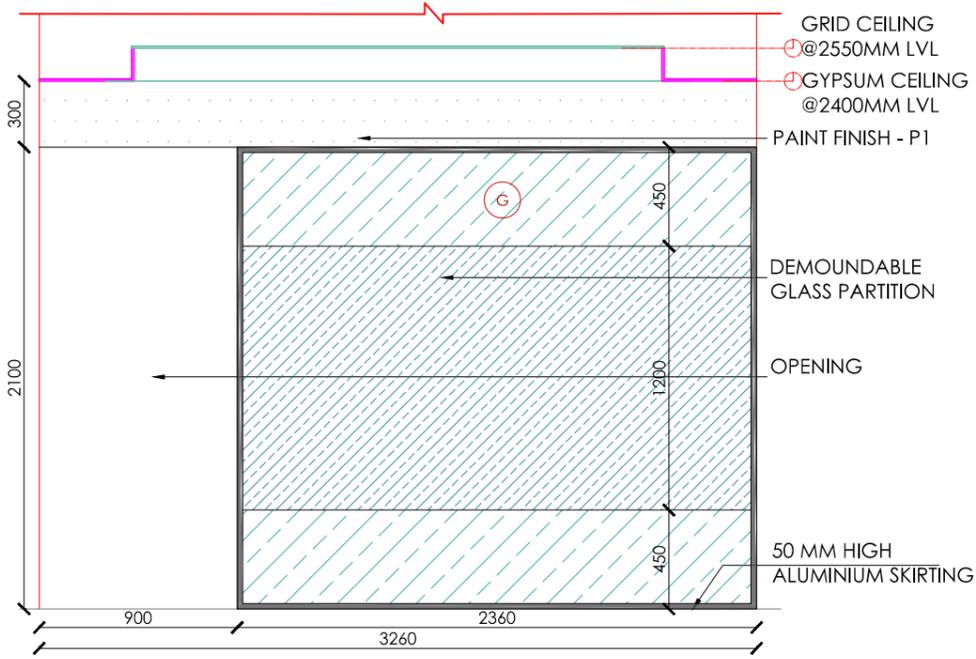


01 ELEVATION - C
EL-009

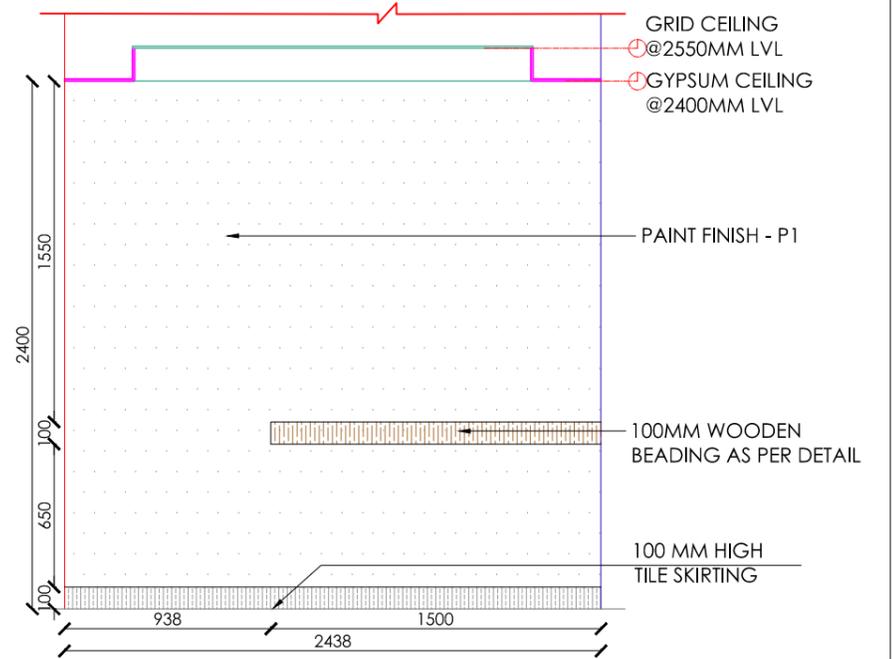


01 ELEVATION - D
EL-009

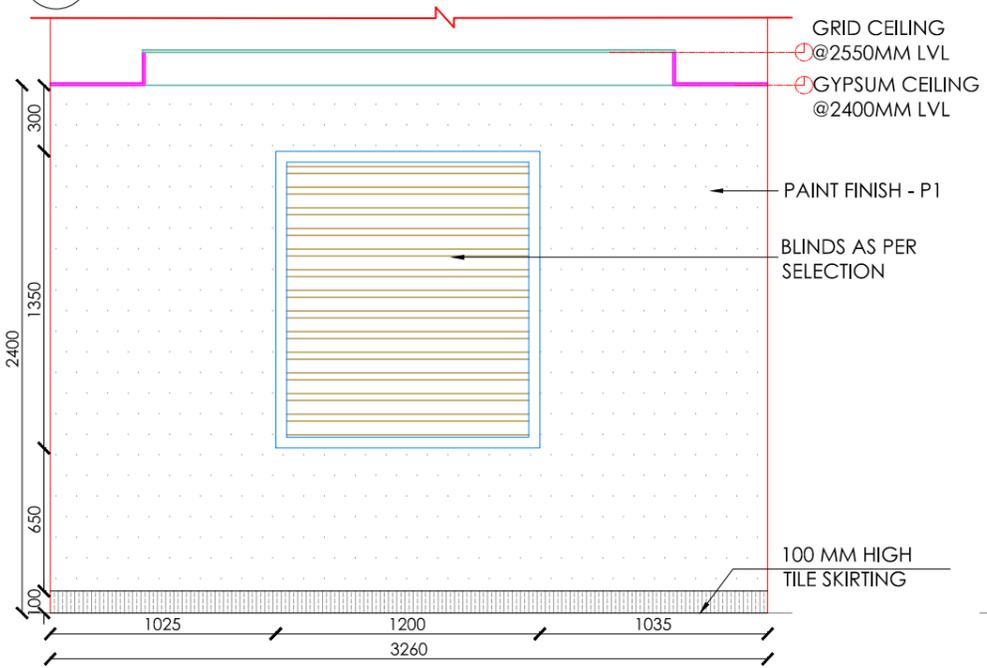


01 ELEVATION - A
EL-009

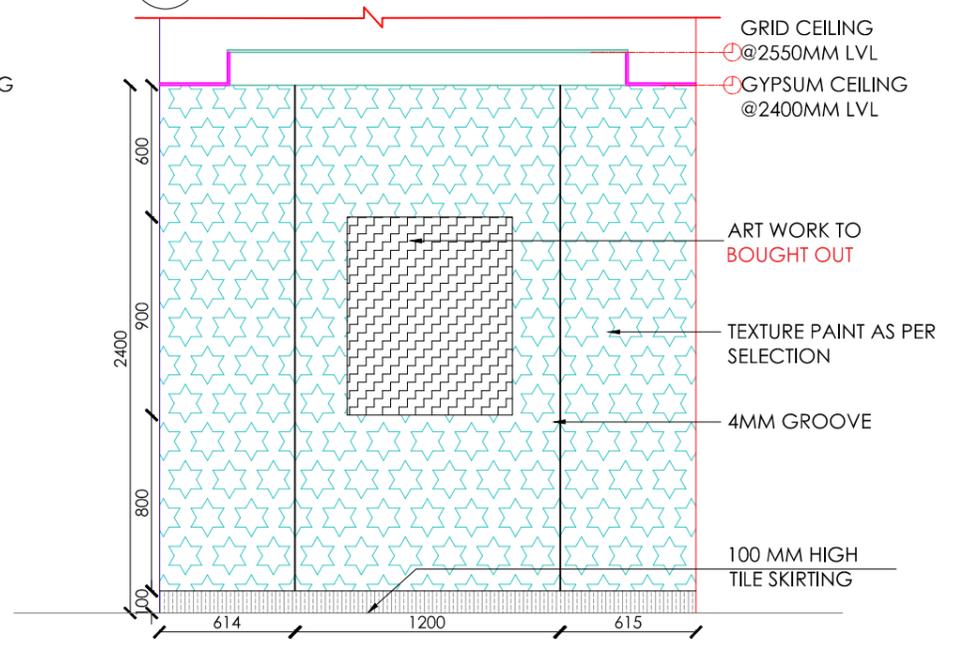

01 ELEVATION - B
EL-009

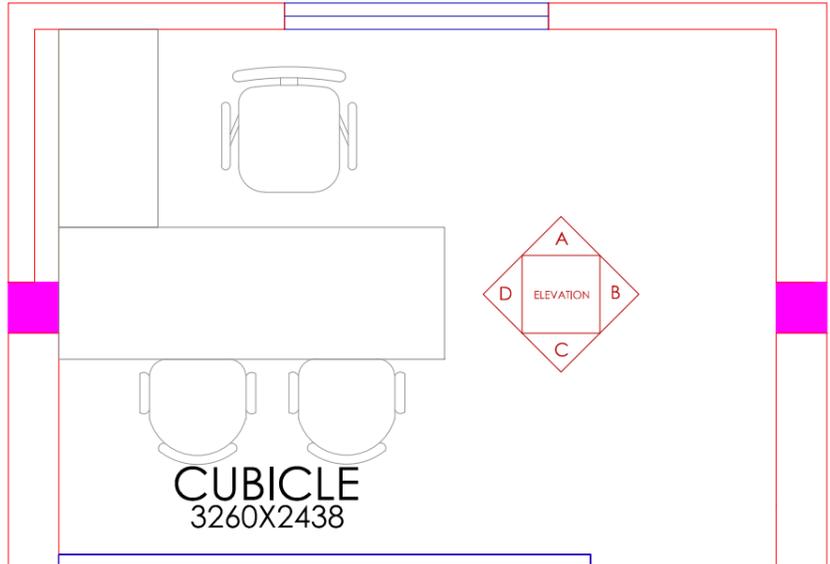


05 PLAN
EL-009

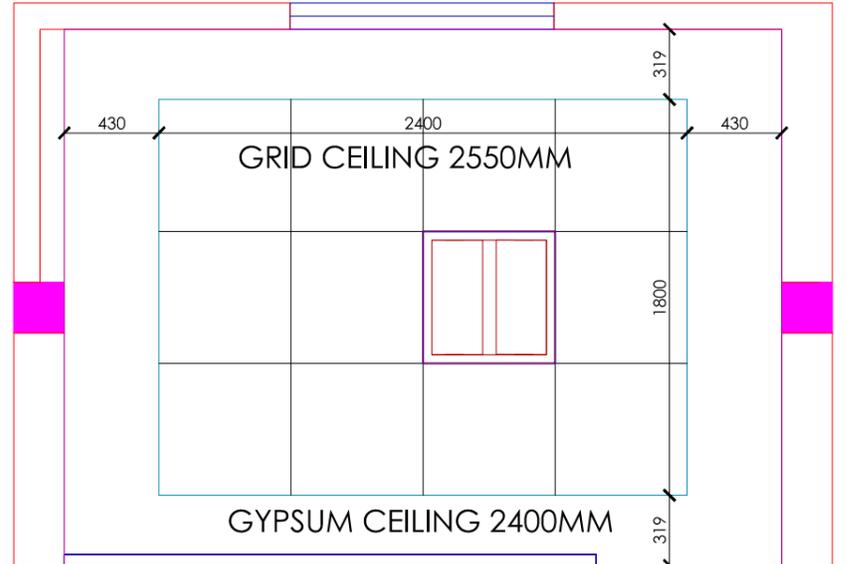


06 RCP
EL-009

FINISHES LEGEND				
HATCH	TAG	FINISH	CODE	MAKE
	P1	PAINT		ASIAN
	TP	TEXTURE PAINT		ASIAN
	G	GLASS		
	GE	GLASS ETCHING		


Client	BPCL,VIJAYAWADA	Project Title	PROPOSED OFFICE INTERIOR FOR BPCL ,VIJAYAWADA	Drawing Title	CUBILE ELEVATION DRAWING	Dwg No	EL_009
GENERAL NOTE: 1. DRAWING TO BE USED ONLY FOR THE PURPOSE RELEASED. 2. DO NOT SCALE THIS DRAWING, ONLY WRITTEN DIMENSIONS TO BE FOLLOWED. 3. ANY DISCREPANCY IN THE DRAWING SHOULD BE IMMEDIATELY BROUGHT TO THE NOTICE OF ARCHITECT.		REV	DESCRIPTION	BY	DATE	 Architects New Designer Web Pvt Ltd No.185, 2nd Floor, 1st Main road, Nehru nagar, Kandanchavadi, Perungudi, Chennai - 600096 Tel: +91- 044 - 42125111www.designerweb.in	
		Drawn	KARTHIK	Checked	NYOM	Approved	NYOM
		Date	24.01.2024	Issued for		Scale	SCALE

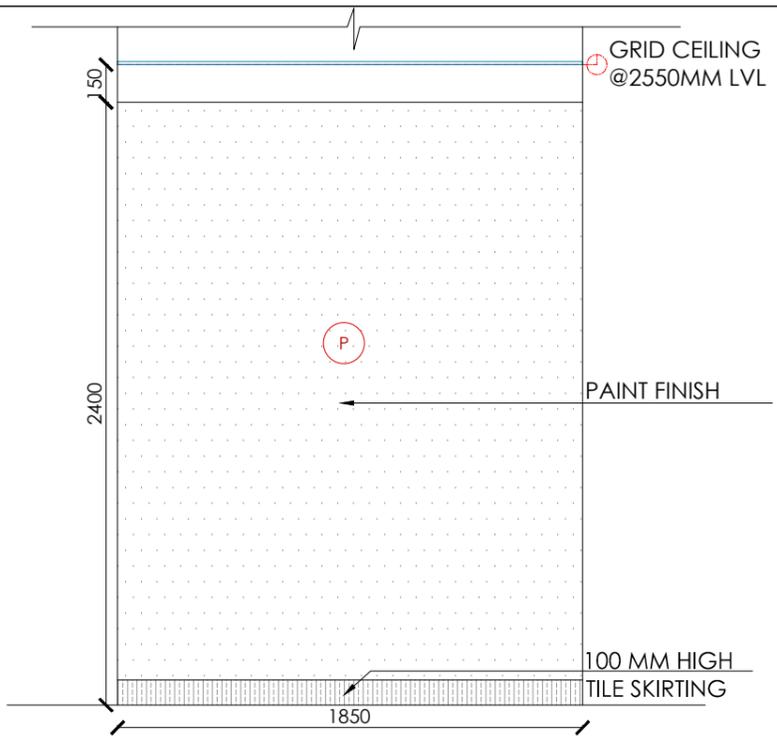


03 ELEVATION - C
EL-010

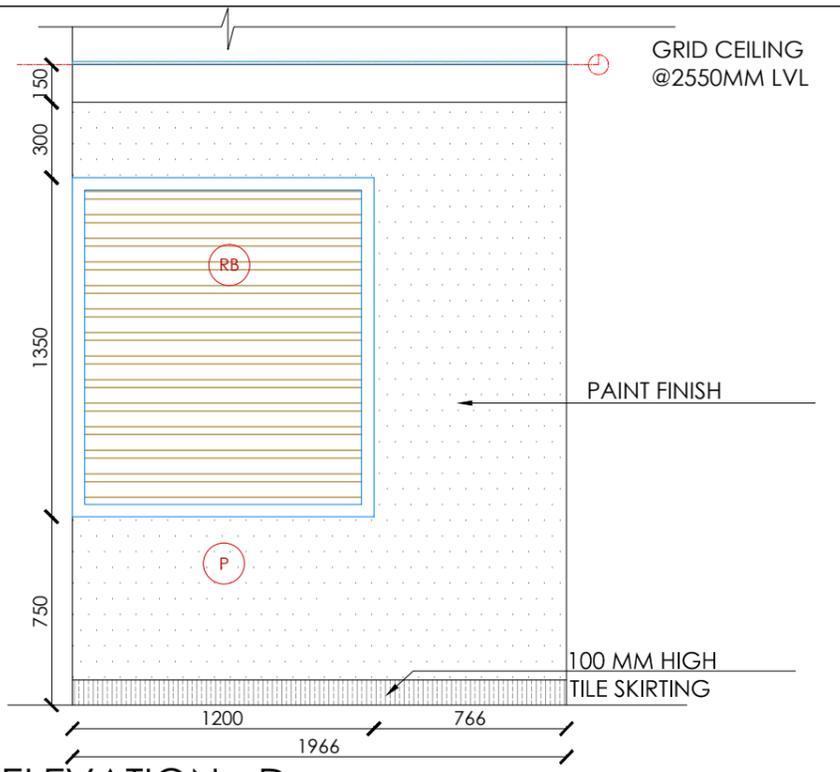


04 ELEVATION - D
EL-010

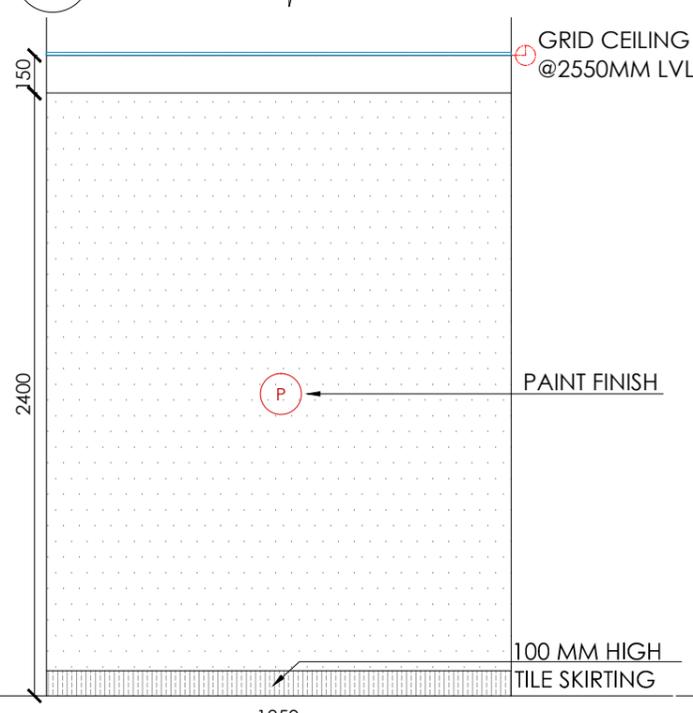

01 ELEVATION - A
EL-010

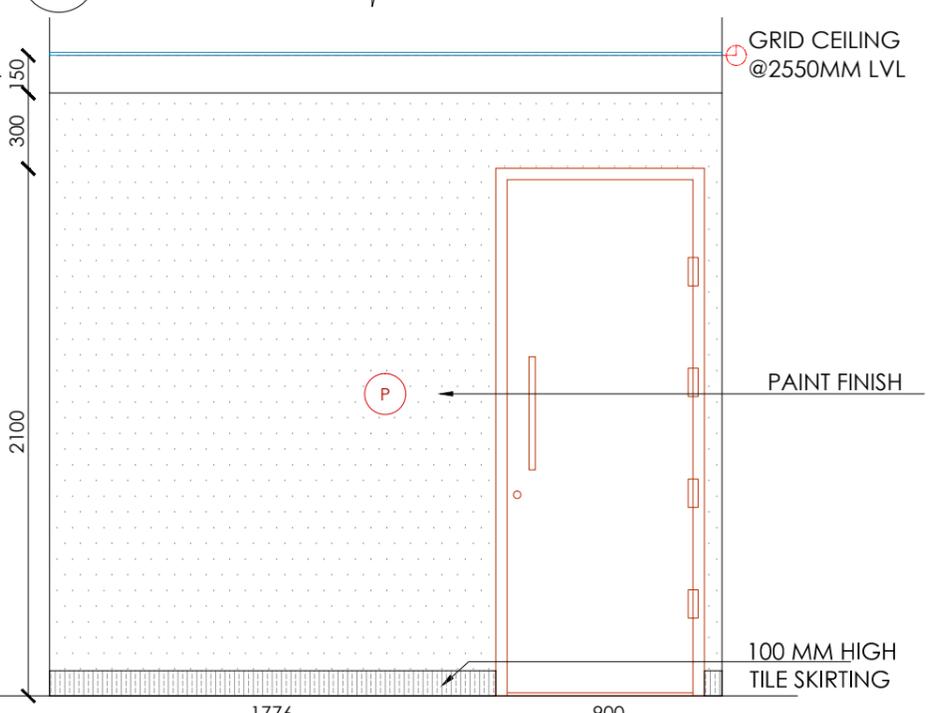

02 ELEVATION - B
EL-010

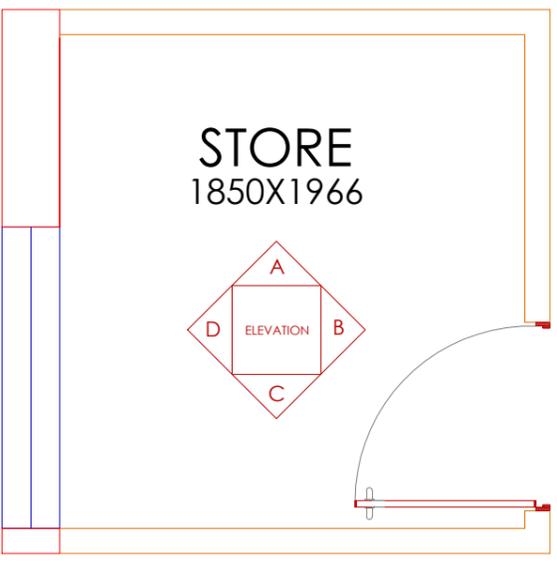


05 PLAN
EL-010




06 RCP
EL-010

FINISHES LEGEND				
HATCH	TAG	FINISH	CODE	MAKE
	PI	PAINT		ASIAN

Client	BPCL,VIJAYAWADA	Project Title	PROPOSED OFFICE INTERIOR FOR BPCL ,VIJAYAWADA	Drawing Title	STORE ROOM - SS ELEVATION DRAWING	Dwg No	EL_010
GENERAL NOTE:		REV	DESCRIPTION	BY	DATE	Architects	
1. DRAWING TO BE USED ONLY FOR THE PURPOSE RELEASED.						New Designer Web Pvt Ltd	
2. DO NOT SCALE THIS DRAWING, ONLY WRITTEN DIMENSIONS TO BE FOLLOWED.						No.185, 2nd Floor, 1st Main road, Nehru nagar, Kandanchavadi, Perungudi, Chennai - 600096	
3. ANY DISCREPANCY IN THE DRAWING SHOULD BE IMMEDIATELY BROUGHT TO THE NOTICE OF ARCHITECT.						Tel: +91- 044 - 42125111www.designerweb.in	
		Drawn	GOTHAJ	Date		Scale	
		Checked	KARTHIK	Date		SCALE	
		Approved	VYOM	Date		SCALE	
		Issued for		Date		SCALE	

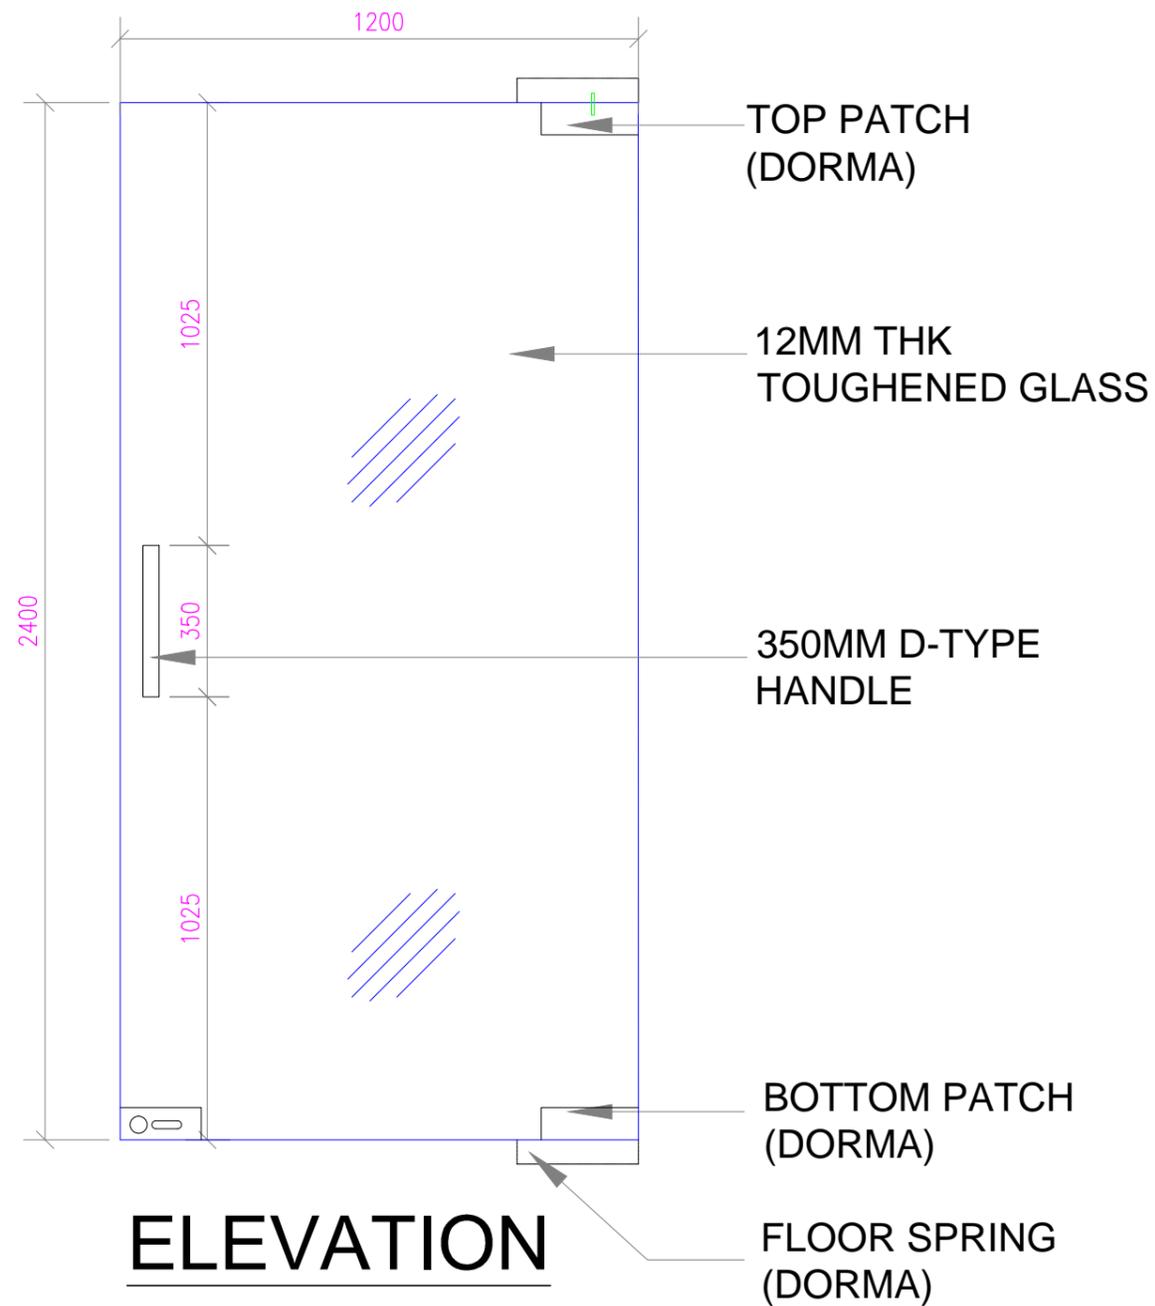

ELEVATION

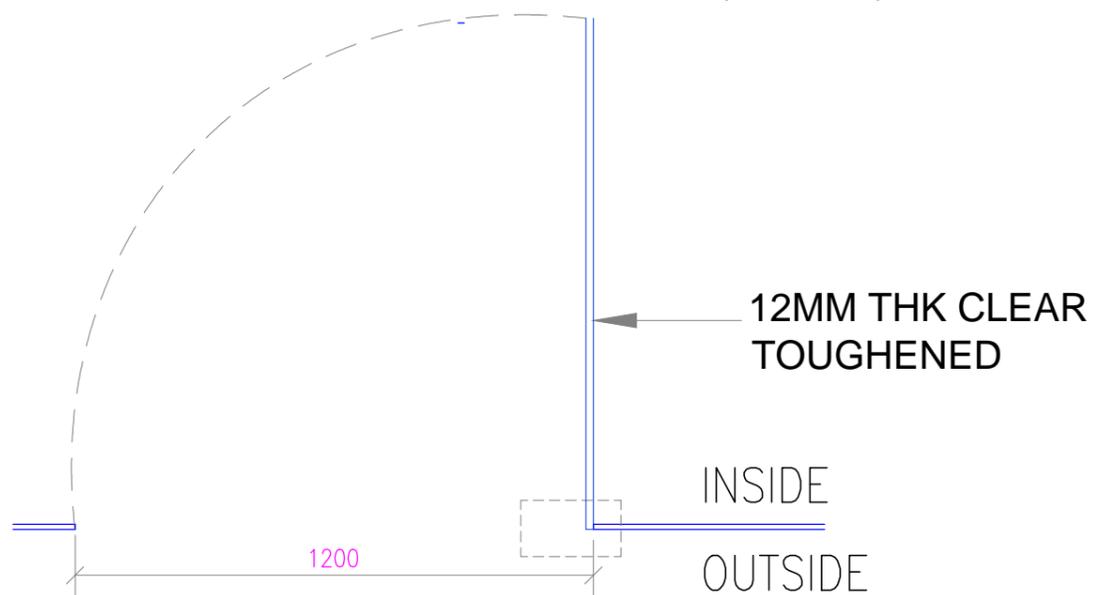

PLAN - G1

TAG	DESCRIPTION	SIZE	NOS
G1	GLASS DOOR	1200X2100	01
G2	GLASS DOOR	900X2100	09
D1	FLUSH DOOR	900X2100	04
D2	FLUSH DOOR	750X2100	07

GENERAL NOTE

1. DRAWING TO BE USED ONLY FOR THE PURPOSE RELEASED.
2. DO NOT SCALE THIS DRAWING, ONLY WRITTEN DIMENSIONS TO BE FOLLOWED.
3. ANY DISCREPANCY IN THE DRAWING SHOULD BE IMMEDIATELY BROUGHT TO THE NOTICE OF ARCHITECT.

REV	DESCRIPTION	BY	DATE
1			
2			
3			
4			
5			

Client
BPCL



Project Title
PROPOSED INTERIORS FOR BPCL
TERRITORY OFFICE @ VIJAYAWADA

Drawing Title
DOOR DETAIL - G1

Architects
New Designer Web Pvt Ltd
No.185, 2nd Floor, 1st Main road, Nehru nagar,
Kandanchavadi, Perungudi, Chennai - 600096
Tel: +91- 844 - 4212511/www.designerweb.in

Drawn	KARTHIK
Checked	VYOM
Approved	VYOM
Date	29.01.2024
Scale	
Dwg.No	DD_01A
File Name	



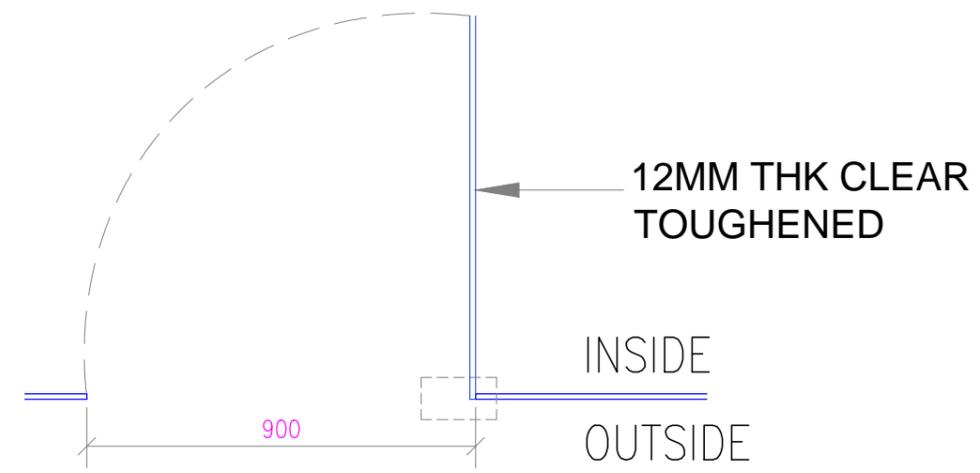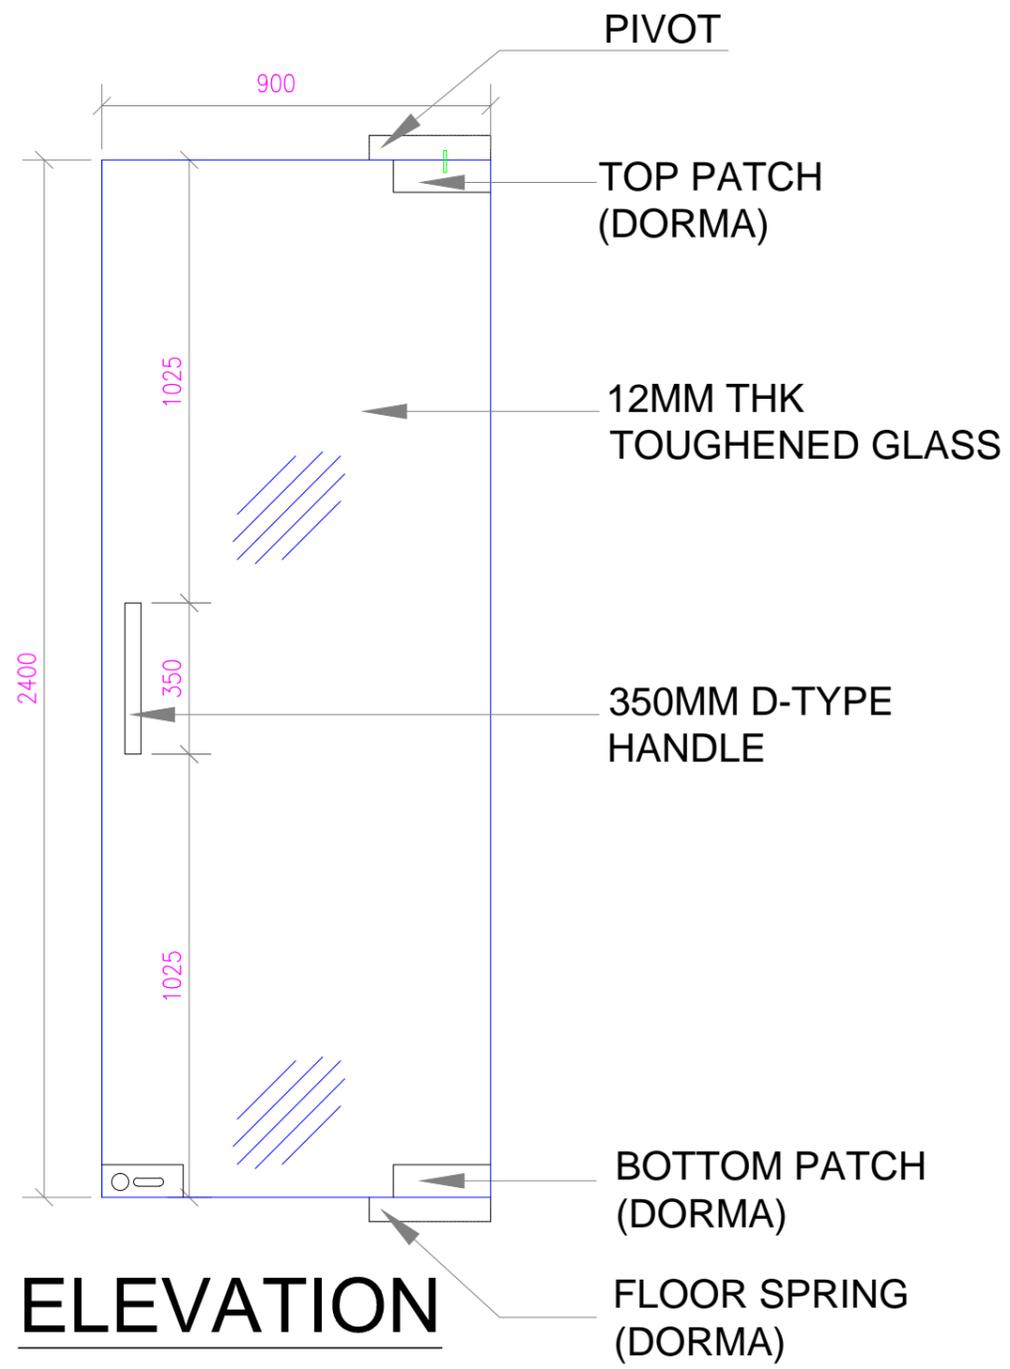

PLAN - G2

TAG	DESCRIPTION	SIZE	NOS
G1	GLASS DOOR	1200X2100	01
G2	GLASS DOOR	900X2100	09
D1	FLUSH DOOR	900X2100	04
D2	FLUSH DOOR	750X2100	07

GENERAL NOTE

- DRAWING TO BE USED ONLY FOR THE PURPOSE RELEASED.
- DO NOT SCALE THIS DRAWING, ONLY WRITTEN DIMENSIONS TO BE FOLLOWED.
- ANY DISCREPANCY IN THE DRAWING SHOULD BE IMMEDIATELY BROUGHT TO THE NOTICE OF ARCHITECT.

REV	DESCRIPTION	BY	DATE
1			
2			
3			
4			
5			

Client
BPCL

Project Title
PROPOSED INTERIORS FOR BPCL TERRITORY OFFICE @ VIJAYAWADA



Drawing Title
DOOR DETAIL - G2

Architects
New Designer Web Pvt Ltd
No.185, 2nd Floor, 1st Main road, Nehru nagar, Kandanchavadi, Perungudi, Chennai - 600096
Tel: +91- 844 - 4212511 www.designerweb.in

Drawn	KARTHIK
Checked	VYOM
Approved	VYOM
Date	29.01.2024
Scale	
Dwg.No	DD_01B
File Name	





GENERAL NOTE

1. DRAWING TO BE USED ONLY FOR THE PURPOSE RELEASED.
2. DO NOT SCALE THIS DRAWING, ONLY WRITTEN DIMENSIONS TO BE FOLLOWED.
3. ANY DISCREPANCY IN THE DRAWING SHOULD BE IMMEDIATELY BROUGHT TO THE NOTICE OF ARCHITECT.

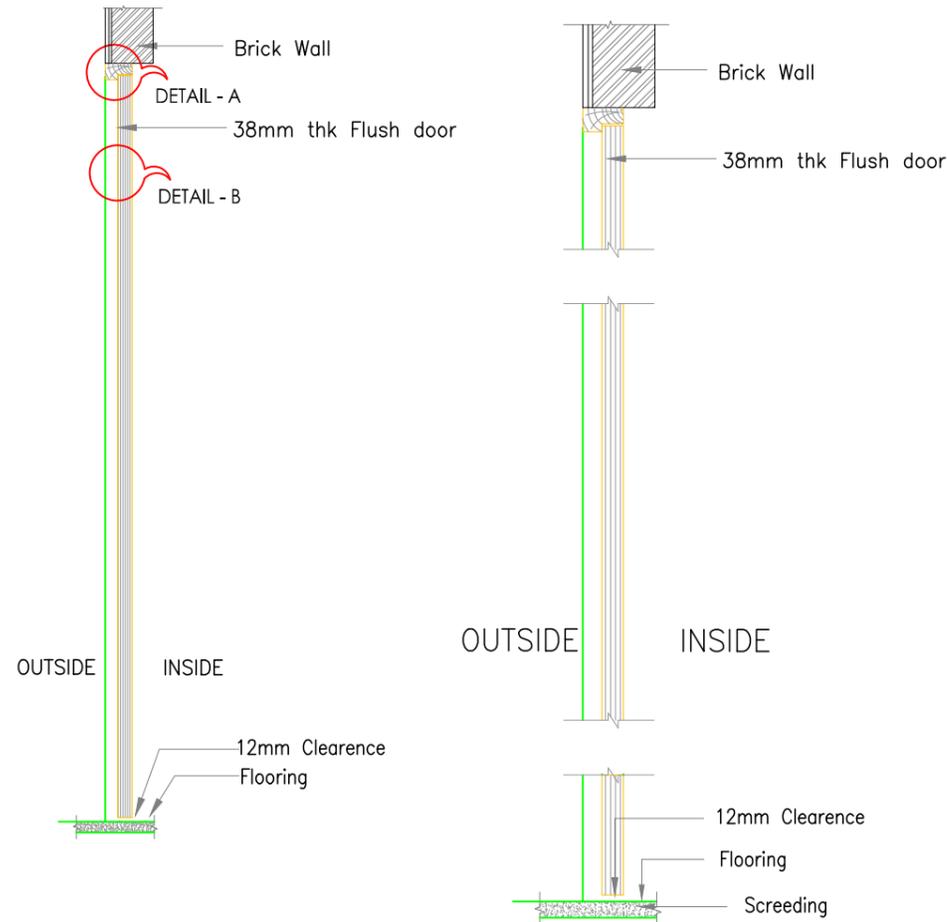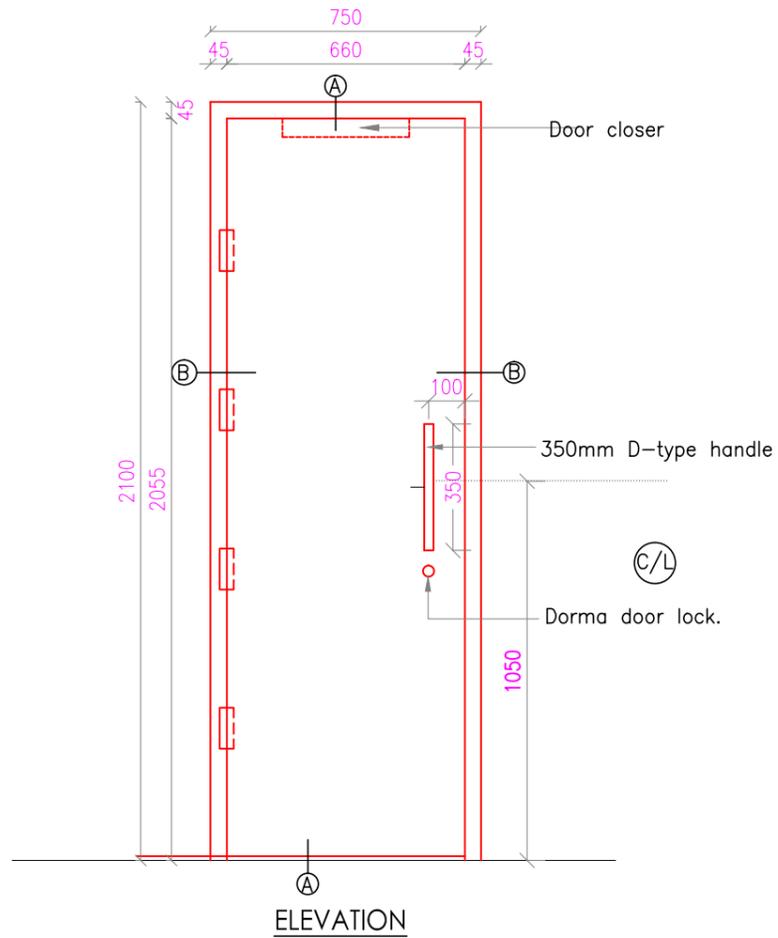

AA TYPICAL VERTICAL DOOR SECTION

ENLARGED VERTICAL DOOR SECTION

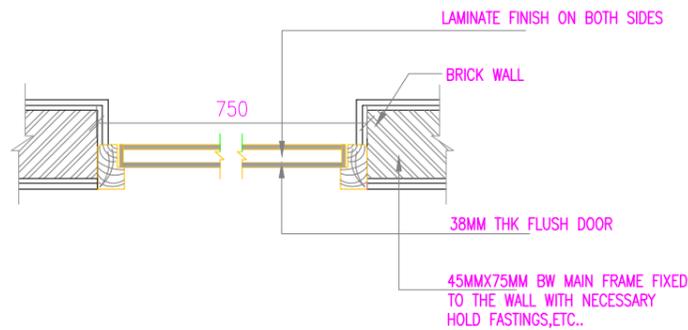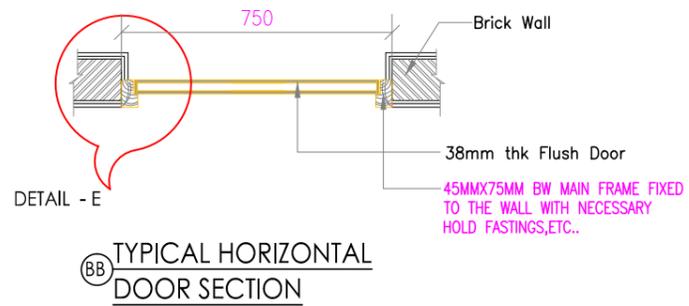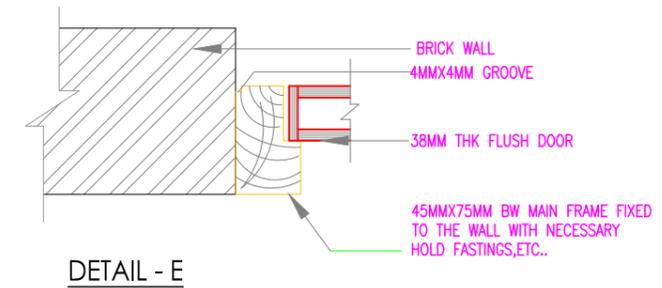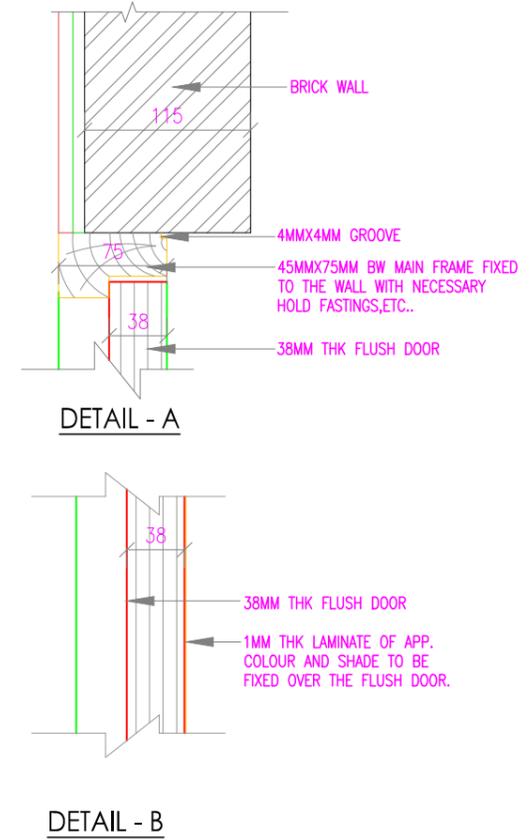

TAG	DESCRIPTION	SIZE	NOS
G1	GLASS DOOR	1200X2100	01
G2	GLASS DOOR	900X2100	09
D1	FLUSH DOOR	900X2100	04
D2	FLUSH DOOR	750X2100	07

REV	DESCRIPTION	BY	DATE
1			
2			
3			
4			
5			

Client
BPCL






Project Title
PROPOSED INTERIORS FOR BPCL TERRITORY OFFICE @ VIJAYAWADA

Drawing Title
DOOR DETAIL - D2

Architects
New Designer Web Pvt Ltd
No.185, 2nd Floor, 1st Main road, Nehru nagar, Kandanchavadi, Perungudi, Chennai - 600096
Tel: +91-844-4212511 | www.designerweb.in

Drawn
Checked
Approved
Date
Scale
Dwg.No
File Name

KARTHIK
VYOM
VYOM
29.01.2024
DD_01C

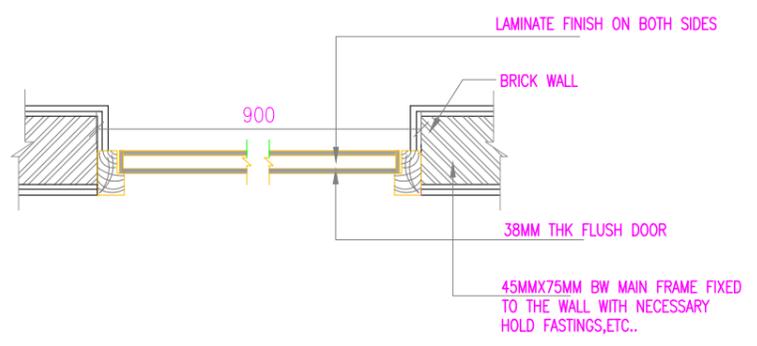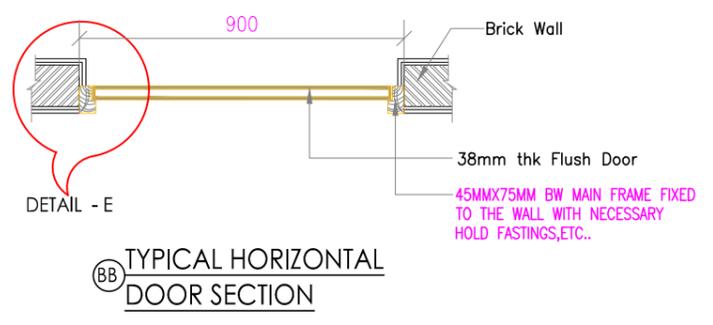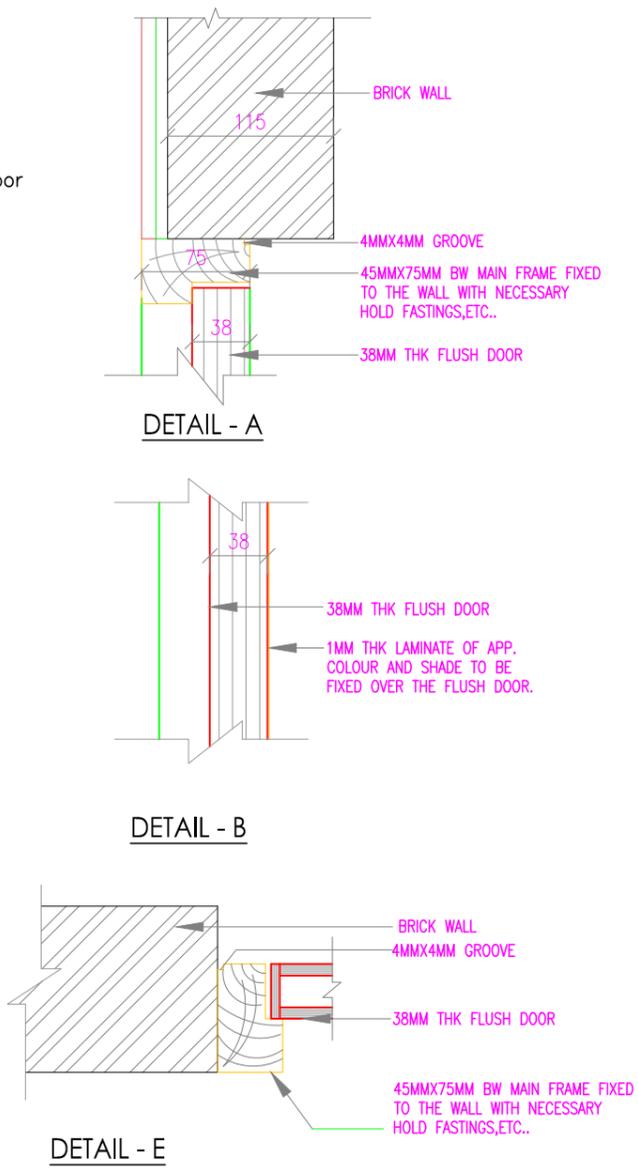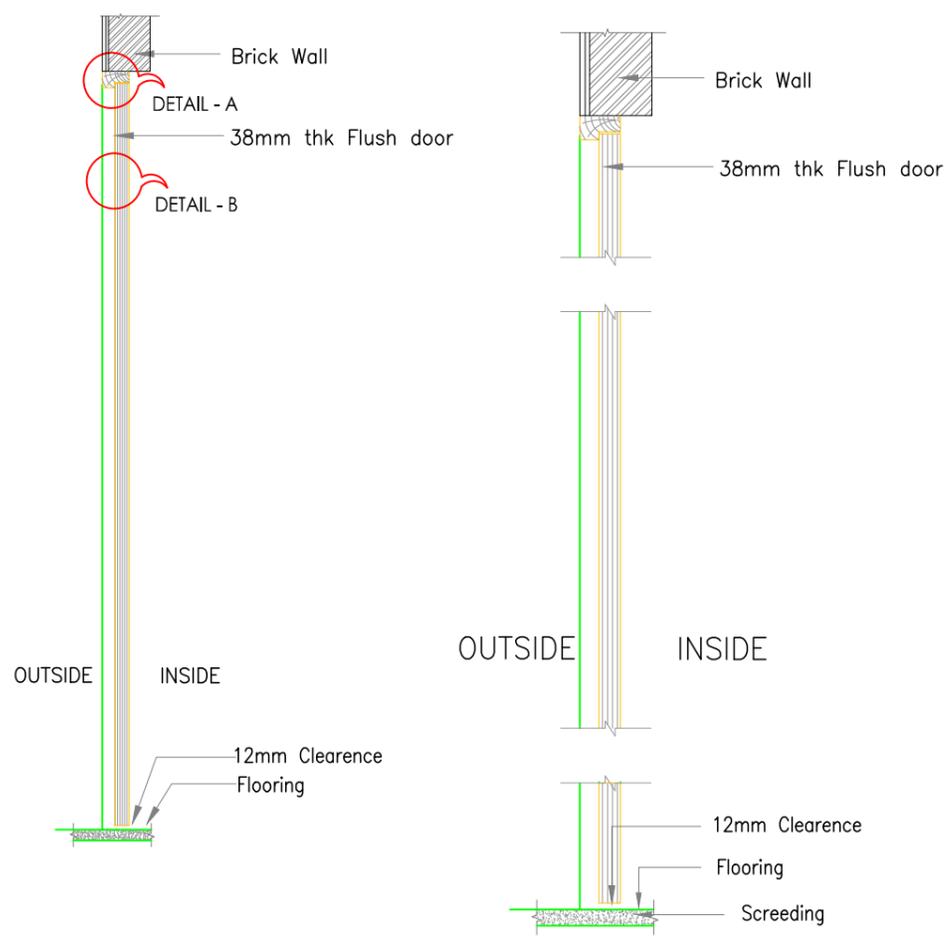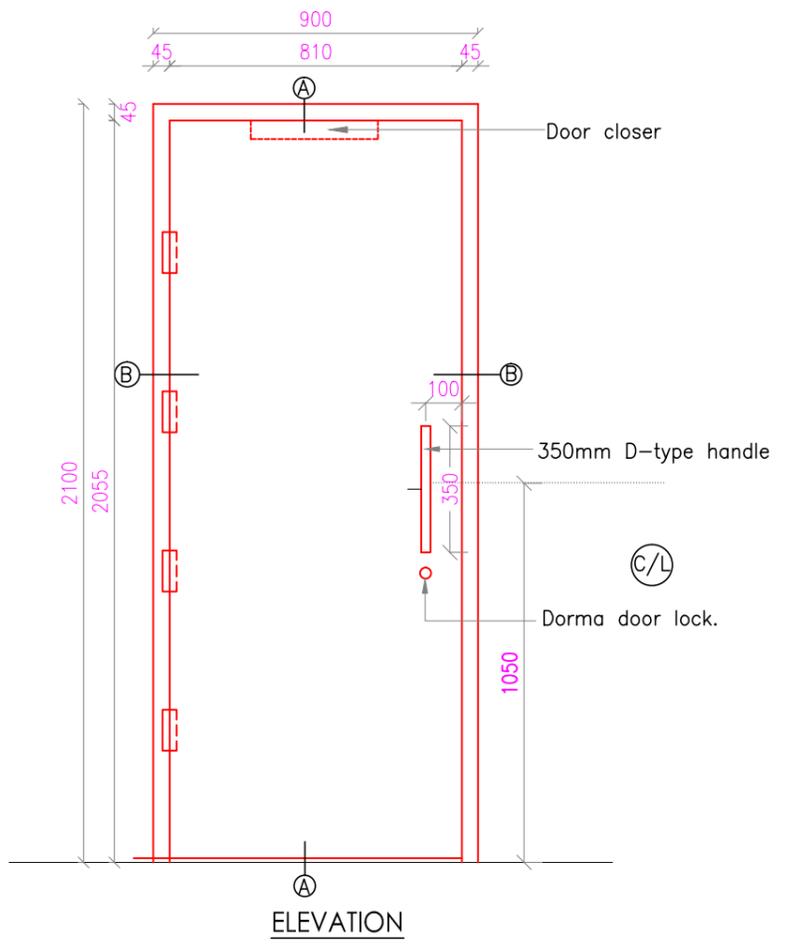

TAG	DESCRIPTION	SIZE	NOS
G1	GLASS DOOR	1200X2100	01
G2	GLASS DOOR	900X2100	09
D1	FLUSH DOOR	900X2100	04
D2	FLUSH DOOR	750X2100	07

GENERAL NOTE

- DRAWING TO BE USED ONLY FOR THE PURPOSE RELEASED.
- DO NOT SCALE THIS DRAWING, ONLY WRITTEN DIMENSIONS TO BE FOLLOWED.
- ANY DISCREPANCY IN THE DRAWING SHOULD BE IMMEDIATELY BROUGHT TO THE NOTICE OF ARCHITECT.

REV	DESCRIPTION	BY	DATE
1			
2			
3			
4			
5			

Client
BPCL

Project Title
PROPOSED INTERIORS FOR BPCL TERRITORY OFFICE @ VIJAYAWADA


Drawing Title
DOOR DETAIL - D1

Architects
New Designer Web Pvt Ltd
No.185, 2nd Floor, 1st Main road, Nehru nagar, Kandanchavadi, Perungudi, Chennai - 600096
Tel: +91-844-4212511 | www.designerweb.in

Drawn	KARTHIK
Checked	VYOM
Approved	VYOM
Date	29.01.2024
Scale	
Dwg.No	DD_01D
File Name	

GENERAL NOTE

1. DRAWING TO BE USED ONLY FOR THE PURPOSE RELEASED
2. DO NOT SCALE THIS DRAWING, ONLY WRITTEN DIMENSIONS TO BE FOLLOWED.
3. ANY DISCREPANCY IN THE DRAWING SHOULD BE IMMEDIATELY BROUGHT TO THE NOTICE OF ARCHITECT.

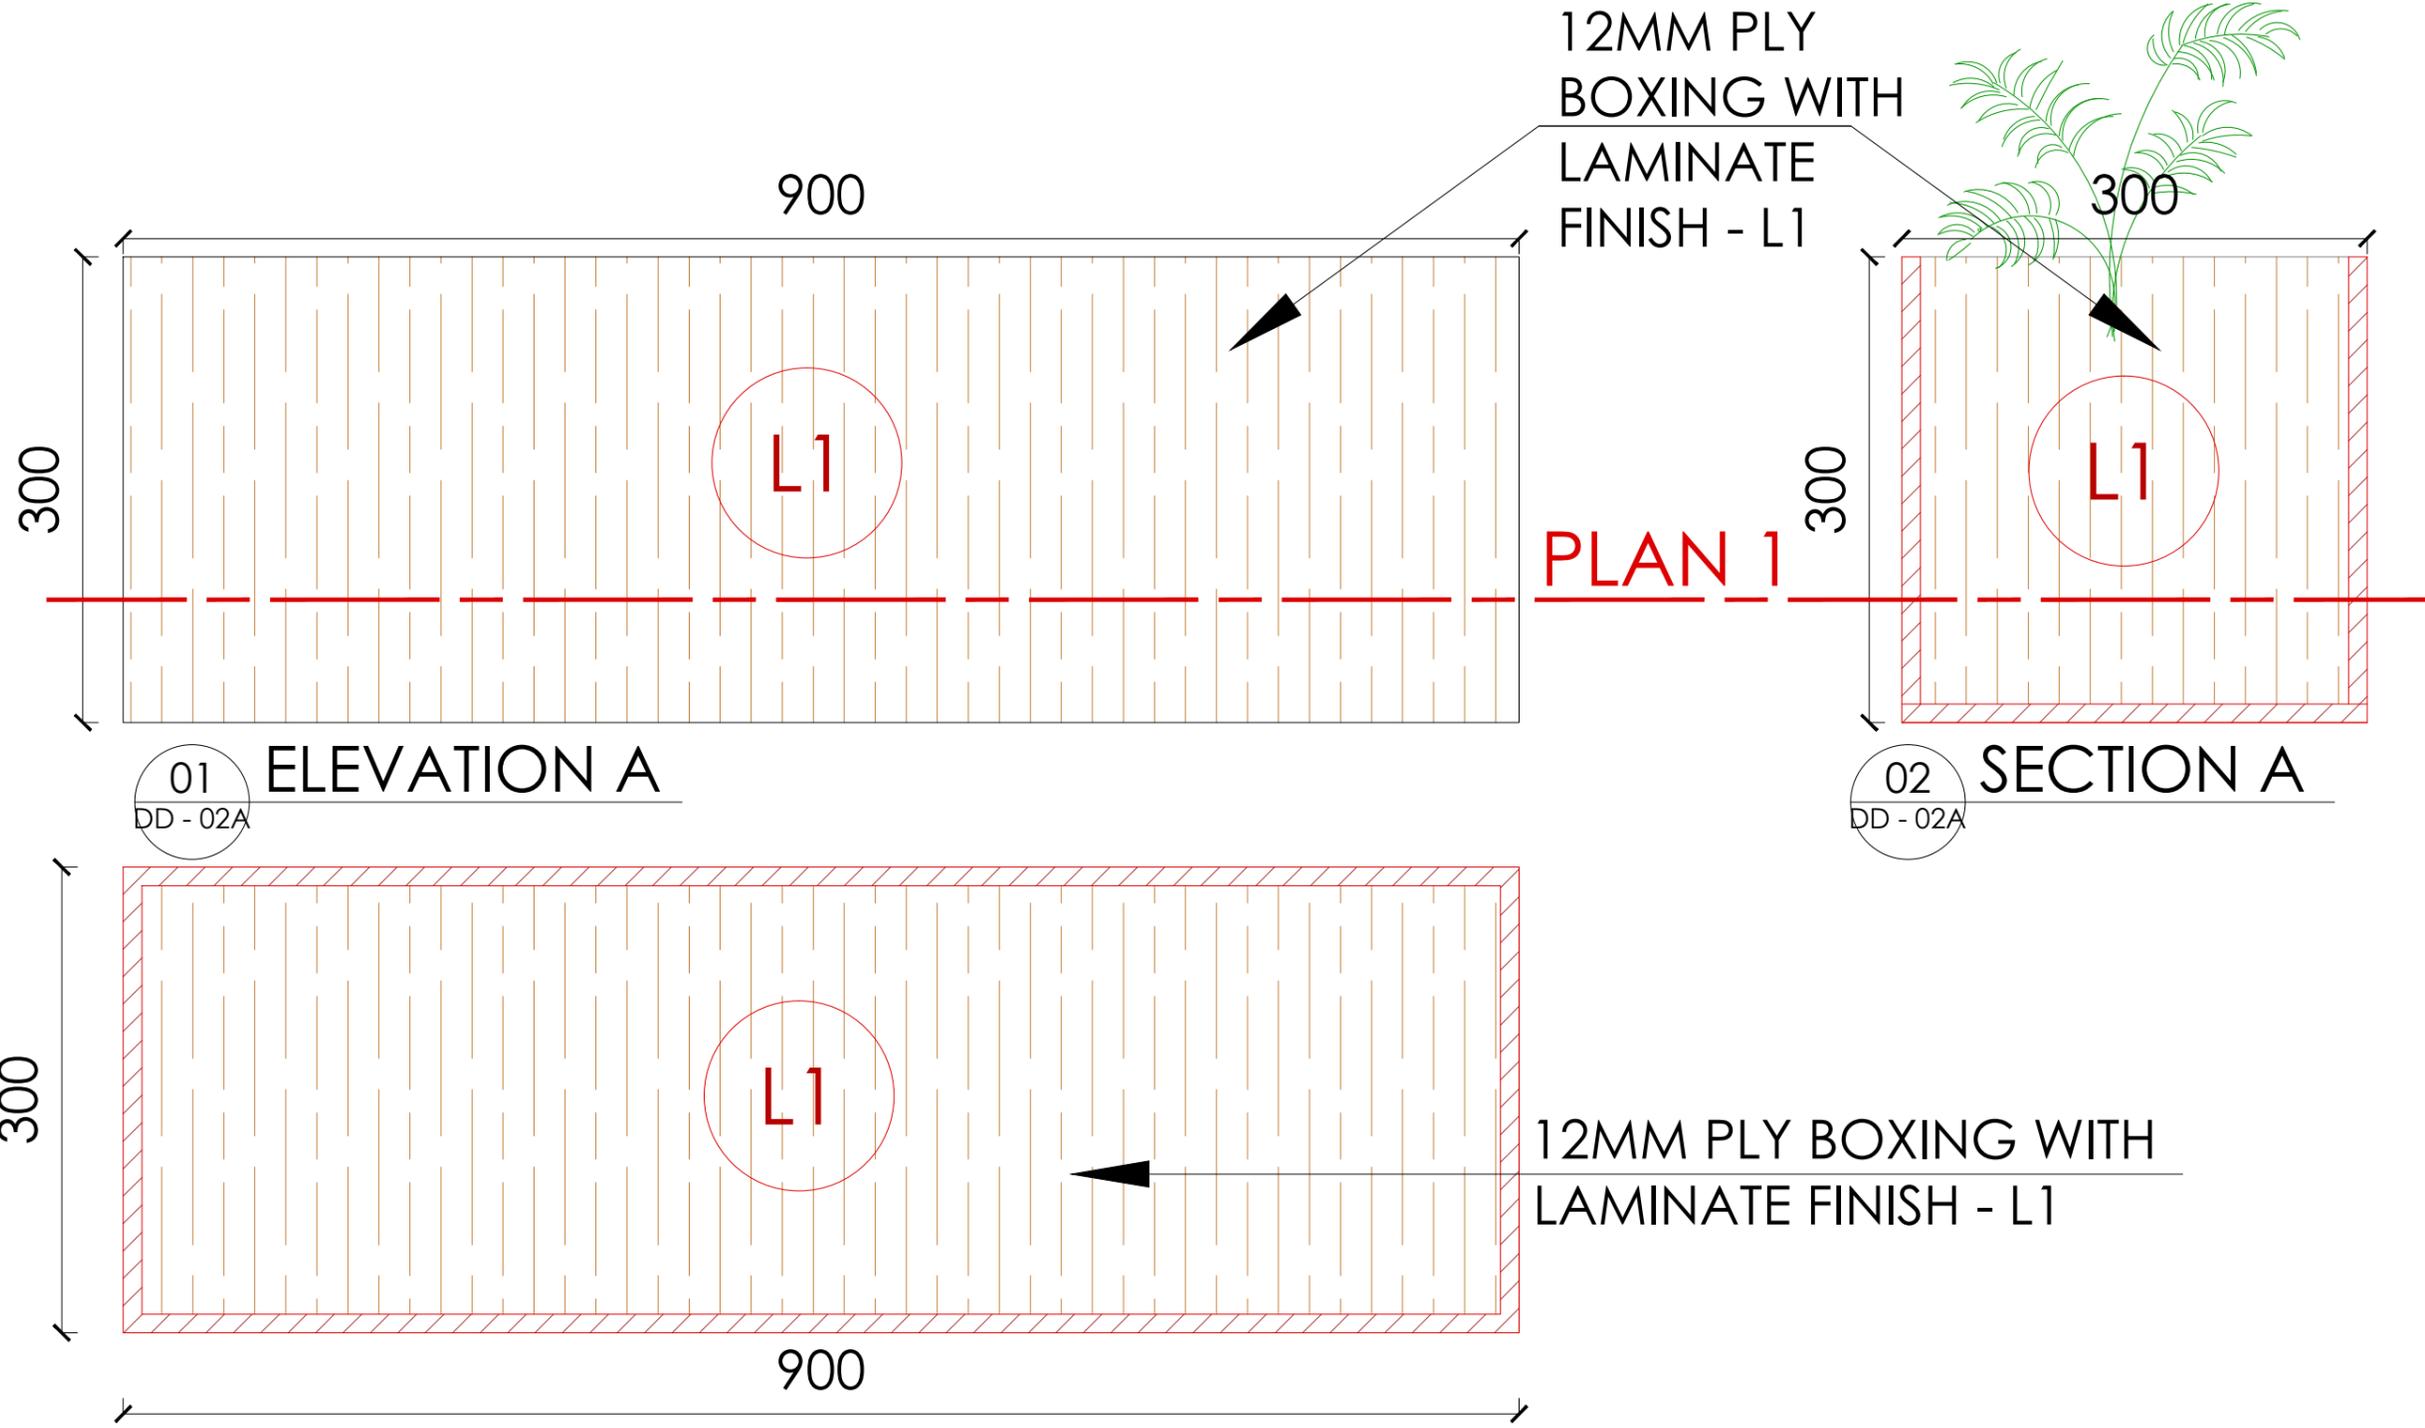

01 ELEVATION A
DD - 02A

02 SECTION A
DD - 02A

03 PLAN - 1
DD - 02A

REV	DESCRIPTION	BY	DATE
1			
2			
3			
4			
5			

Client
BPCL, VIJAYAWADA
VIJAYAWADA

Project Title
PROPOSED OFFICE INTERIOR FOR
BPCL, VIJAYAWADA


Drawing Title
PLANTER BOX A DETAIL DRAWING

Architects
New Designer Web Pvt Ltd
No.185, 2nd Floor, 1st Main road, Nehru nagar,
Kandanchavadi, Perungudi, Chennai - 600096
Tel: +91-944-4212511 www.designerweb.in


Drawn	GOTHAISRI
Checked	KARTHIK
Approved	VYOM
Date	29.01.2024
Scale	SCALE
Dwg No	DD_02A
File Name	

GENERAL NOTE

1. DRAWING TO BE USED ONLY FOR THE PURPOSE RELEASED
2. DO NOT SCALE THIS DRAWING, ONLY WRITTEN DIMENSIONS TO BE FOLLOWED.
3. ANY DISCREPANCY IN THE DRAWING SHOULD BE IMMEDIATELY BROUGHT TO THE NOTICE OF ARCHITECT.

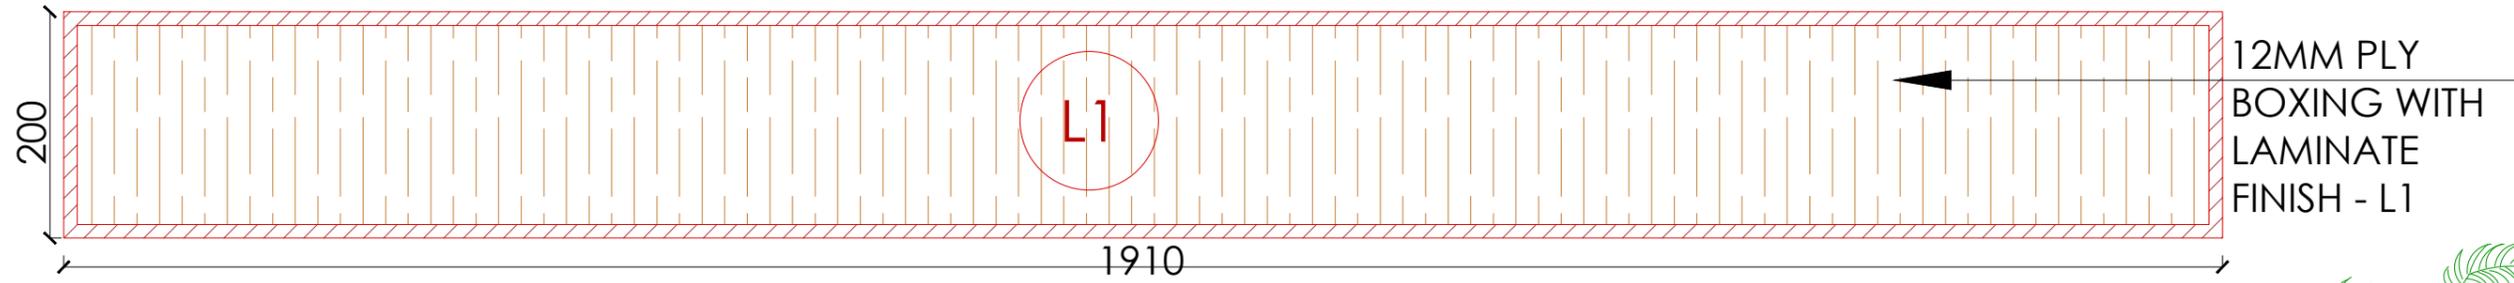

03 PLAN - 1
DD - 02B

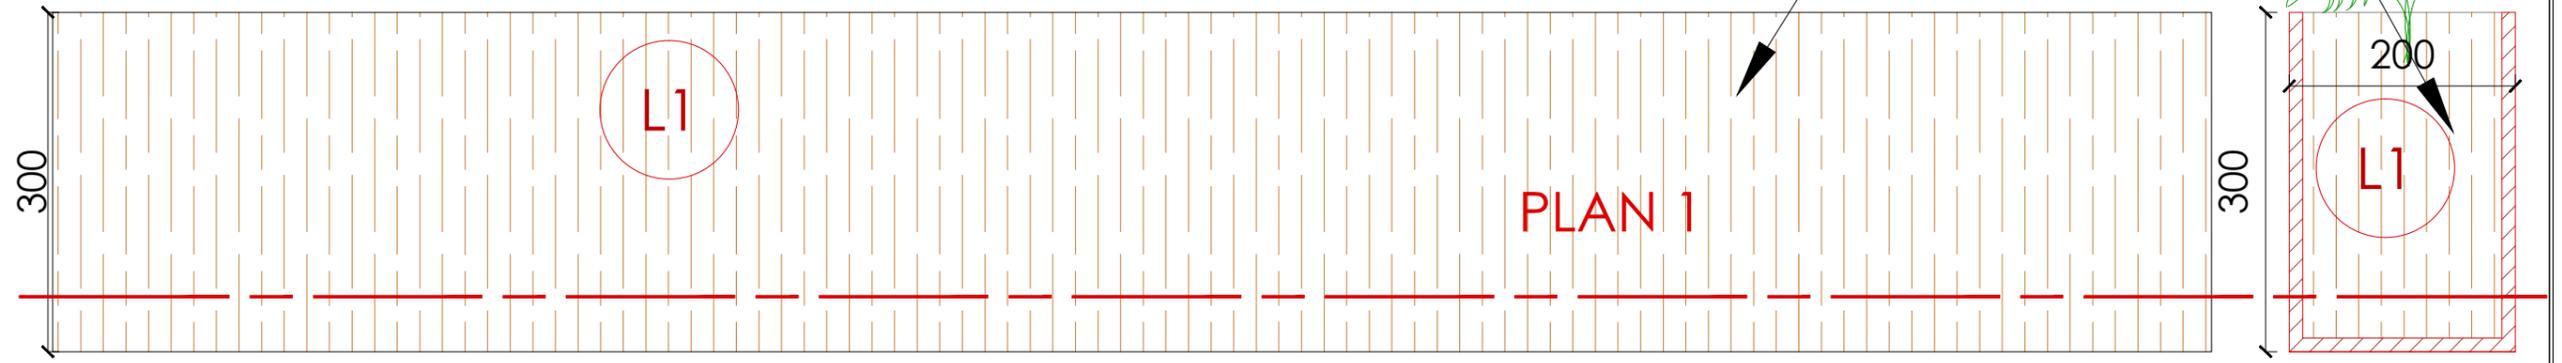

01 ELEVATION A
DD - 02B

02 SECTION A
DD - 02B

REV	DESCRIPTION	BY	DATE
1			
2			
3			
4			
5			

Client
BPCL, VIJAYAWADA
VIJAYAWADA









Project Title
PROPOSED OFFICE INTERIOR FOR
BPCL, VIJAYAWADA

Drawing Title
PLANTER BOX B DETAIL DRAWING

Architects
New Designer Web Pvt Ltd
No.185, 2nd Floor, 1st Main road, Nehru nagar,
Kandanchavadi, Perungudi, Chennai - 600096
Tel: +91-044-4212511 www.designerweb.in

Drawn	GOTHAISRI
Checked	KARTHIK
Approved	VYOM
Date	29.01.2024
Scale	SCALE
Dwg No	DD_02B
File Name	ISSUEFORTENDER



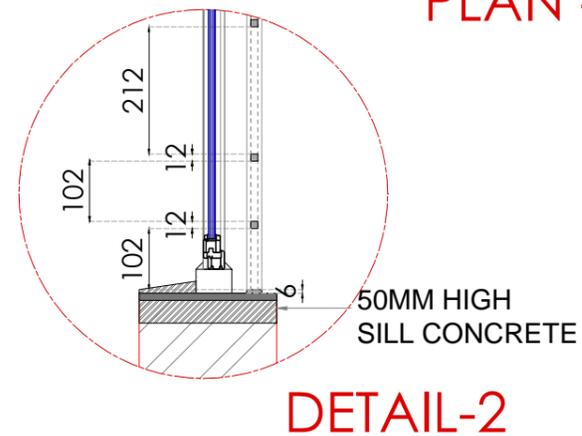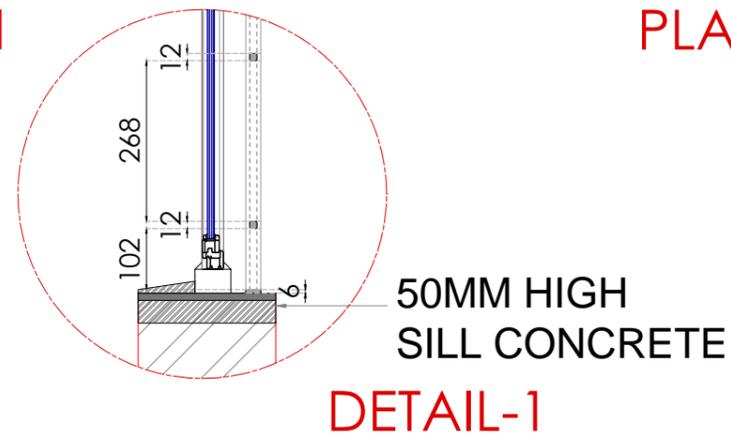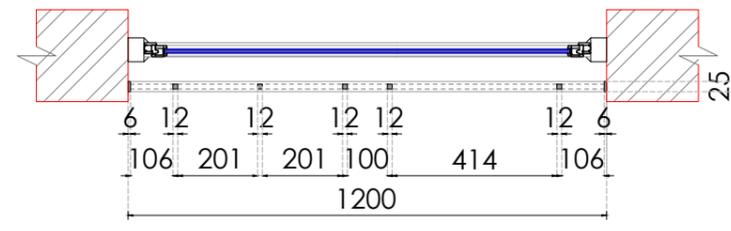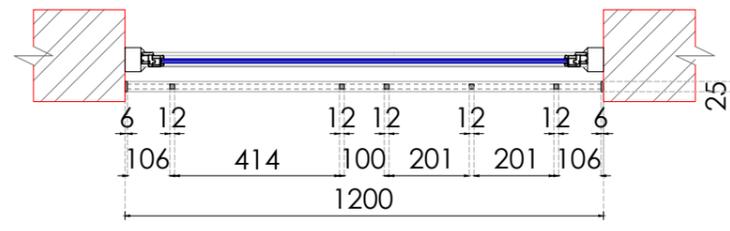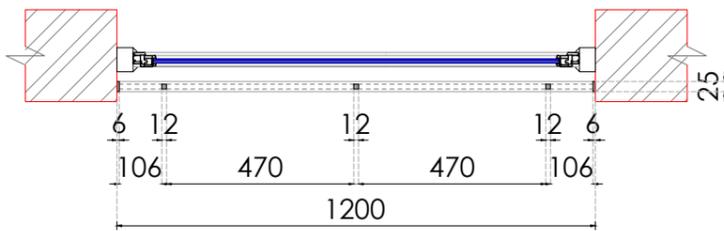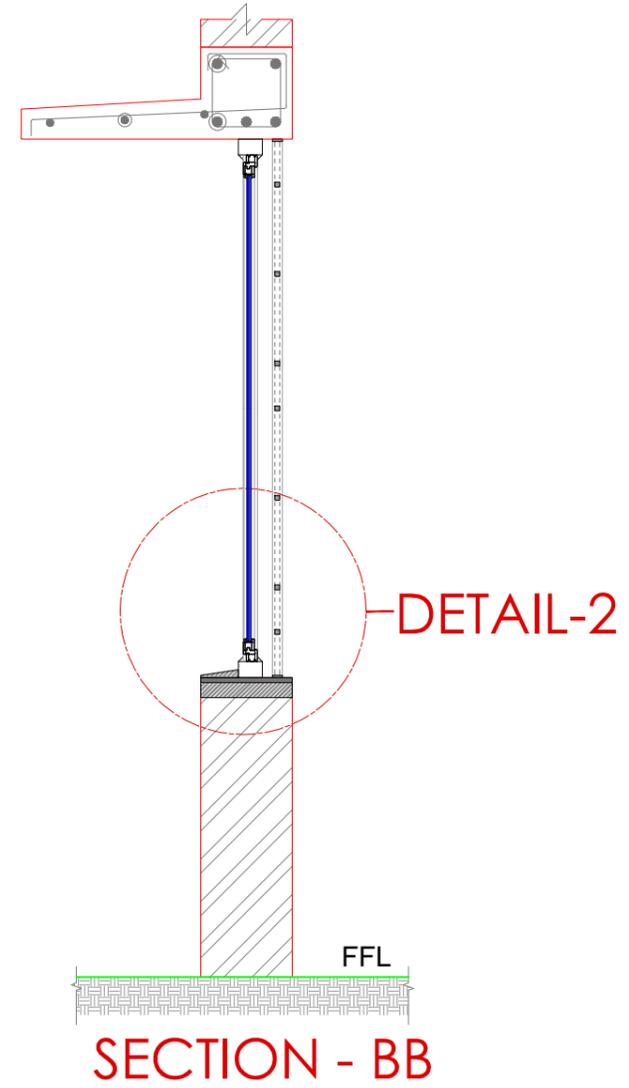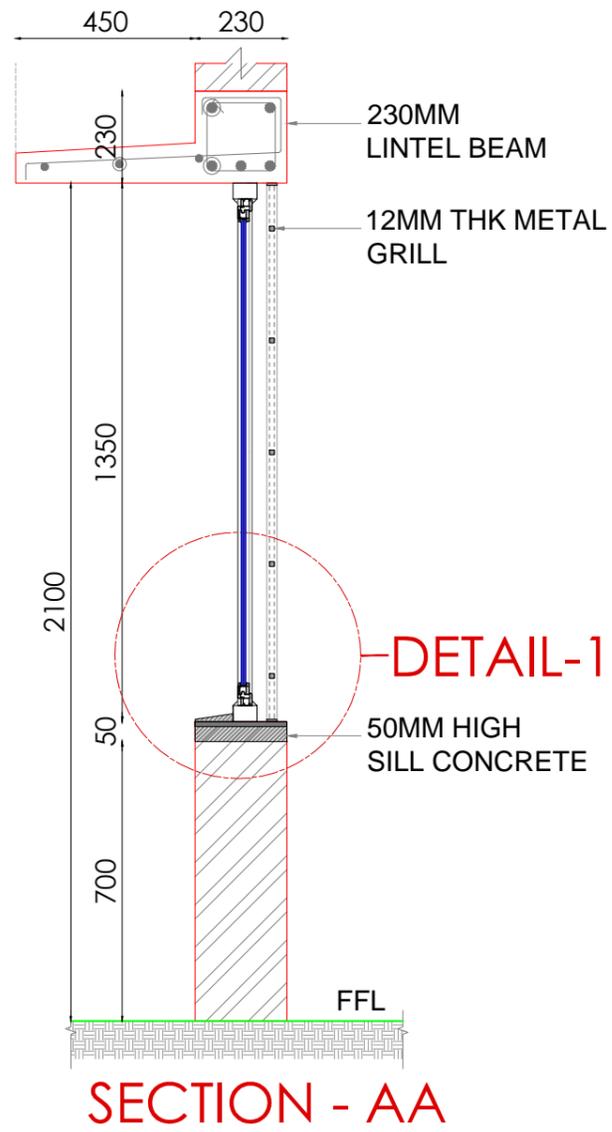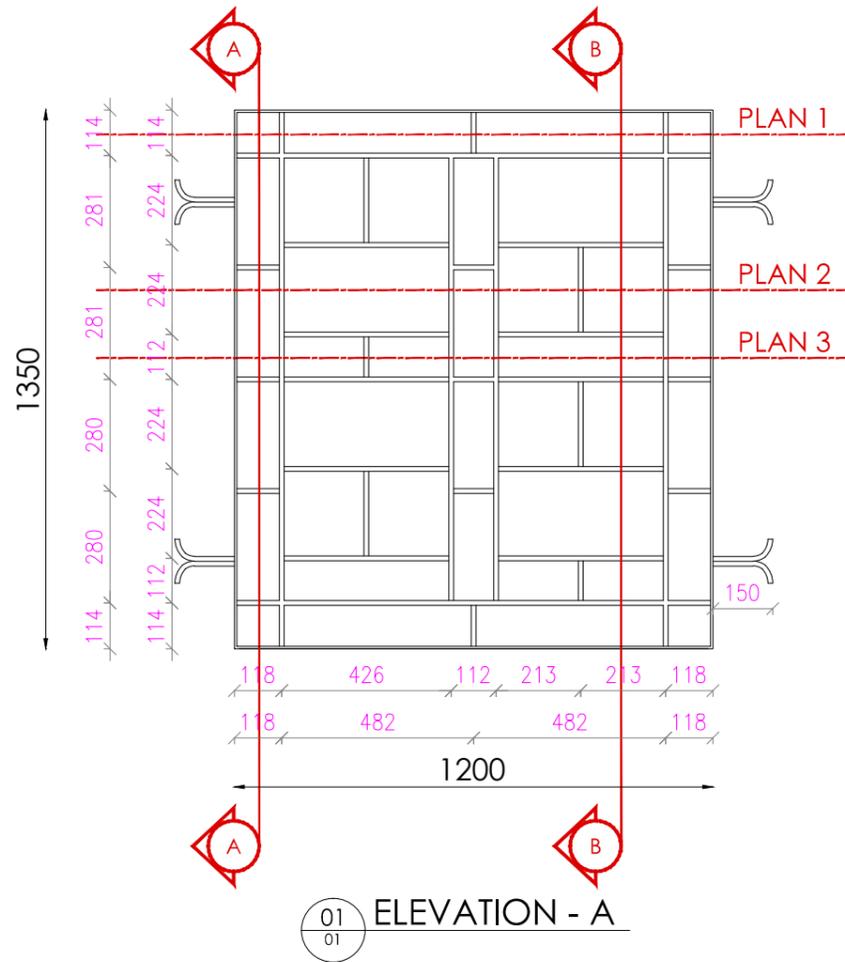

GENERAL NOTE

1. DRAWING TO BE USED ONLY FOR THE PURPOSE RELEASED
2. DO NOT SCALE THIS DRAWING, ONLY WRITTEN DIMENSIONS TO BE FOLLOWED.
3. ANY DISCREPANCY IN THE DRAWING SHOULD BE IMMEDIATELY BROUGHT TO THE NOTICE OF ARCHITECT.

REV	DESCRIPTION	BY	DATE
1			
2			
3			
4			
5			

Client
BPCL

Project Title
PROPOSED INTERIORS FOR BPCL
TERRITORY OFFICE @ VIJAYAWADA

Drawing Title
WINDOW GRILL
DETAILED DRAWING

Architects
New Designer Web Pvt Ltd
No.185, 2nd Floor, 1st Main road, Nehru nagar,
Kandanchavadi, Perungudi, Chennai - 600096
Tel: +91-844-4212511 www.designerweb.in

Drawn	VETRIVEL
Checked	KARTHIK
Approved	VYOM
Date	23.08.24
Scale	
Dwg No	
File Name	